



← ShelteR respond recover resi
TEAM NAME: CROWDER/DR ADDRESS: DRURY UNIVERS 900 N BENTON AVE SPRINGFIELD, MO 63 CROWDER COLL 601 LACLEDE AVE NEOSHO, MO 64 CONTACT: SHELTER.DRURY CROWDERDRURYSOLAR@GMAIL. AUGUST 17TH,
-C CLIENT U.S. DEPARTMENT OF ENERGY SOLAR DECATHLON 2015 WWW.SOLARDECATHLON.GOV U.S. DEPARTMENT OF ENERGY SOLAR DECATHLC
B B CONSTRUCTION DRAW AUG. 17th AS BUILT AS BUILT B B CONSTRUCTION DRAW AUG. 17th AS BUILT B CONSTRUCTION DRAW AUG. 17th AUG
DRAWN BY: Author CHECKED BY: Checker COPYRIGHT: NONE: PROJECT IS PUBLIC DOMAIN SHEET TITLE COVER PAGE G-001

F			1 2	3
	Γ		SHEET LIST	
		SHT NO	SHEET NAME	
	_	G-001 G-002	COVER SHEET       TABLE OF CONTENTS	
E		G-101	ZONING CODES, S.F. COMPLIANCE, EGRESS/FIRE PROTECTION, ADA	
		G-201	GROUND CONTACT PLAN	
	_	H-101	SPILL CONTAINMENT PLAN	
		L-101	LANDSCAPE PLAN & DETAILS	
		L-102	DECK	
1		S-101	FOUNDATION PLAN AND DETAILS	
		S-102	DECK & FLOOR FRAMING PLANS	
		S-103	ROOF FRAMING PLANS	
		S-401	STEEL DETAILS	
	-	S-402	STEEL DETAILS	
D-		A-101	FLOOR PLAN & REFLECTED CEILING PLAN	
0-		A-102	ROOF PLAN	
	_	A-201 A-202	ELEVATIONS ELEVATIONS & CLADDING DETAILS	
		A-203	CLADDING SCHEDULE & DETAILS	
		A-301	BUILDING SECTIONS & INTERIOR ELEVATIONS	
		A-302	WALL SECTIONS	
		A-401 A-402	FENCE UNITS & DETAILS FENCE PANELS & BRACKETS	
Τ	-	A-402	KITCHEN CABINETS	
		A-404	BATHROOM DETAILS	
		A-405 A-901	CABINET DETAILS ARCHITECTURAL RENDERINGS	
	-	A-901 A-902	ARCHITECTURAL RENDERINGS	
C–		P-101	DOMESTIC SUPPLY / RETURN PLANS & FIRE SUPPRESSION	
U	_	M-101	MECHANICAL PLAN	
		E-101 E-102	DISTRIBUTION PLAN AND GENERAL ELECTRICAL NOTES           PV WIRING DIAGRAM	
		E-601	PV WIRING DIAGRAW PV ONE LINE DIAGRAM	
		E-602	PV THREE LINE DIAGRAM	
-		E-603	SERVICE CALCULATIONS AND SCHEDULE	
		O-101	WATER DELIVERY AND PICK-UP	
	_	O-901	TRUCK LOADING DIAGRAM	
		O-902	CONSTRUCTION SEQUENCE	
B–				
T				
A				
F				
09 PV				
5 4:47:				
2/12/2015 4:47:09 PM				
2/1:			1 2	3


	3	· · · · · · · · · · · · · · · · · · ·	4	5	6	
	3		4	5	6	

7	ſ			
	Ē	S		hiversity <b>IteR<sup>3</sup></b> recover resist
	–D	TEAM NAI ADDRESS	; ; ;	CROWDER/DRURY DRURY UNIVERSITY 900 N BENTON AVENUE SPRINGFIELD, MO 65802 CROWDER COLLEGE 601 LACLEDE AVENUE NEOSHO, MO 64850 SHELTER.DRURY.EDU RDRURYSOLAR@GMAIL.COM
	Ċ		SOLAR DE WWW.SOLAR	MENT OF ENERGY CATHLON 2015 DECATHLON.GOV MENT OF ENERGY DECATHLON CONSTRUCTION DRAWINGS REVISED
	B	MARK LOT NUMI DRAWN B CHECKED COPYRIG	Y: ) BY: HT: TLE	DETAILS DETAILS DETAILS DETAILS DETAILS TINDEX
7			G-	002

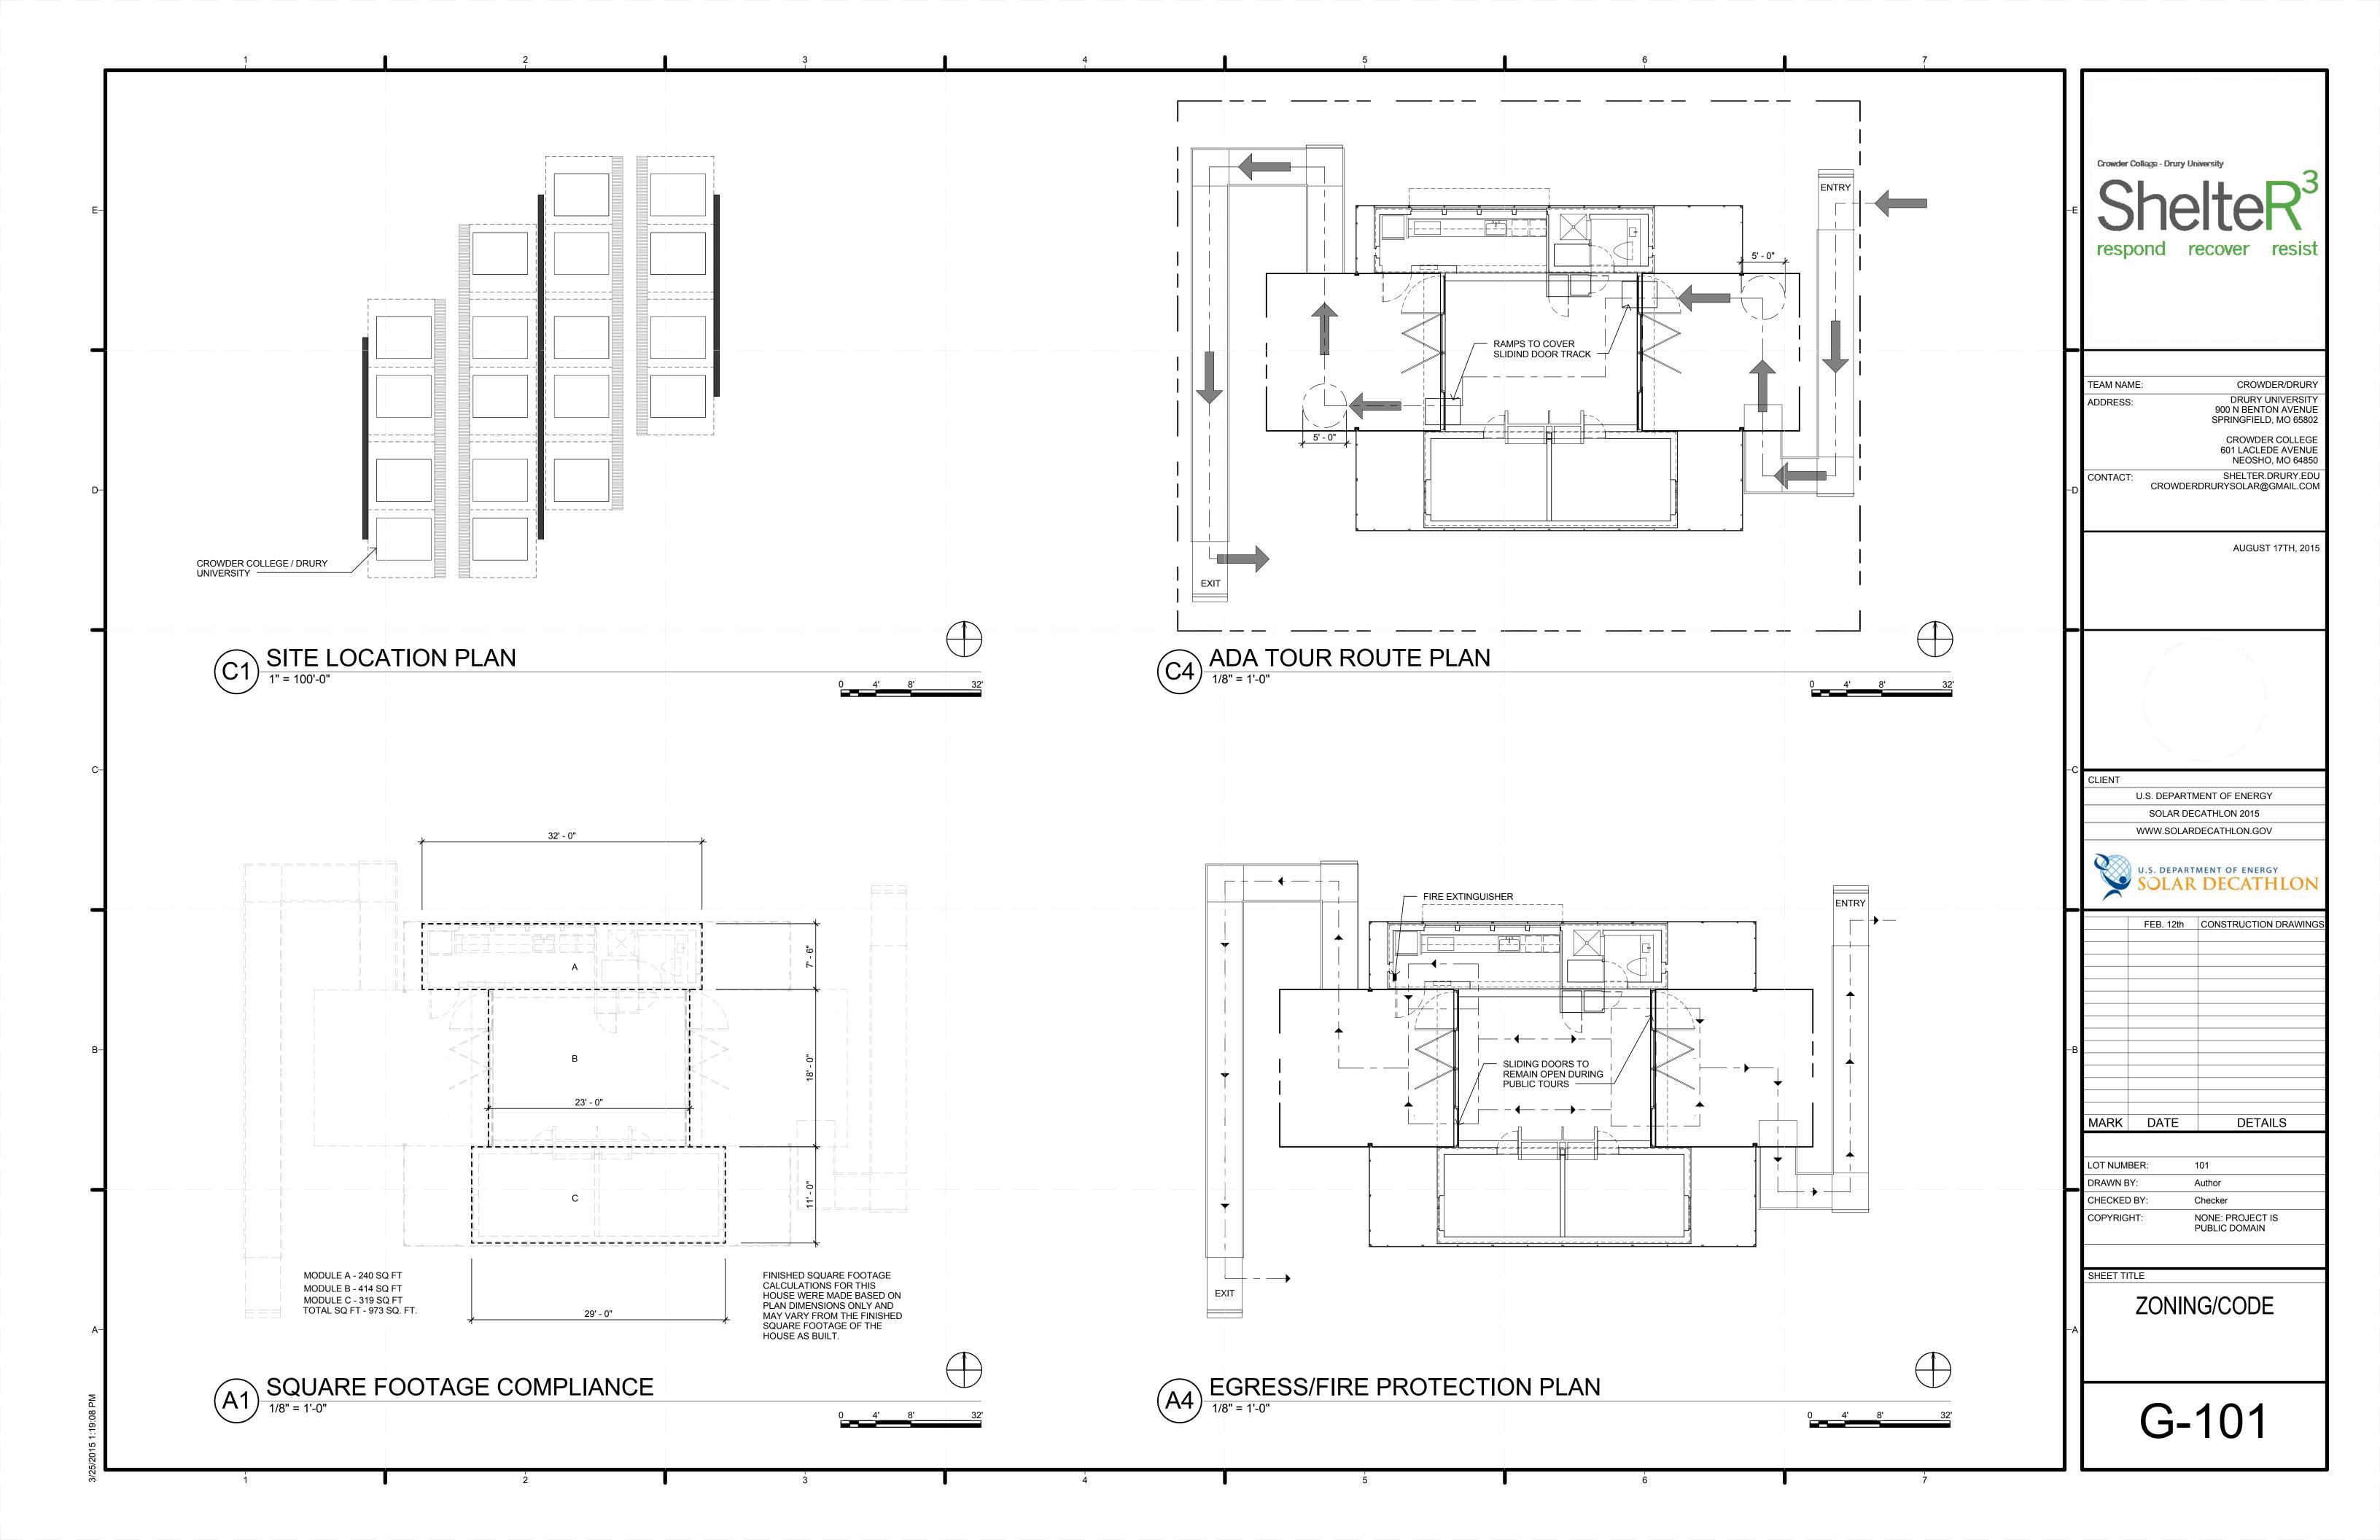

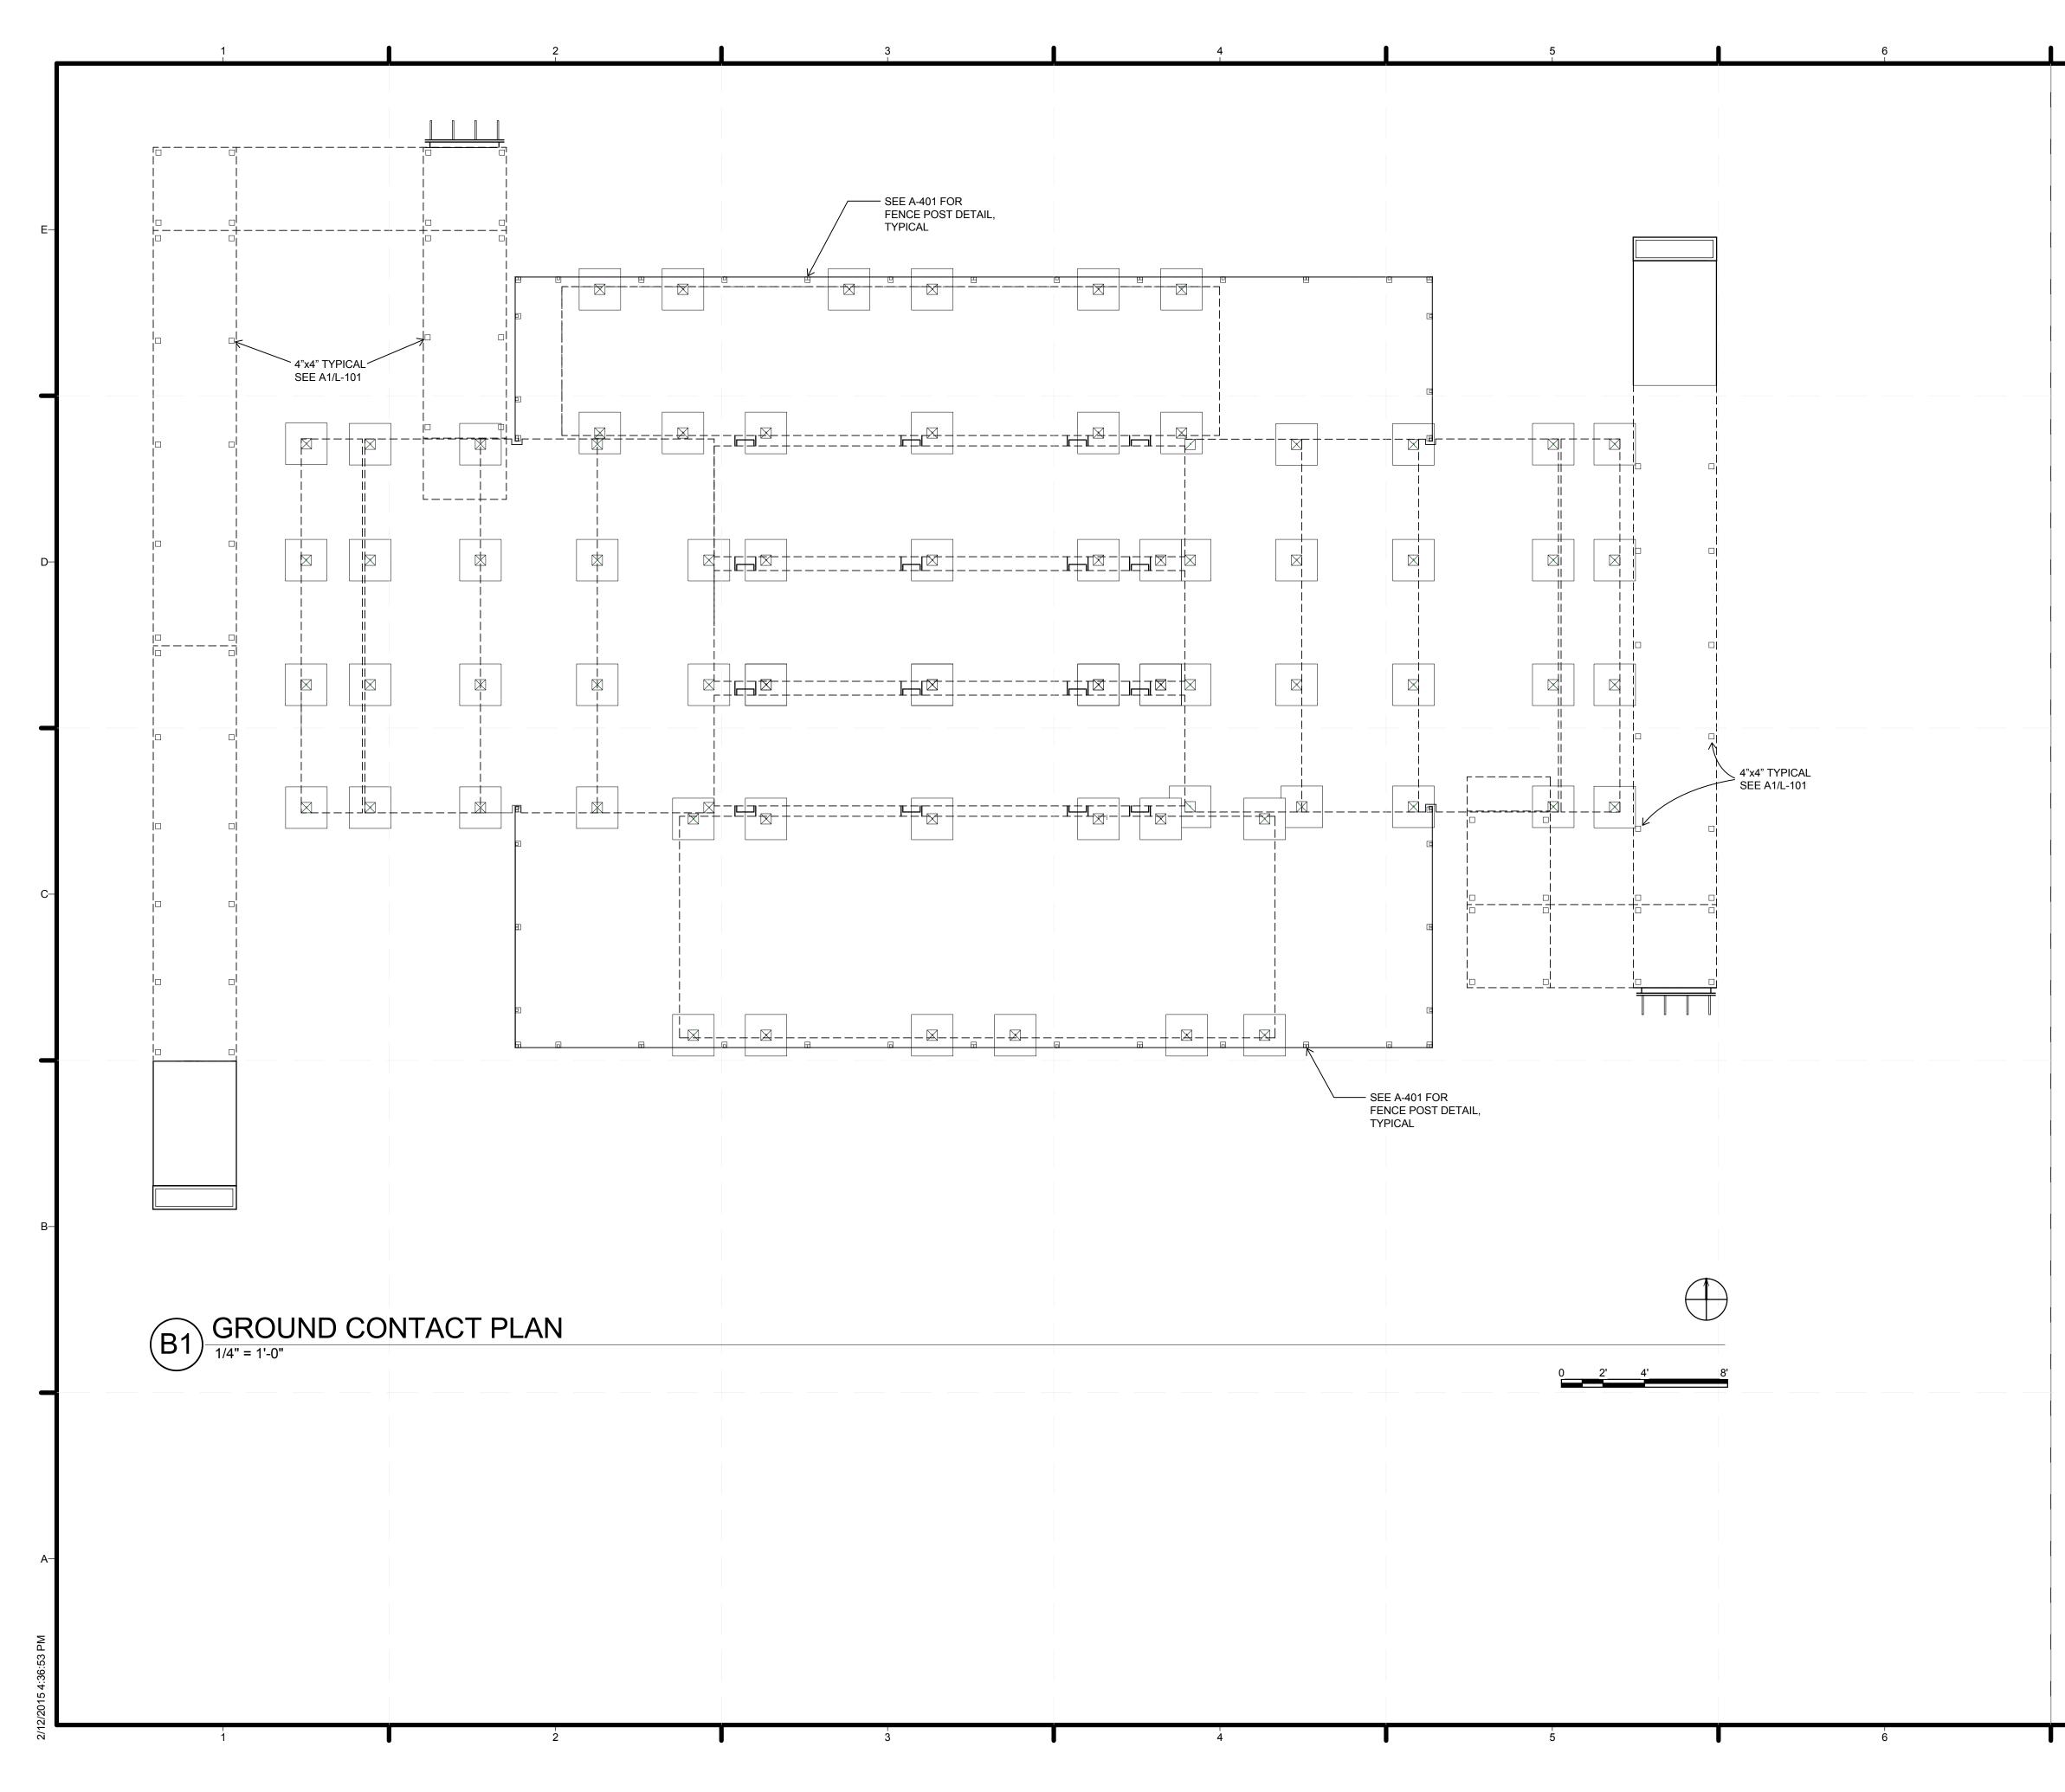



7	
<ul> <li>PLAN NOTES</li> <li>1. NO GROUND PENETRATIONS ARE REQUIRED DUE TO 1/8" EPDM RUBBER FRICTION PAD BELOW ALL SEISMIC PIERS-SEE STRUCTURAL SEISMIC NARRATIVE IN PROJECT MANUAL</li> <li>2. SEE A1/S-101 FOR LOCATION OF SIESMIC PIERS AND STANDING PIERS</li> <li>3. SEE A-401 FOR FENCE POST DETAILS</li> </ul>	Trowder College - Drury University ShelteR respond recover resist
	TEAM NAME: CROWDER/DRURY ADDRESS: DRURY UNIVERSITY 900 N BENTON AVENUE SPRINGFIELD, MO 65802 CROWDER COLLEGE 601 LACLEDE AVENUE NEOSHO, MO 64850 CONTACT: SHELTER.DRURY.EDU CROWDERDRURYSOLAR@GMAIL.COM AUGUST 17TH, 2015
	C C C C LIENT U.S. DEPARTMENT OF ENERGY SOLAR DECATHLON 2015 WWW.SOLARDECATHLON.GOV U.S. DEPARTMENT OF ENERGY SOLAR DECATHLON
	FEB. 12th       CONSTRUCTION DRAWINGS         AUG. 17th       AS BUILTS         AUG. 17th       AS BUILTS         B       B         MARK       DATE         DETAILS         ILOT NUMBER:       101         DRAWN BY:       Author         CHECKED BY:       Checker         COPYRIGHT:       NONE: PROJECT IS PUBLIC DOMAIN         SHEET TITLE         GROUND CONTACT
	G-201

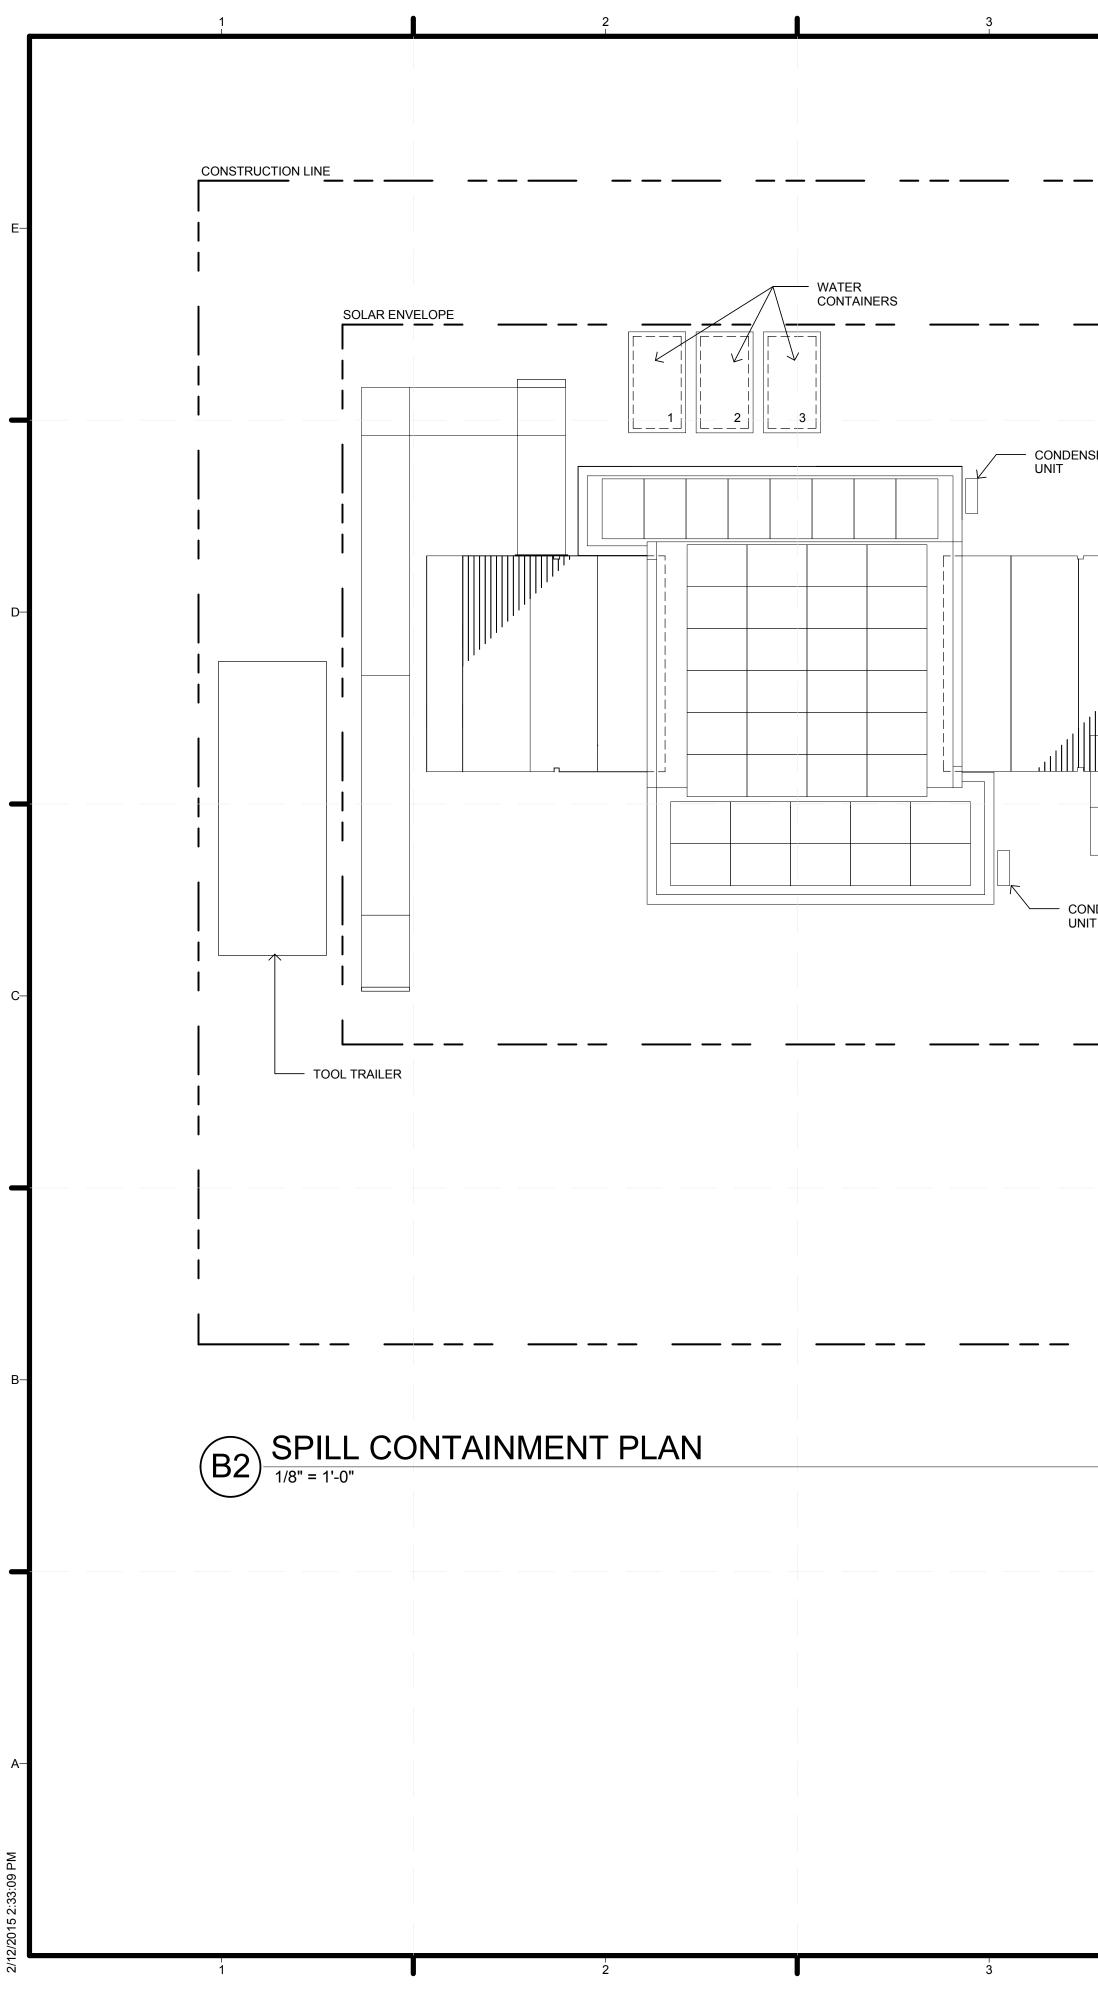



3	4	1	5	1	6	7	7
TER NTAINERS							
	32						
3	1 4		5		6	17	7


7	
	Trespond recover resist
	TEAM NAME: CROWDER/DRURY ADDRESS: DRURY UNIVERSITY 900 N BENTON AVENUE SPRINGFIELD, MO 65802 CROWDER COLLEGE 601 LACLEDE AVENUE NEOSHO, MO 64850 CONTACT: SHELTER.DRURY.EDU CROWDERDRURYSOLAR@GMAIL.COM AUGUST 17TH, 2015
	-C CLIENT U.S. DEPARTMENT OF ENERGY SOLAR DECATHLON 2015 WWW.SOLARDECATHLON.GOV WWW.SOLARDECATHLON.GOV U.S. DEPARTMENT OF ENERGY SOLAR DECATHLON FEB. 12th CONSTRUCTION DRAWINGS AUG. 17th AS BUILTS
	-B MARK DATE DETAILS MARK DATE DETAILS  LOT NUMBER: 101 DRAWN BY: Author CHECKED BY: Checker COPYRIGHT: NONE: PROJECT IS PUBLIC DOMAIN  SHEET TITLE  SPIELL CONTAINMENT PLAN & DETAILS
	H-101

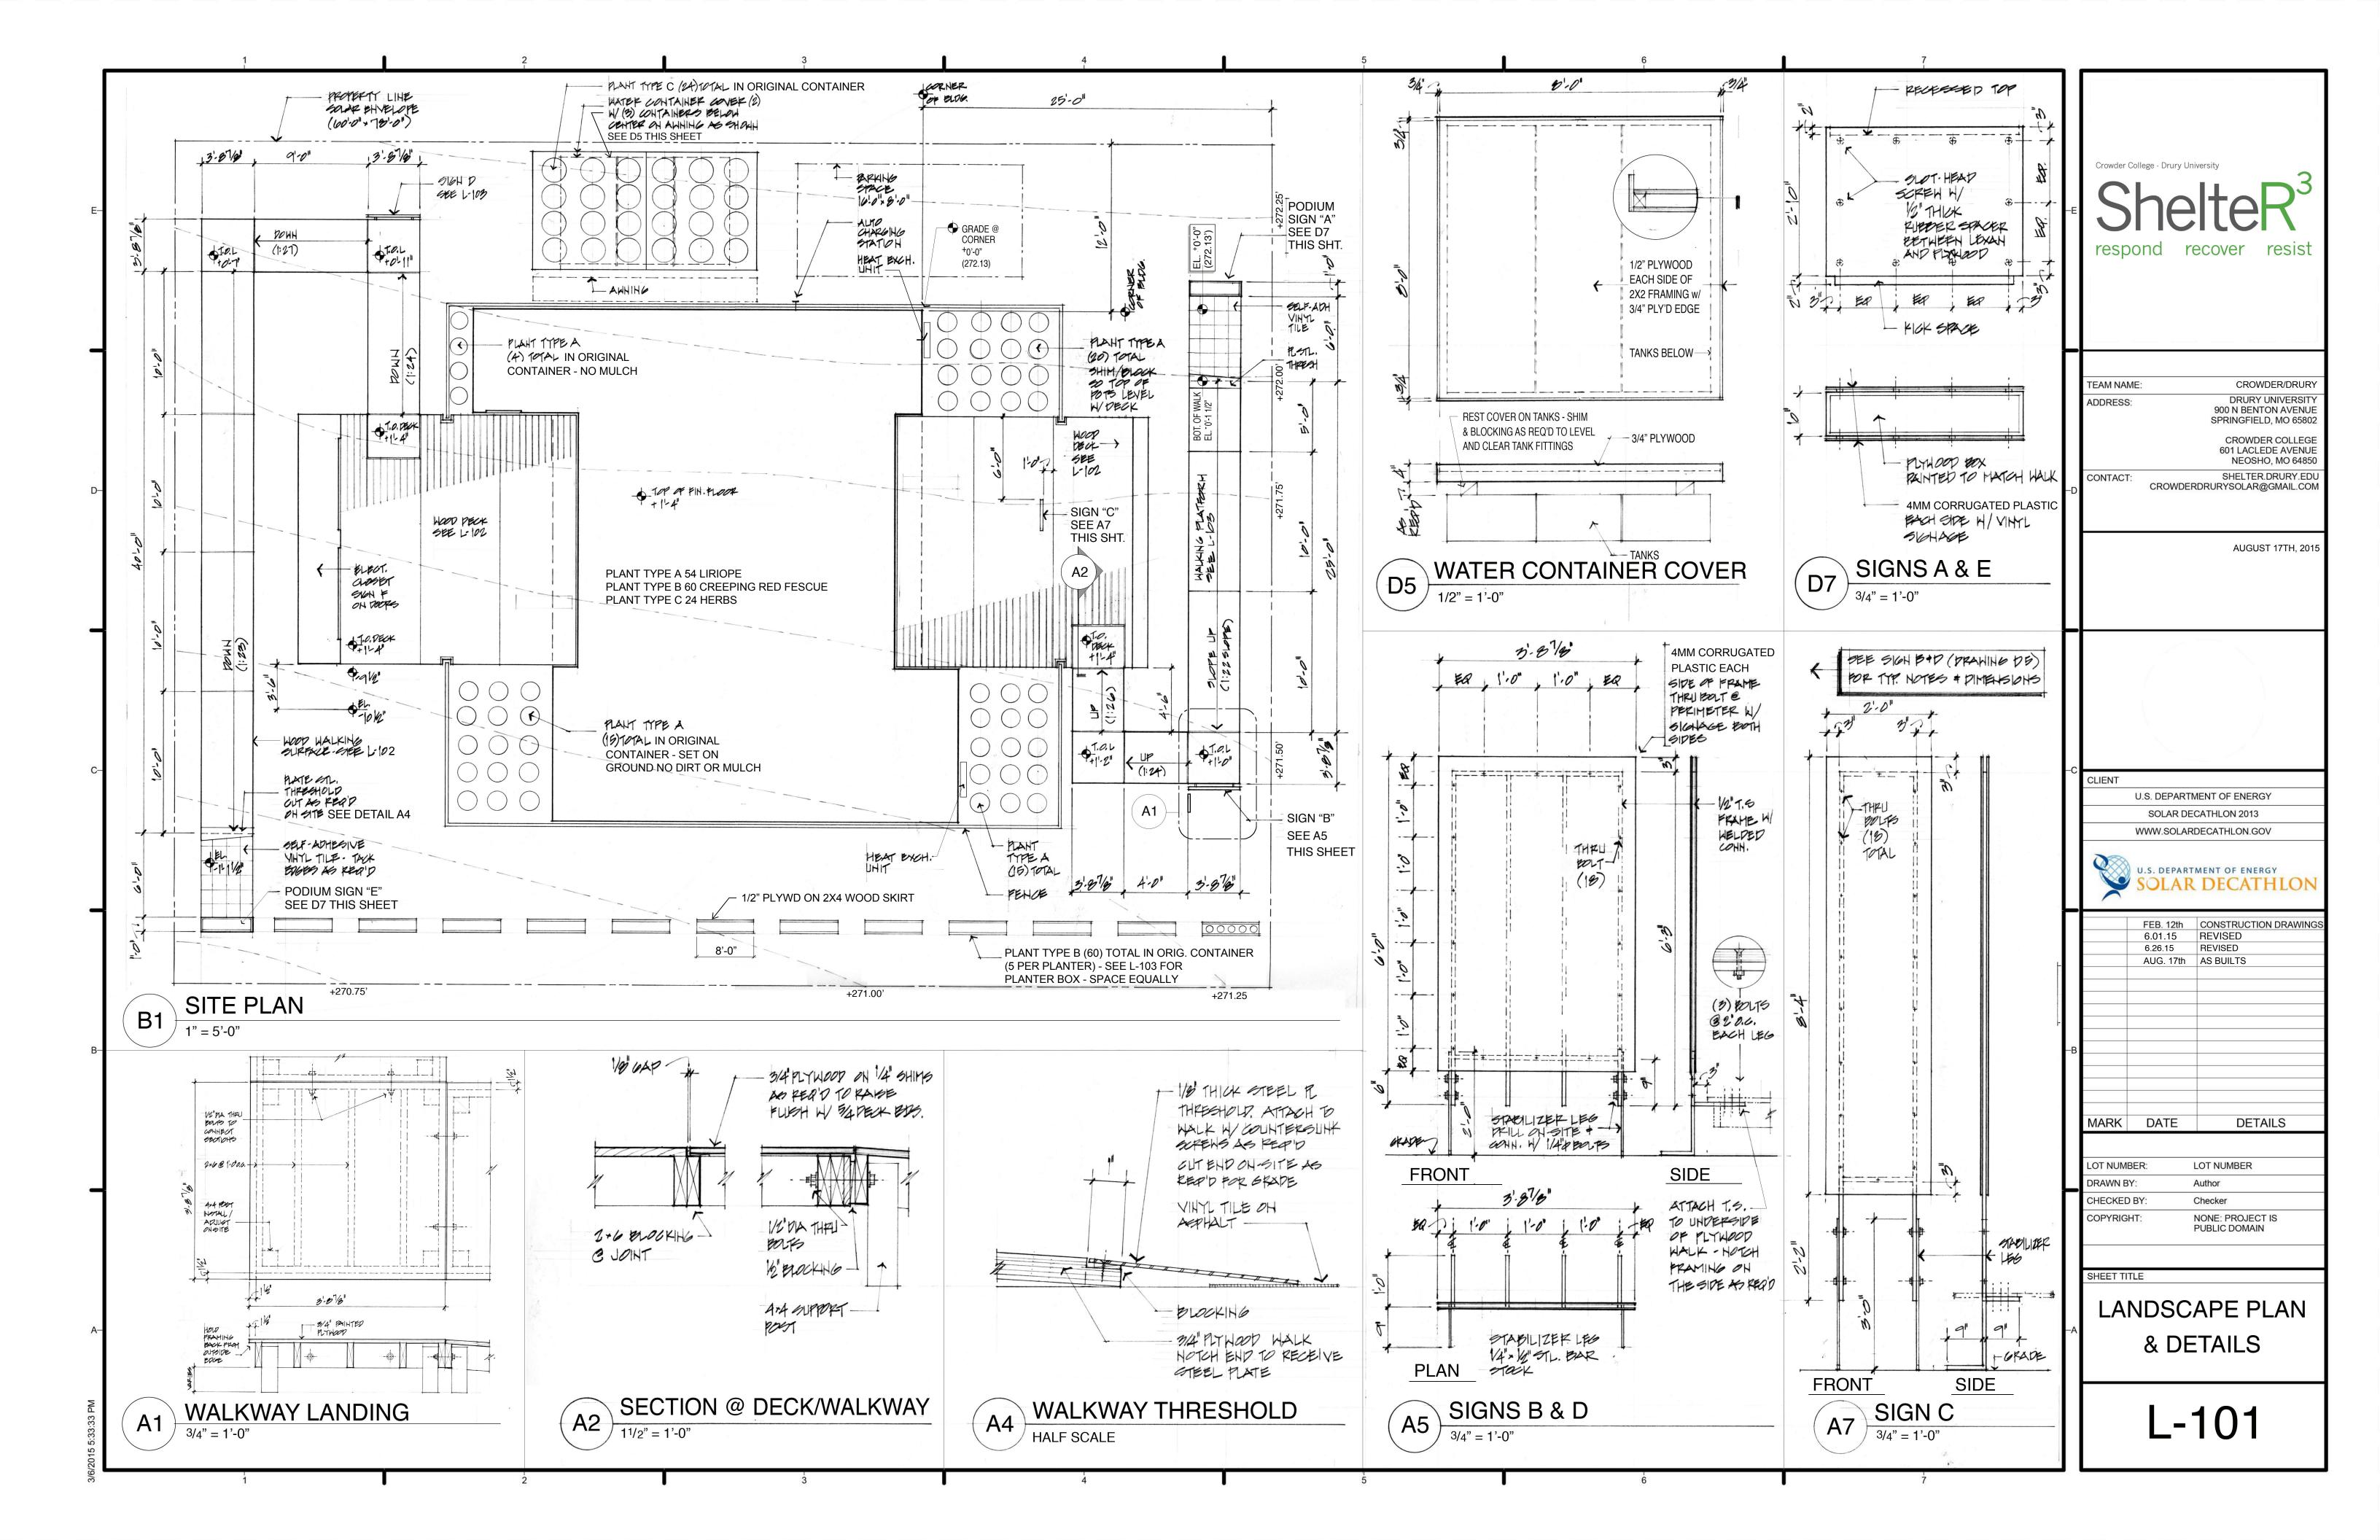


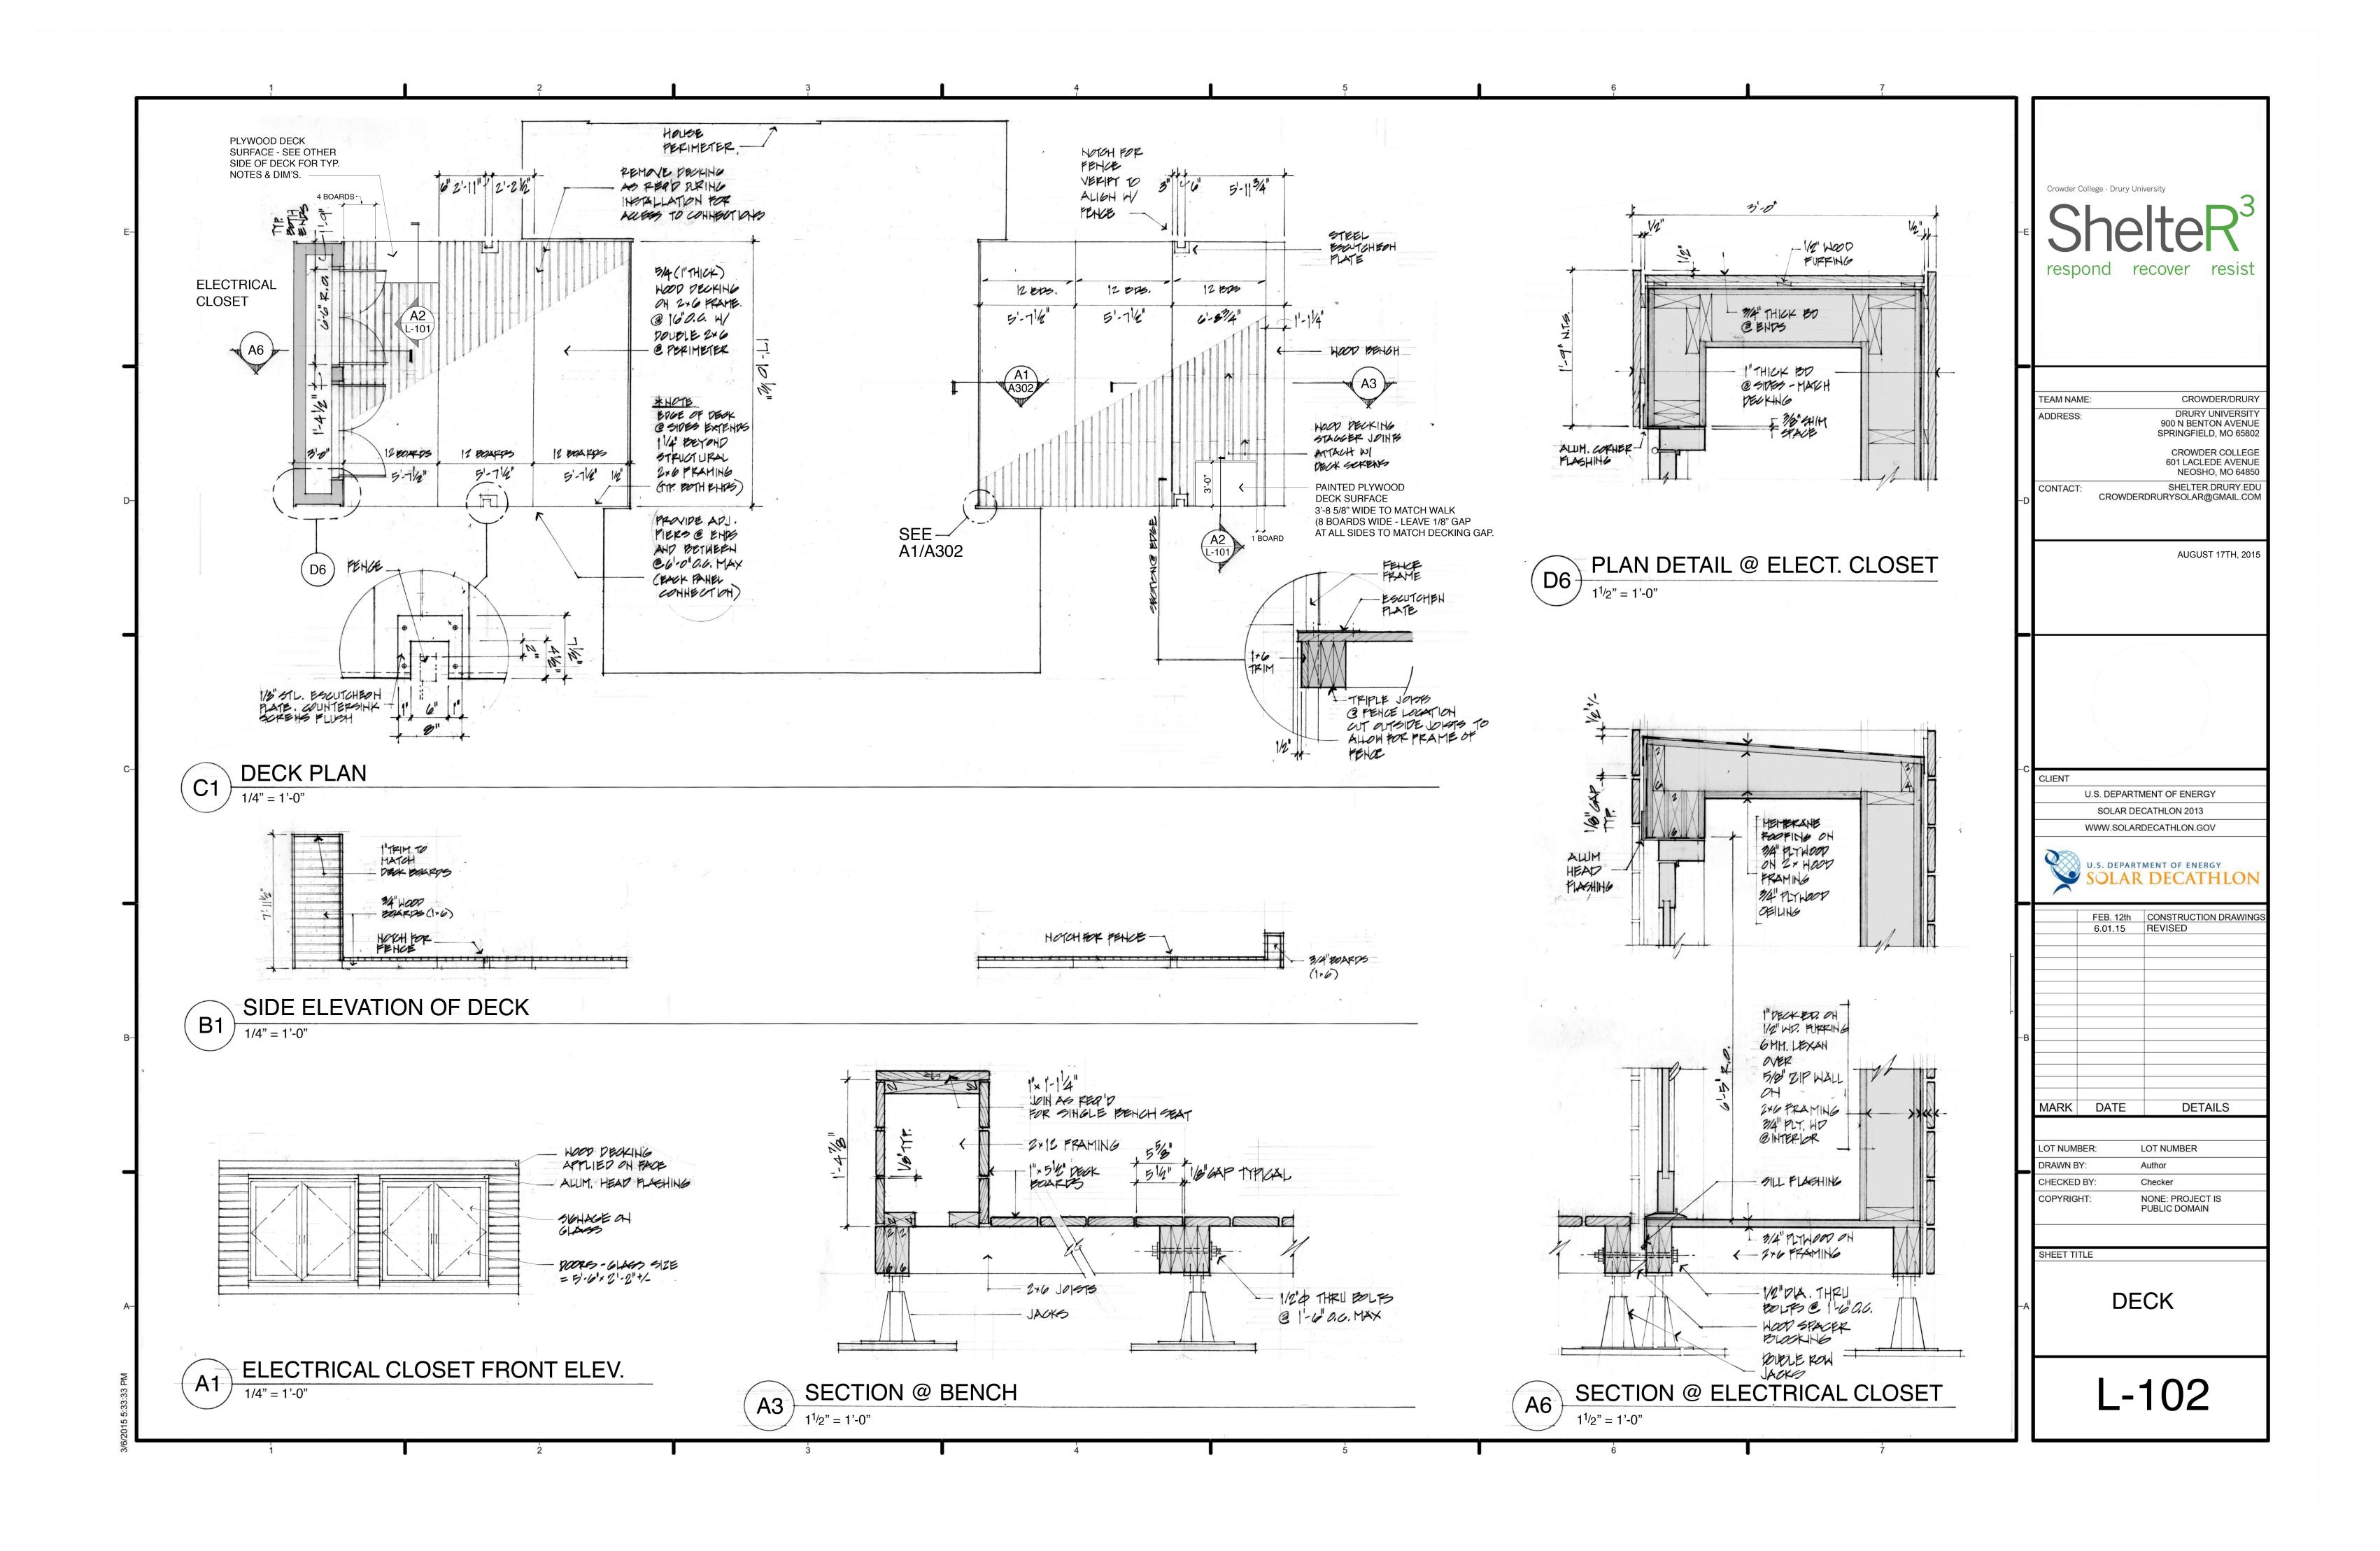


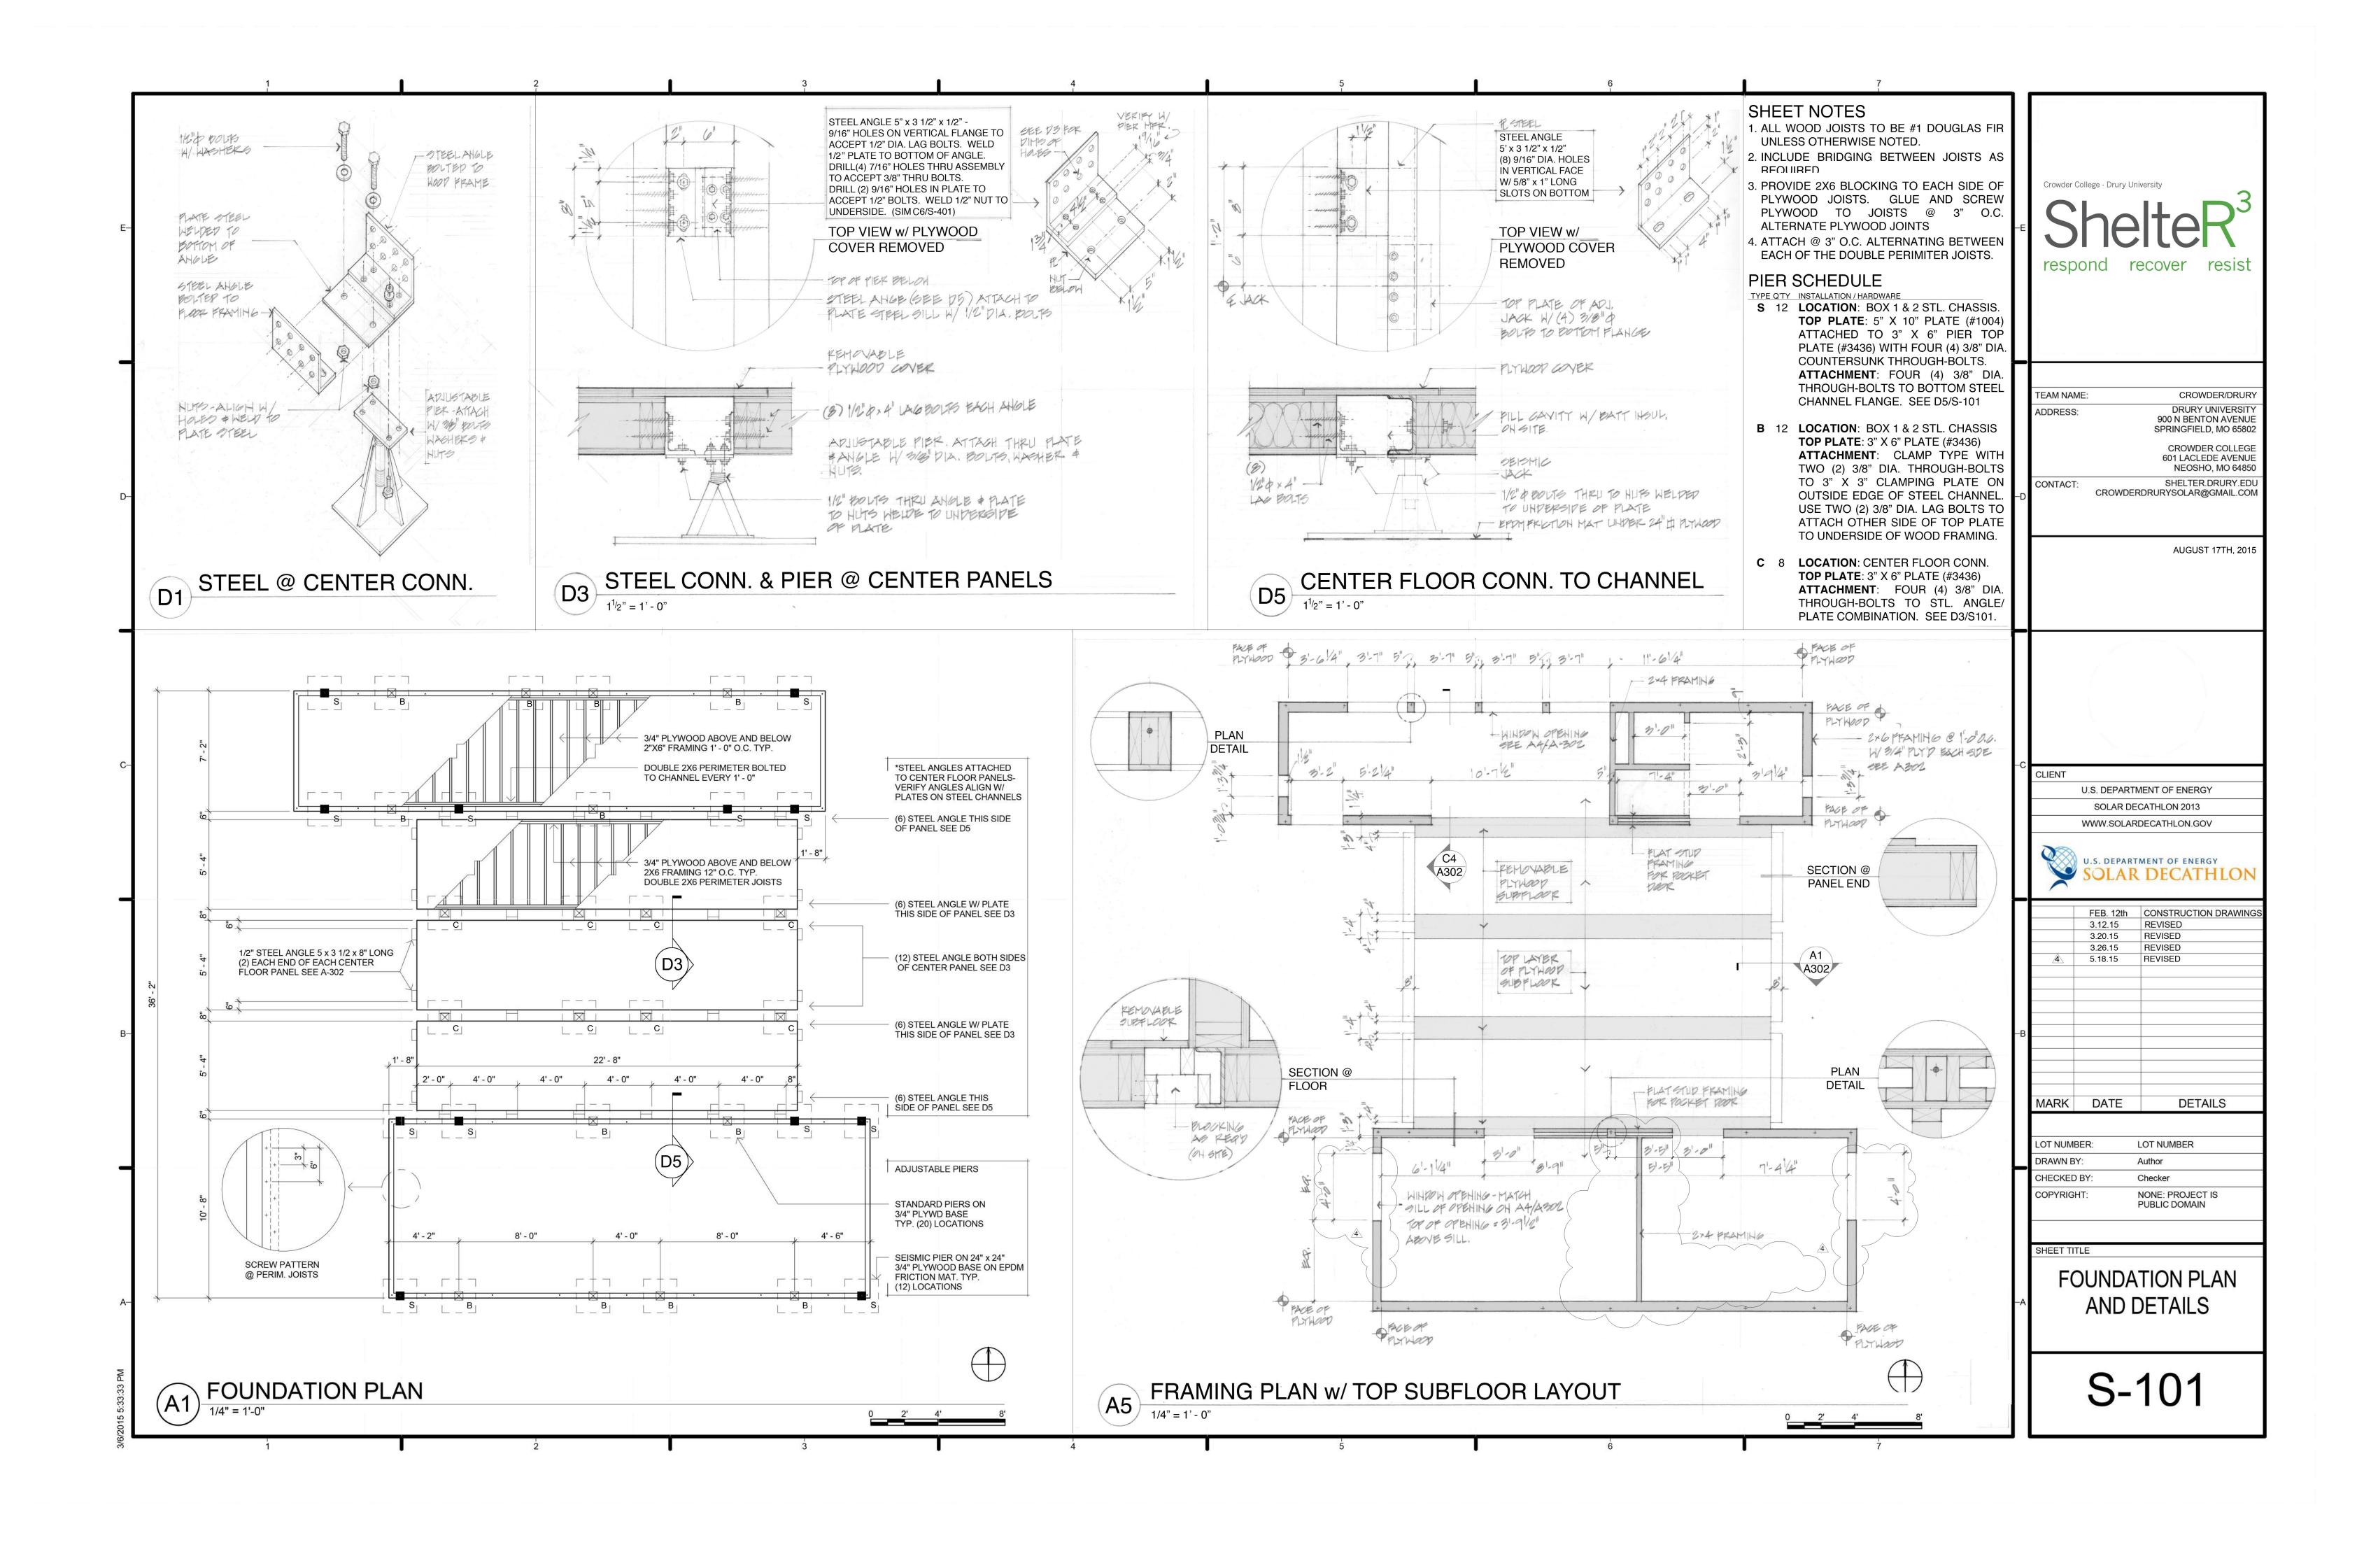


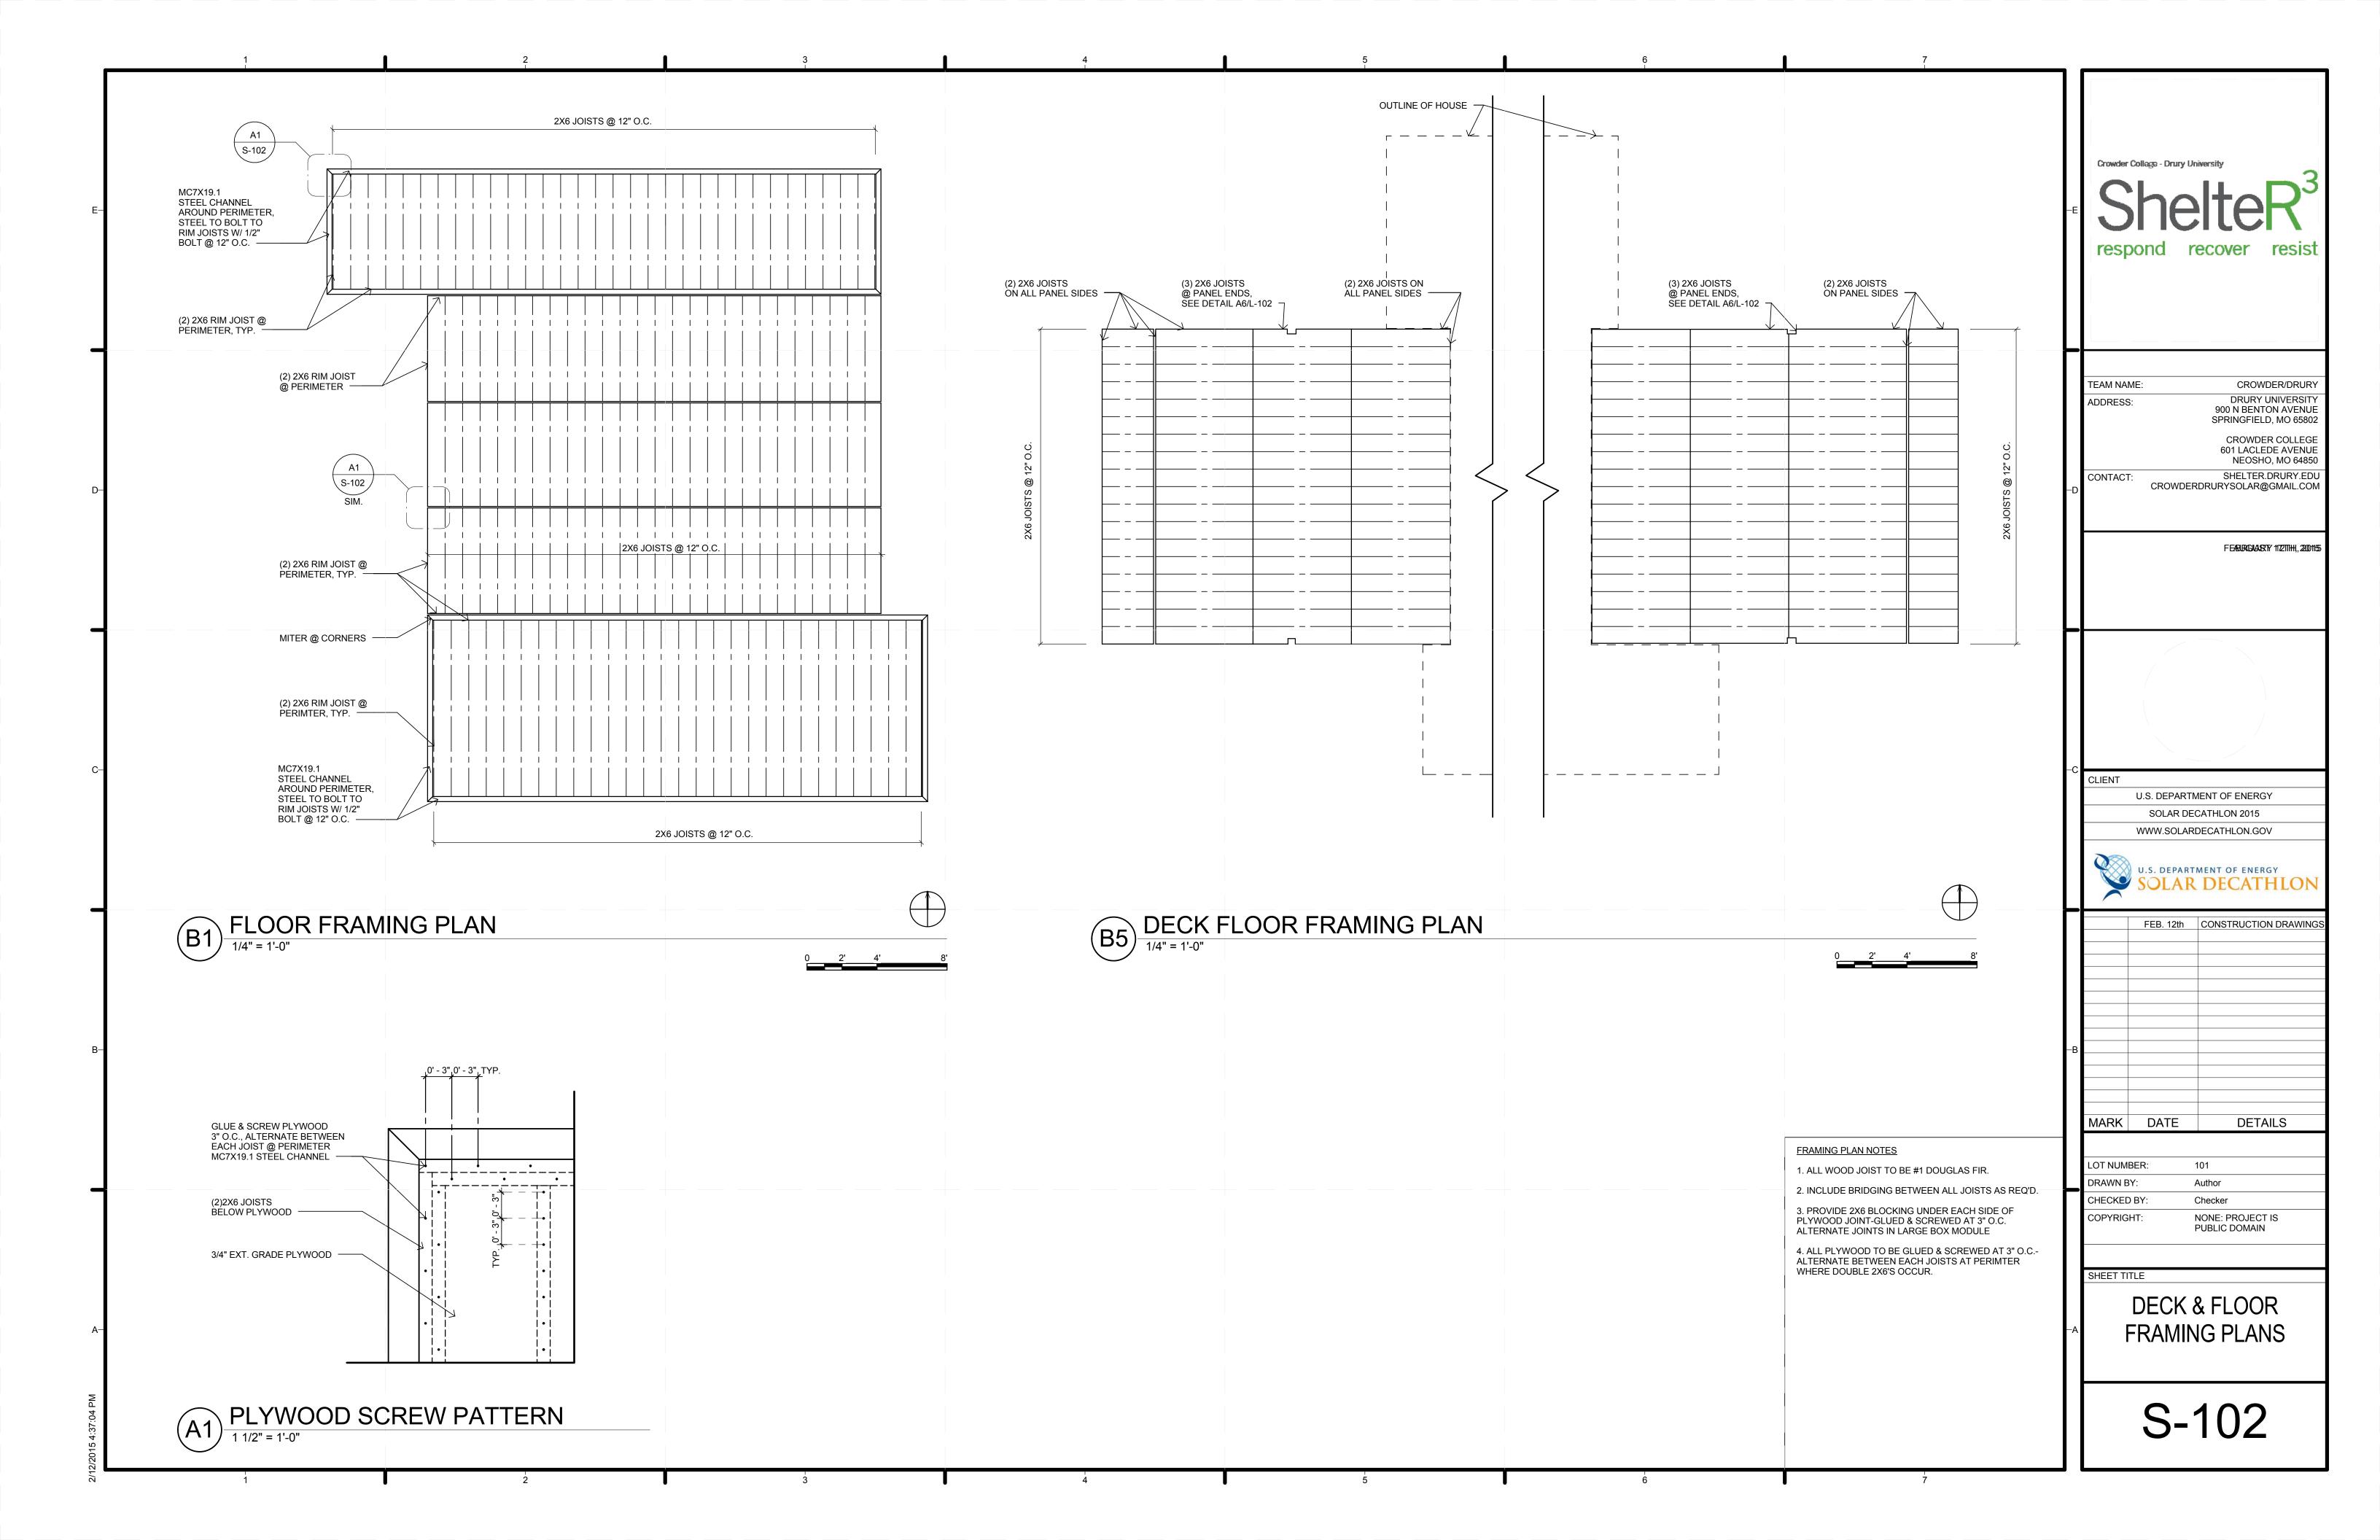


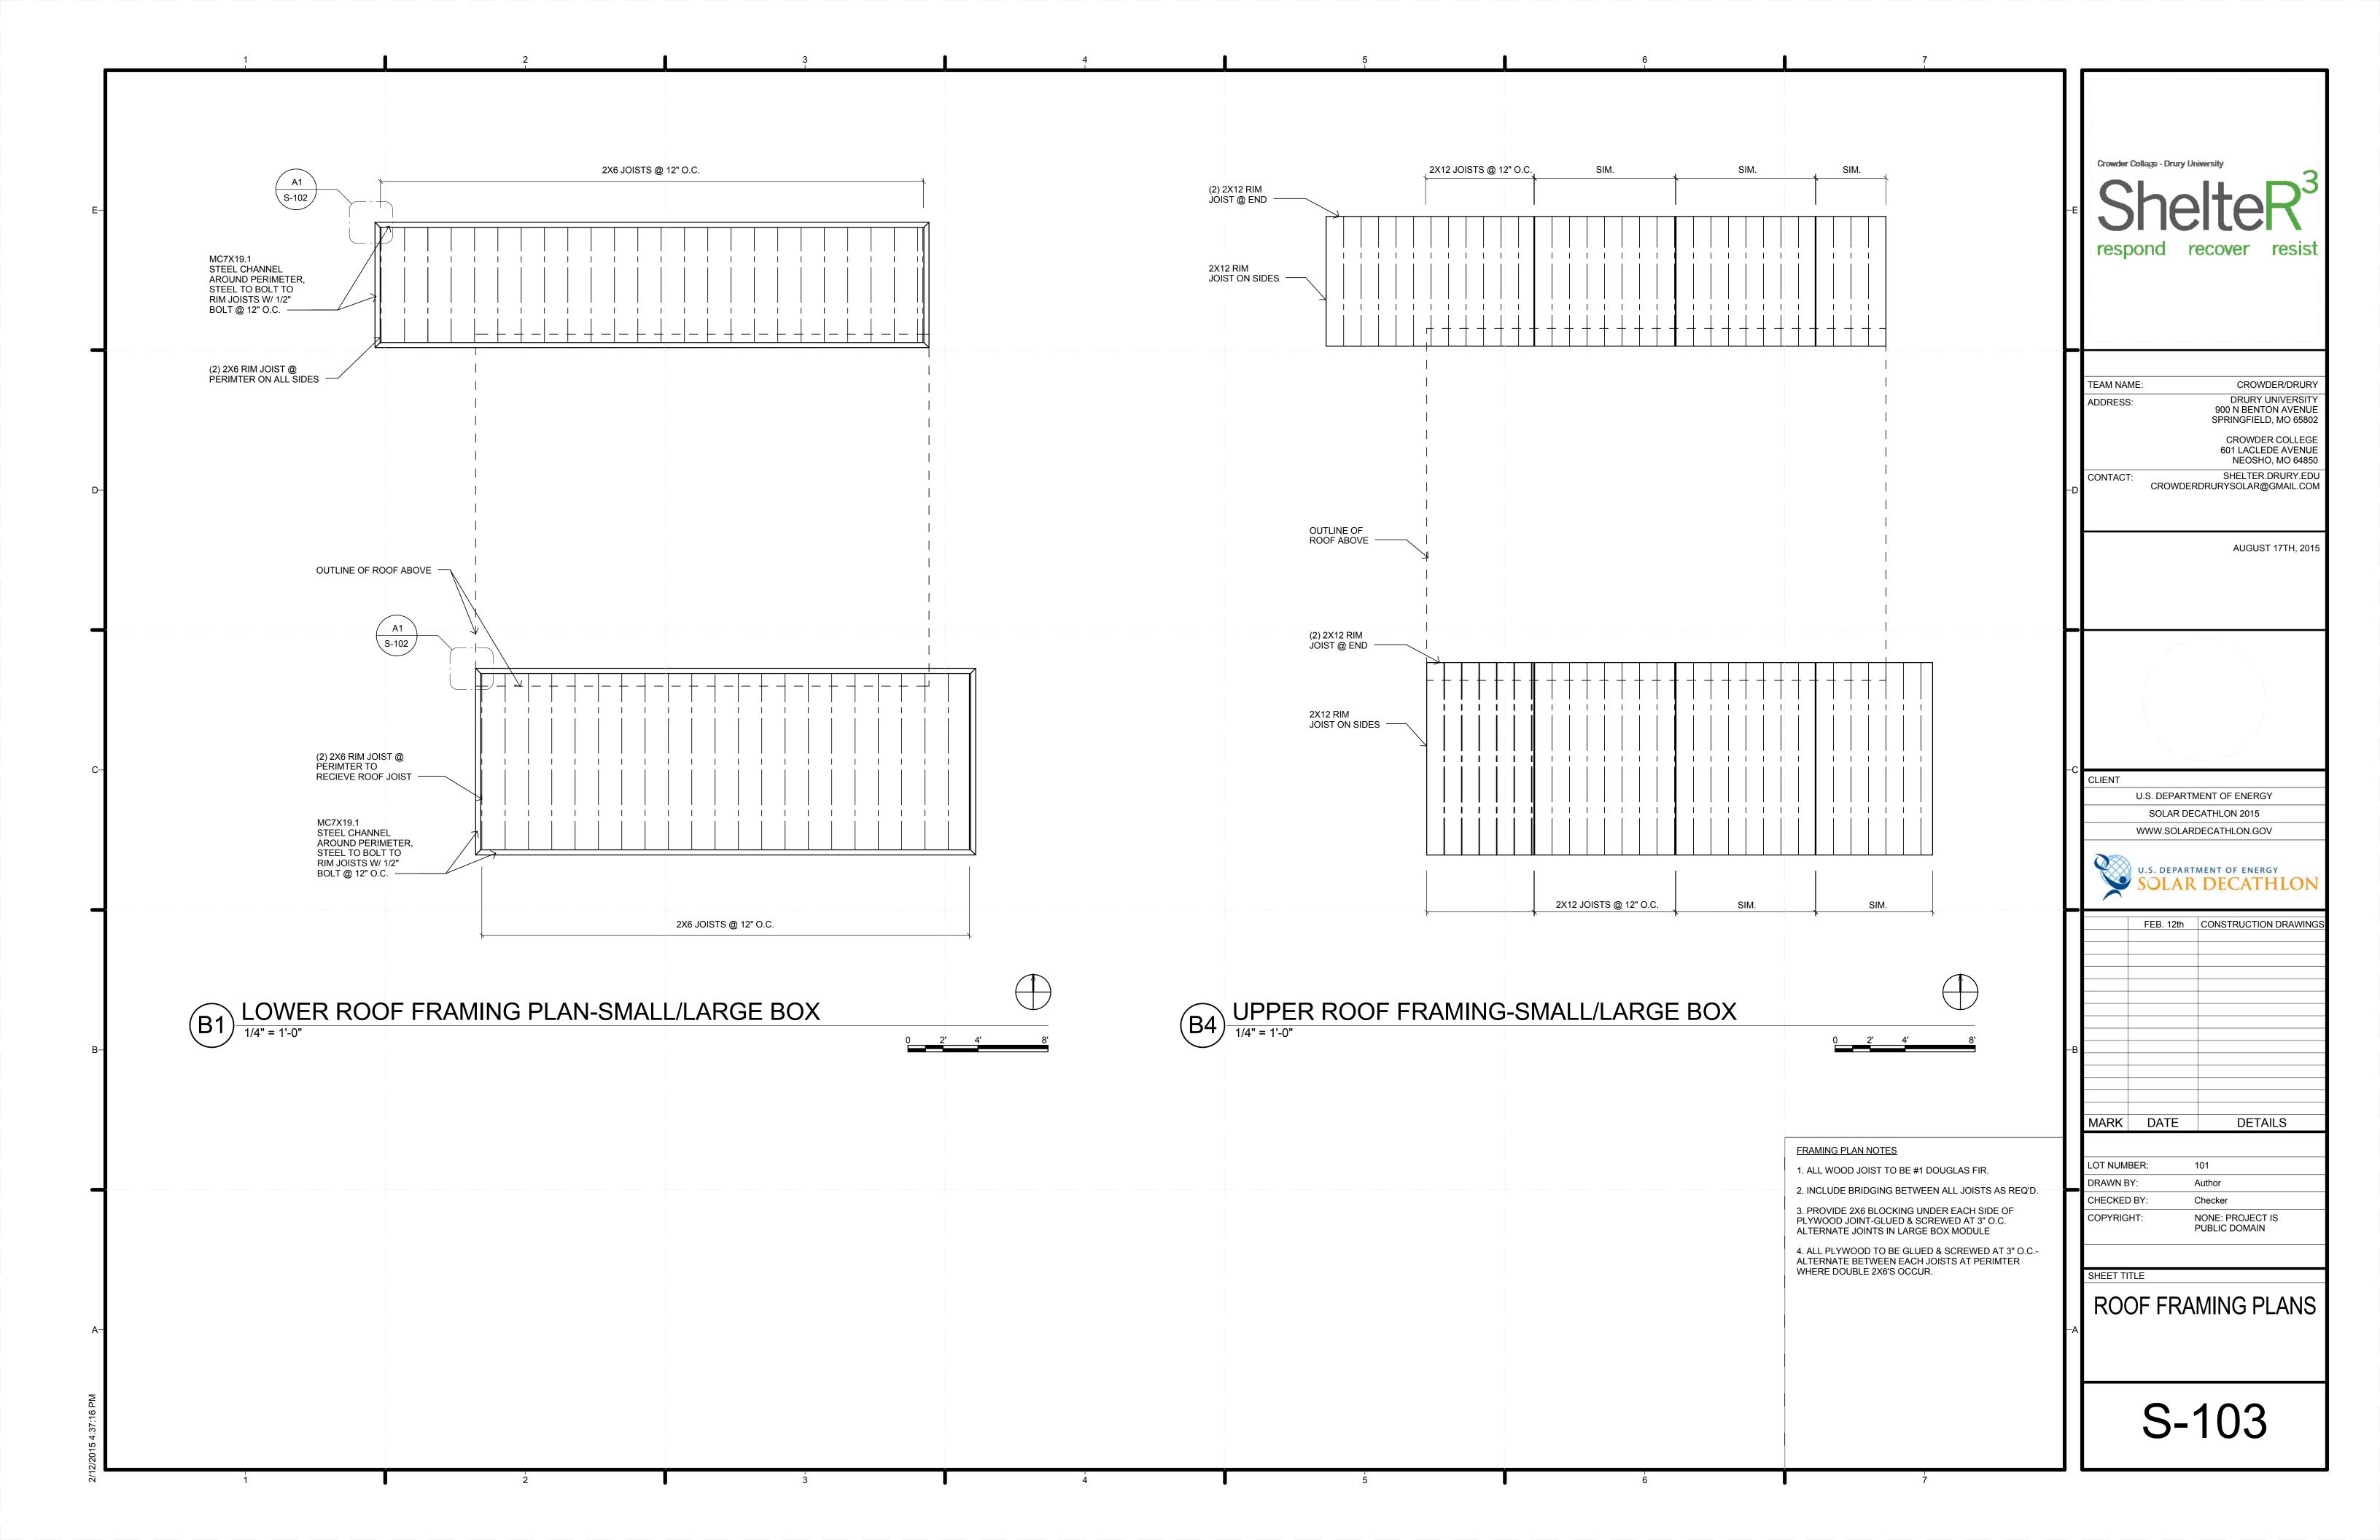


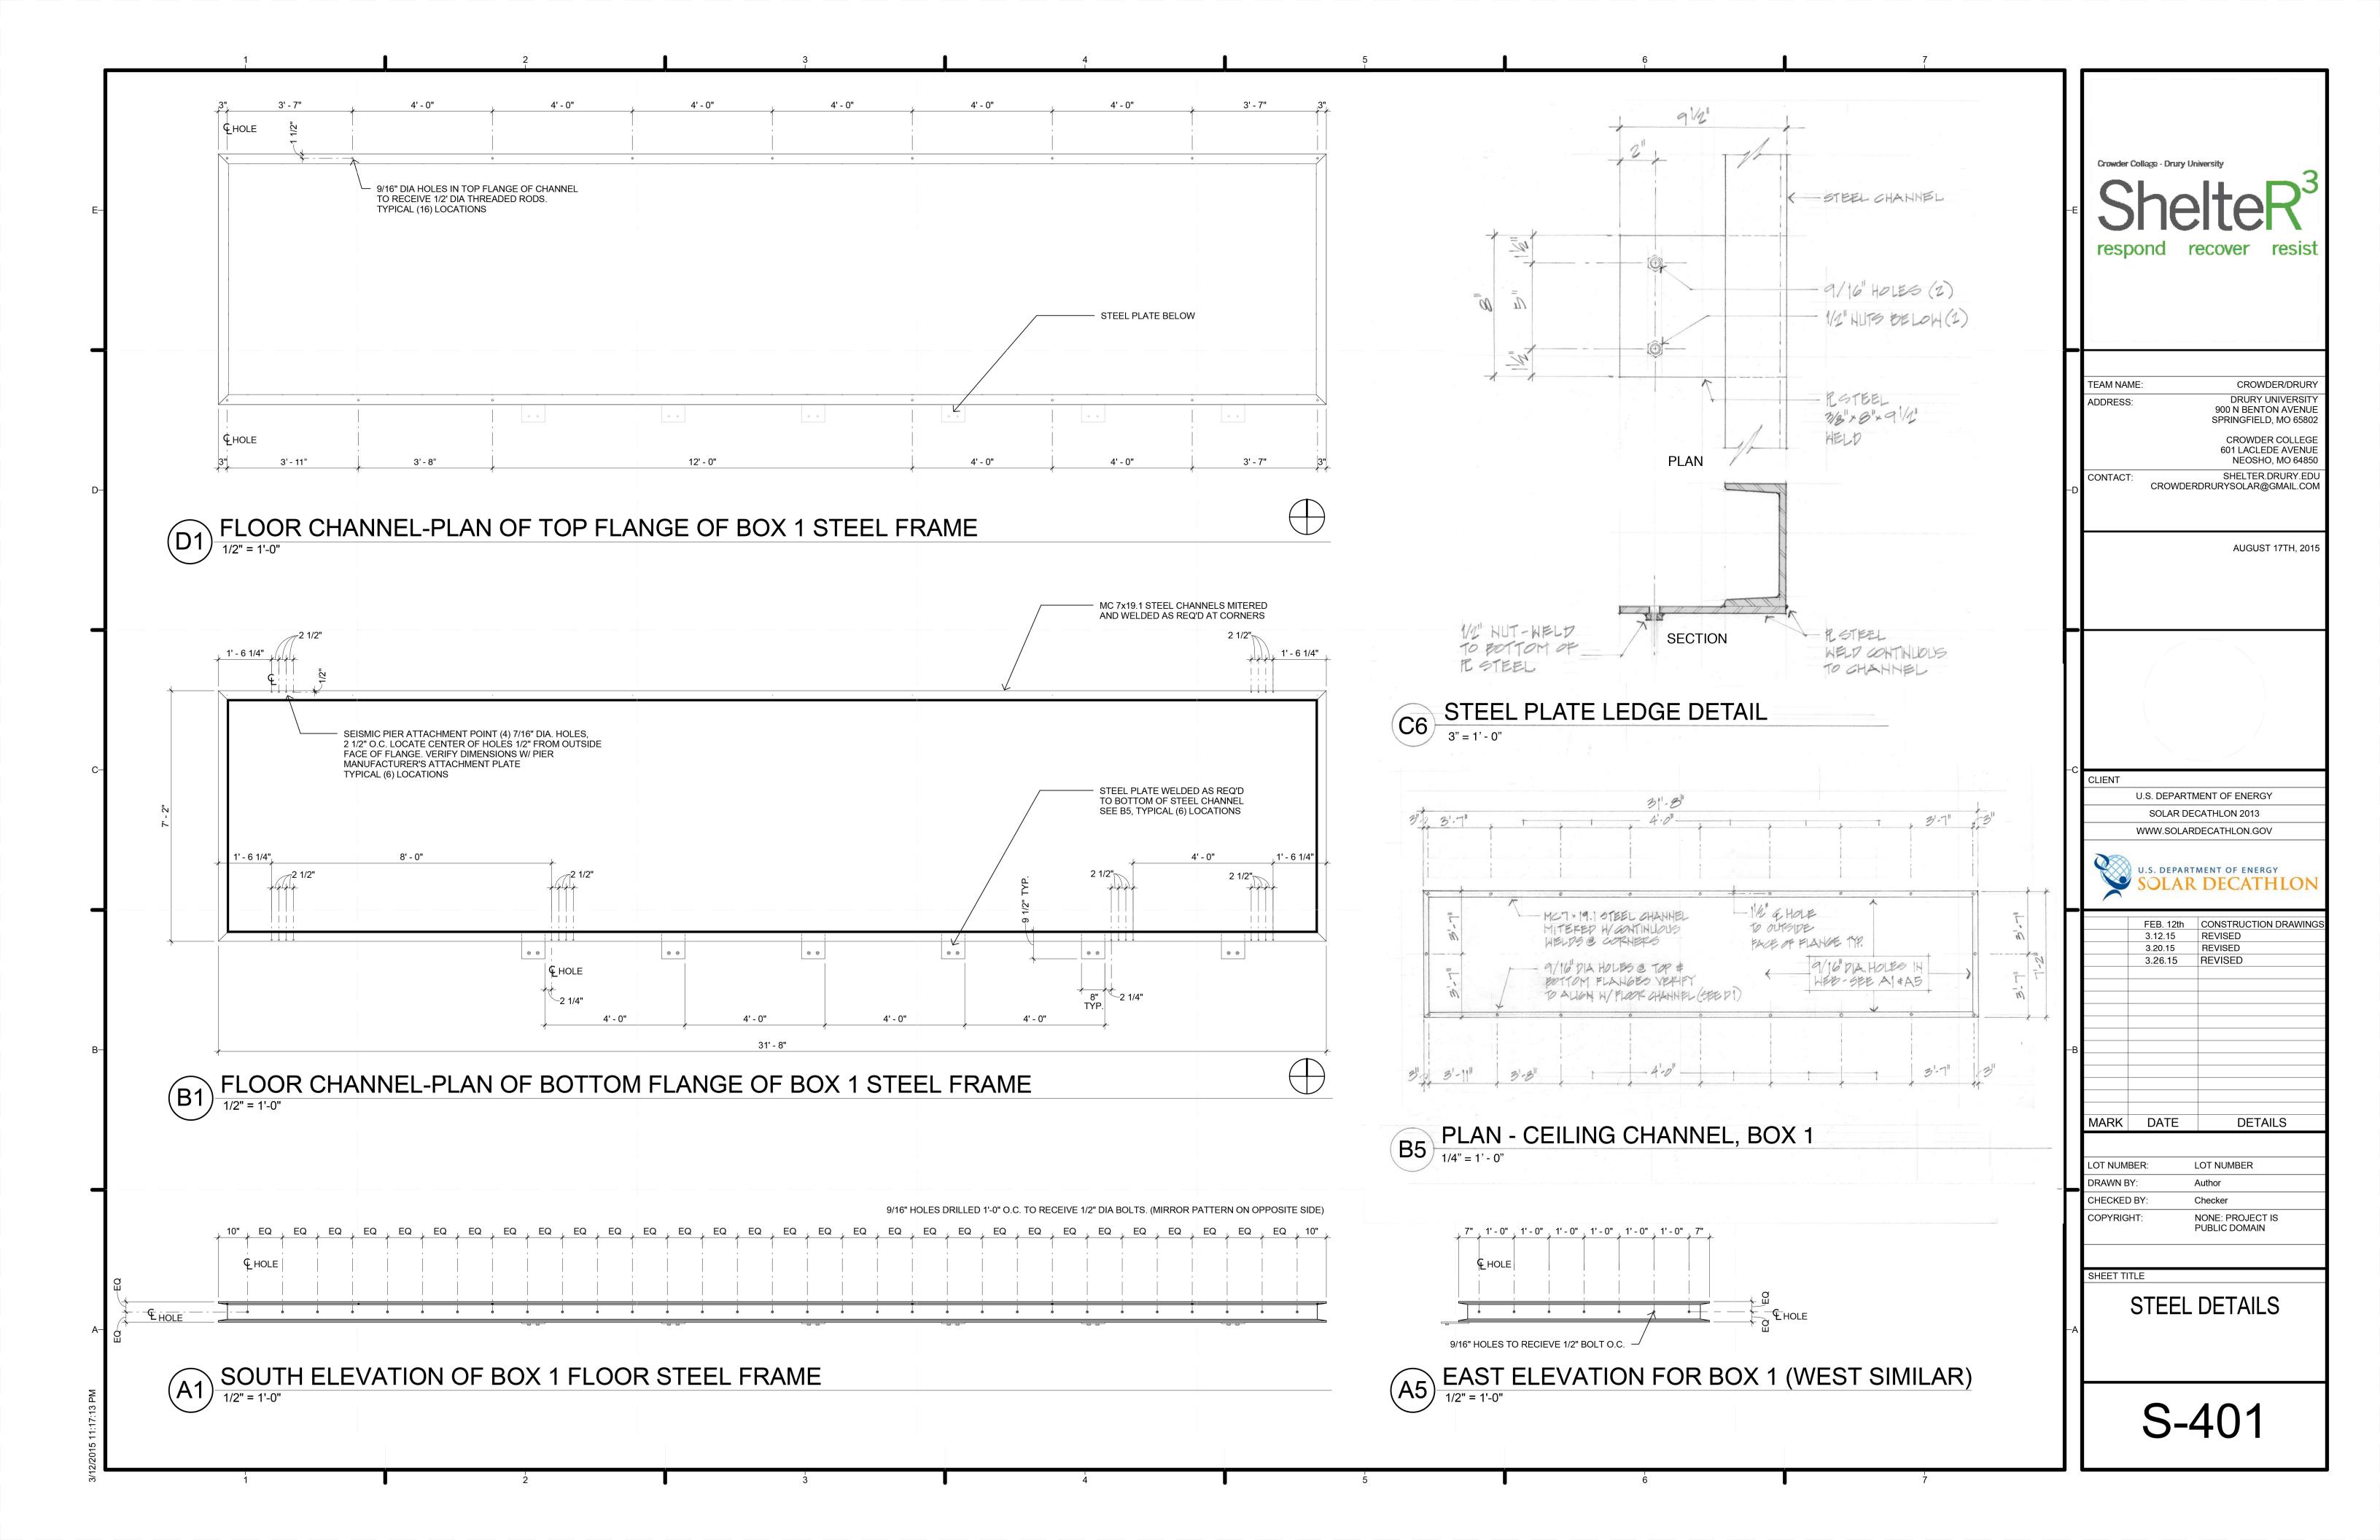


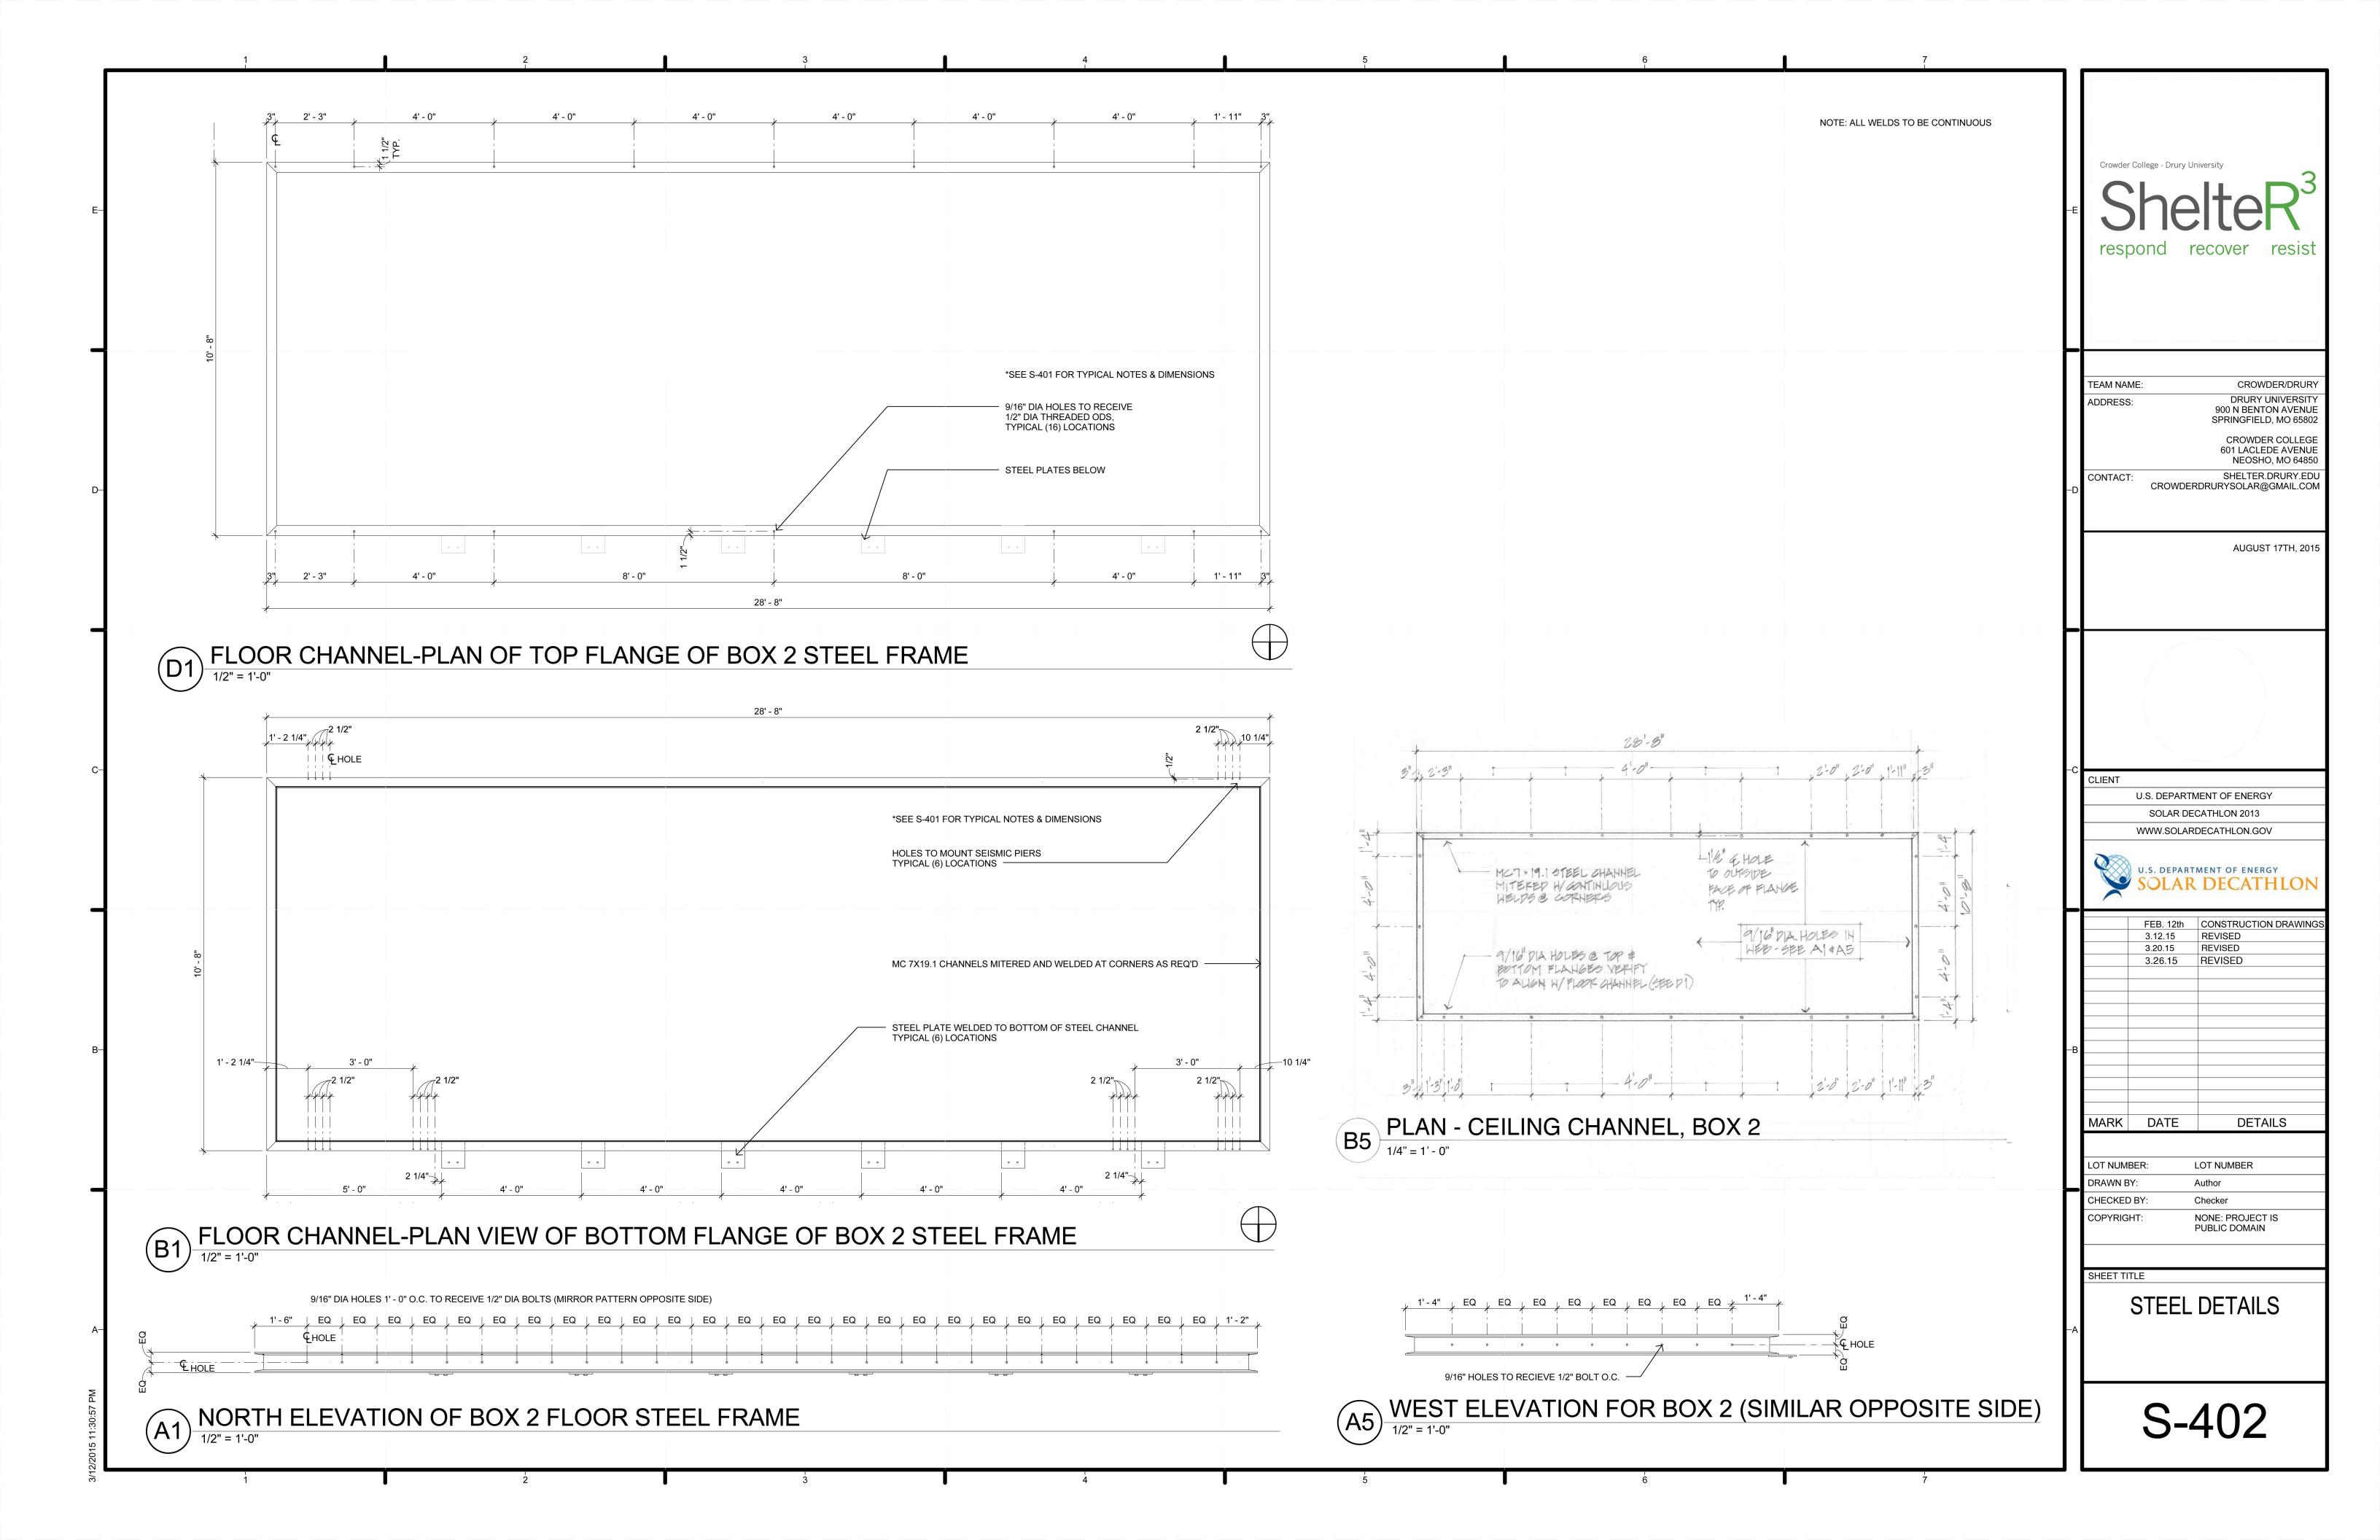


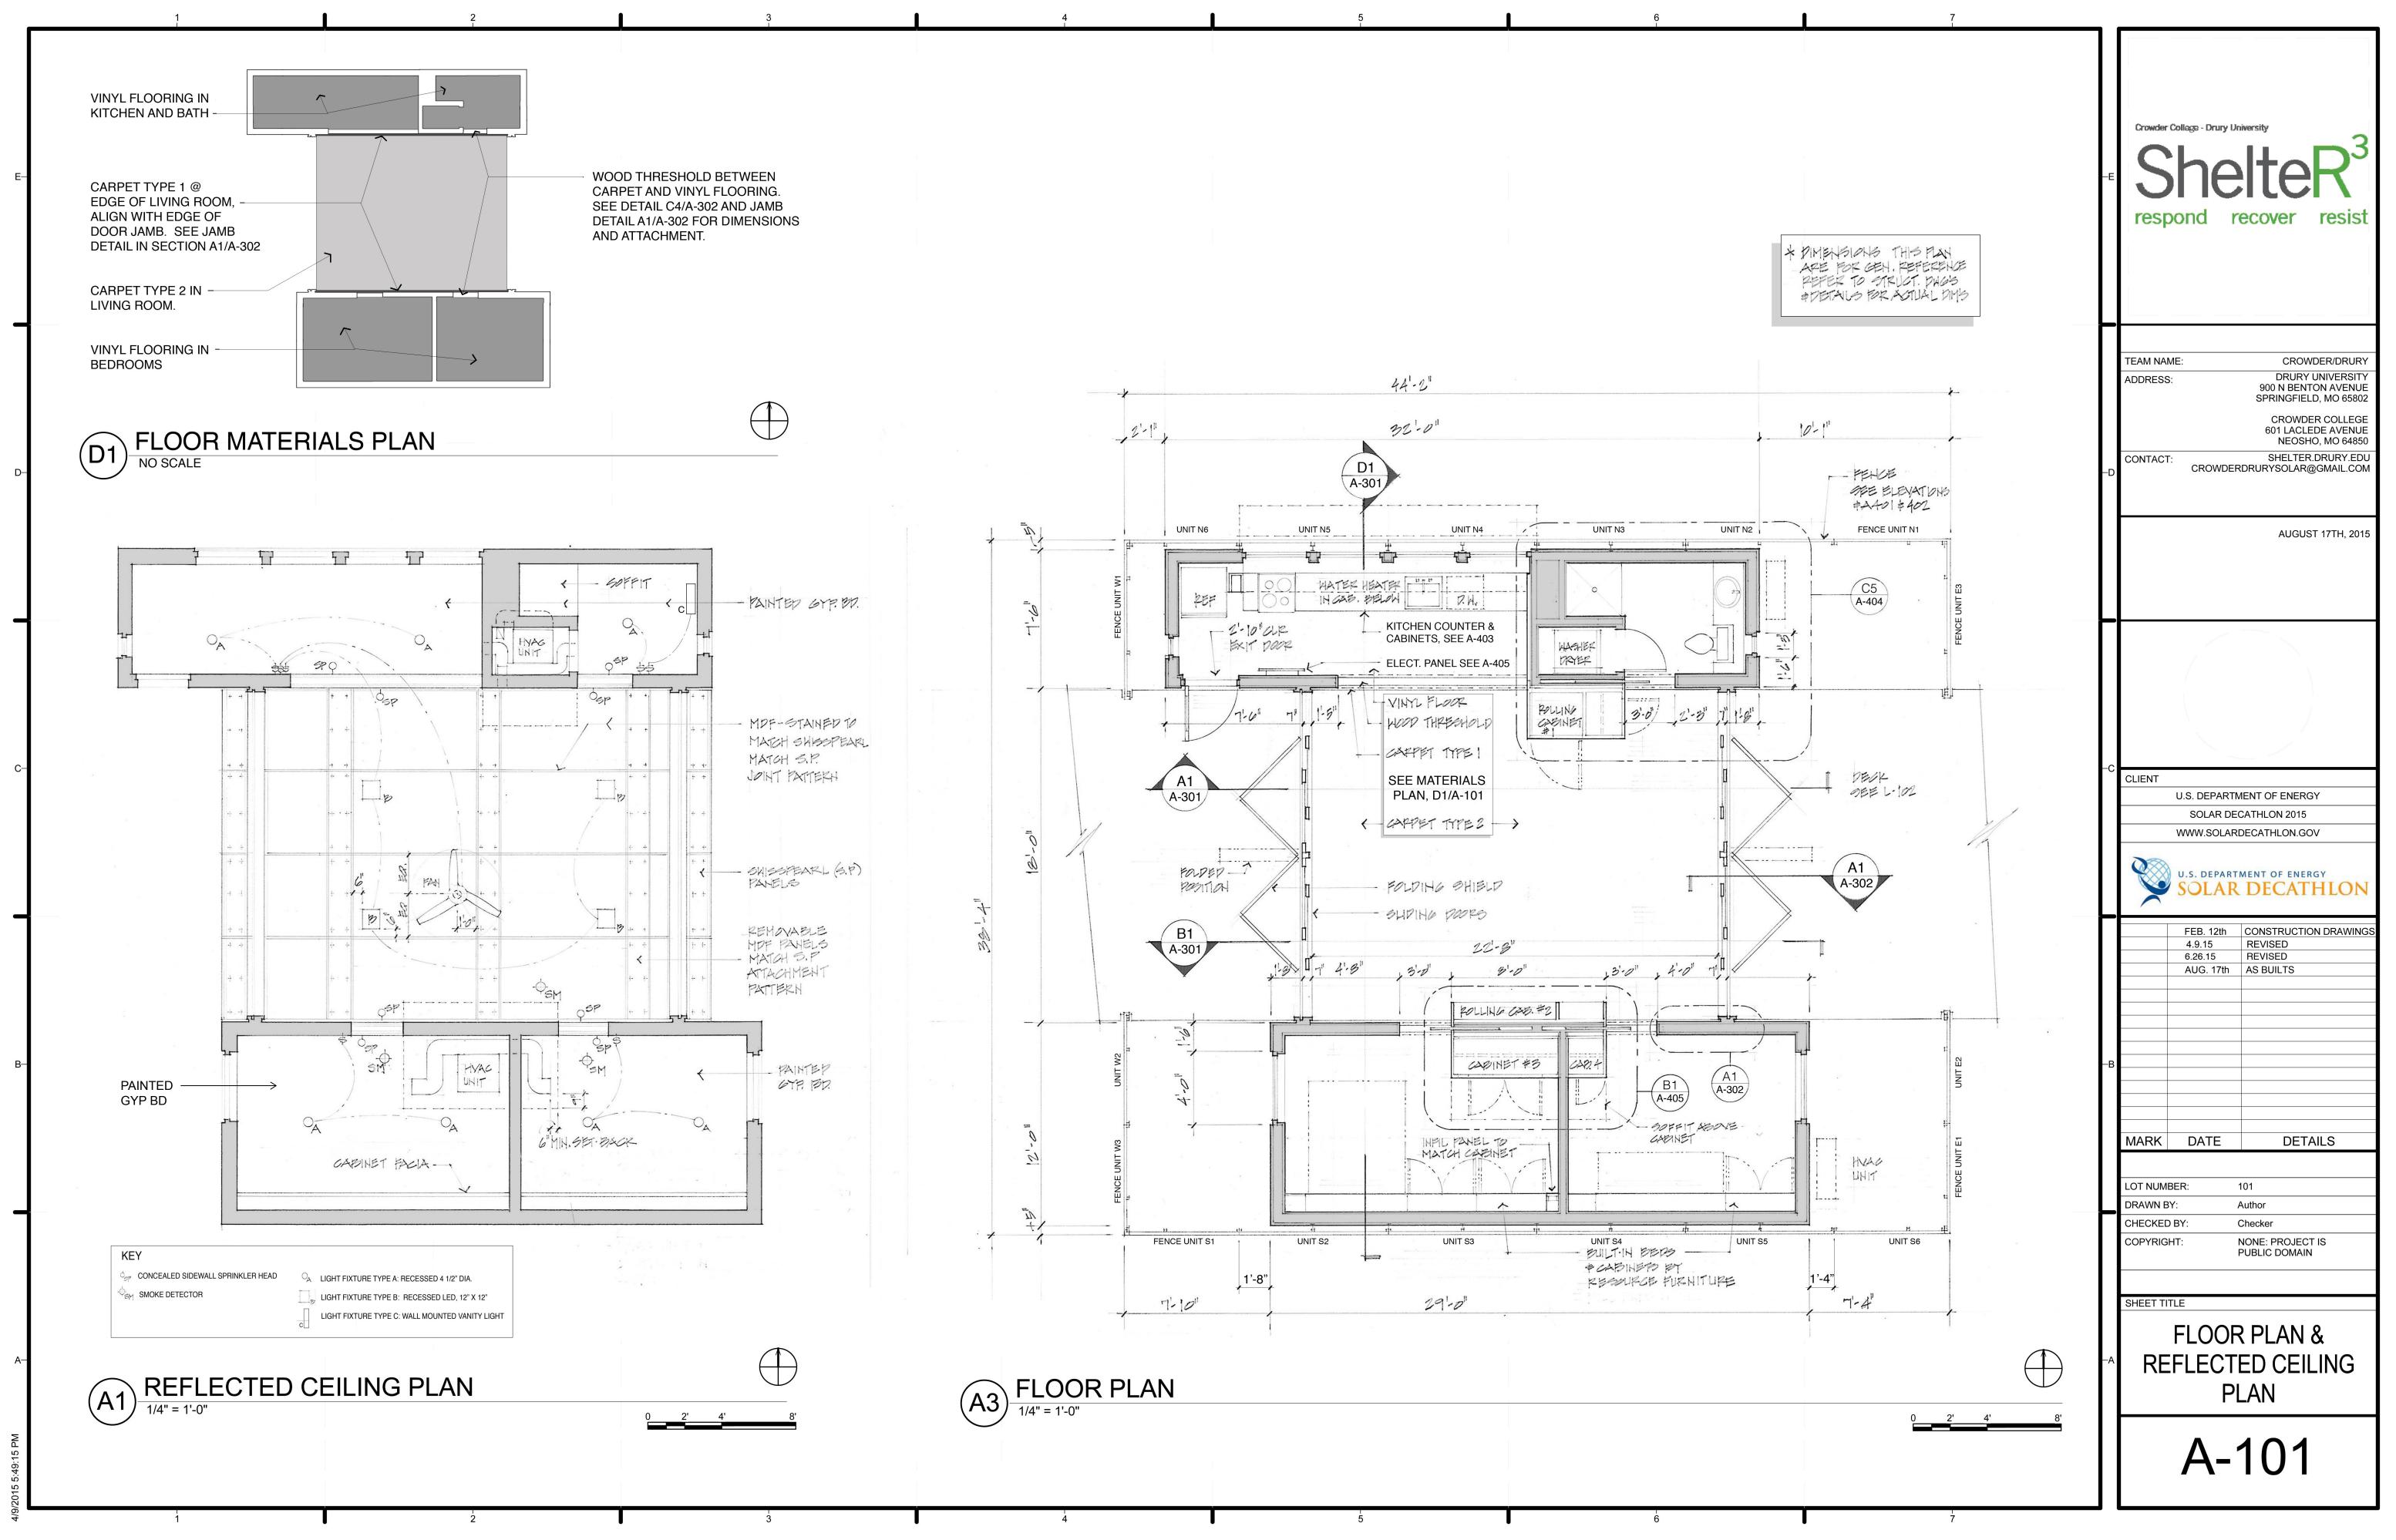

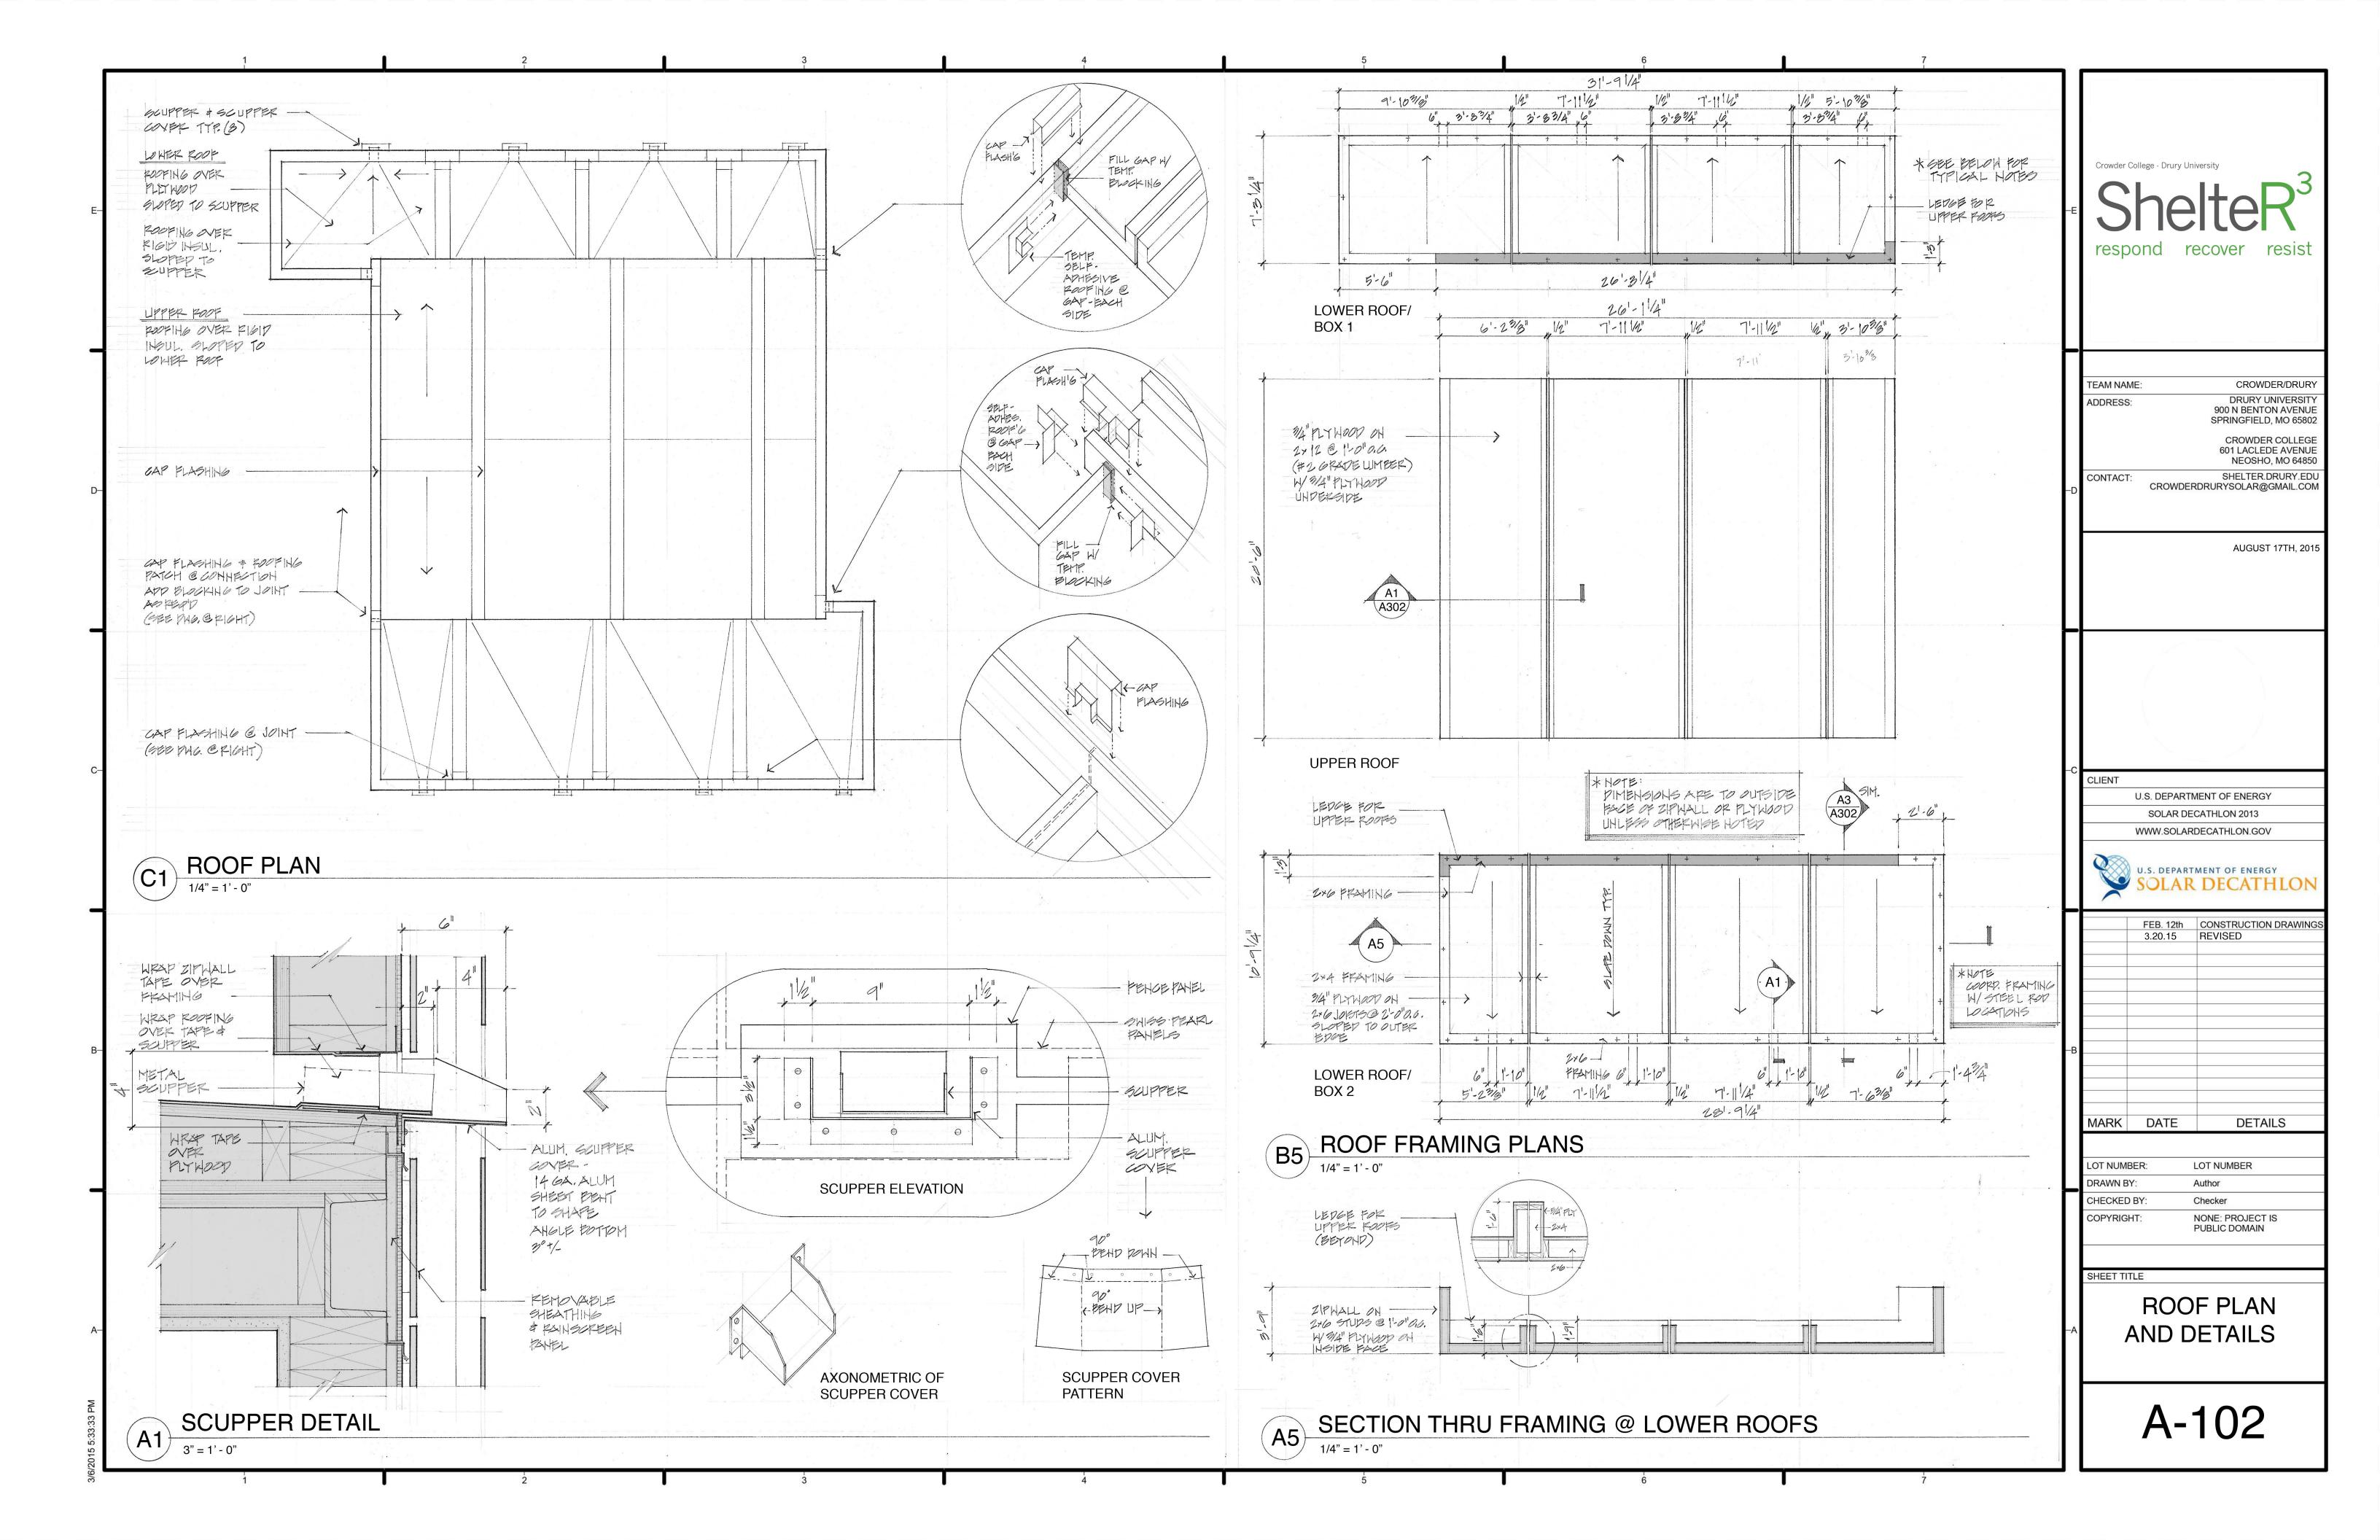

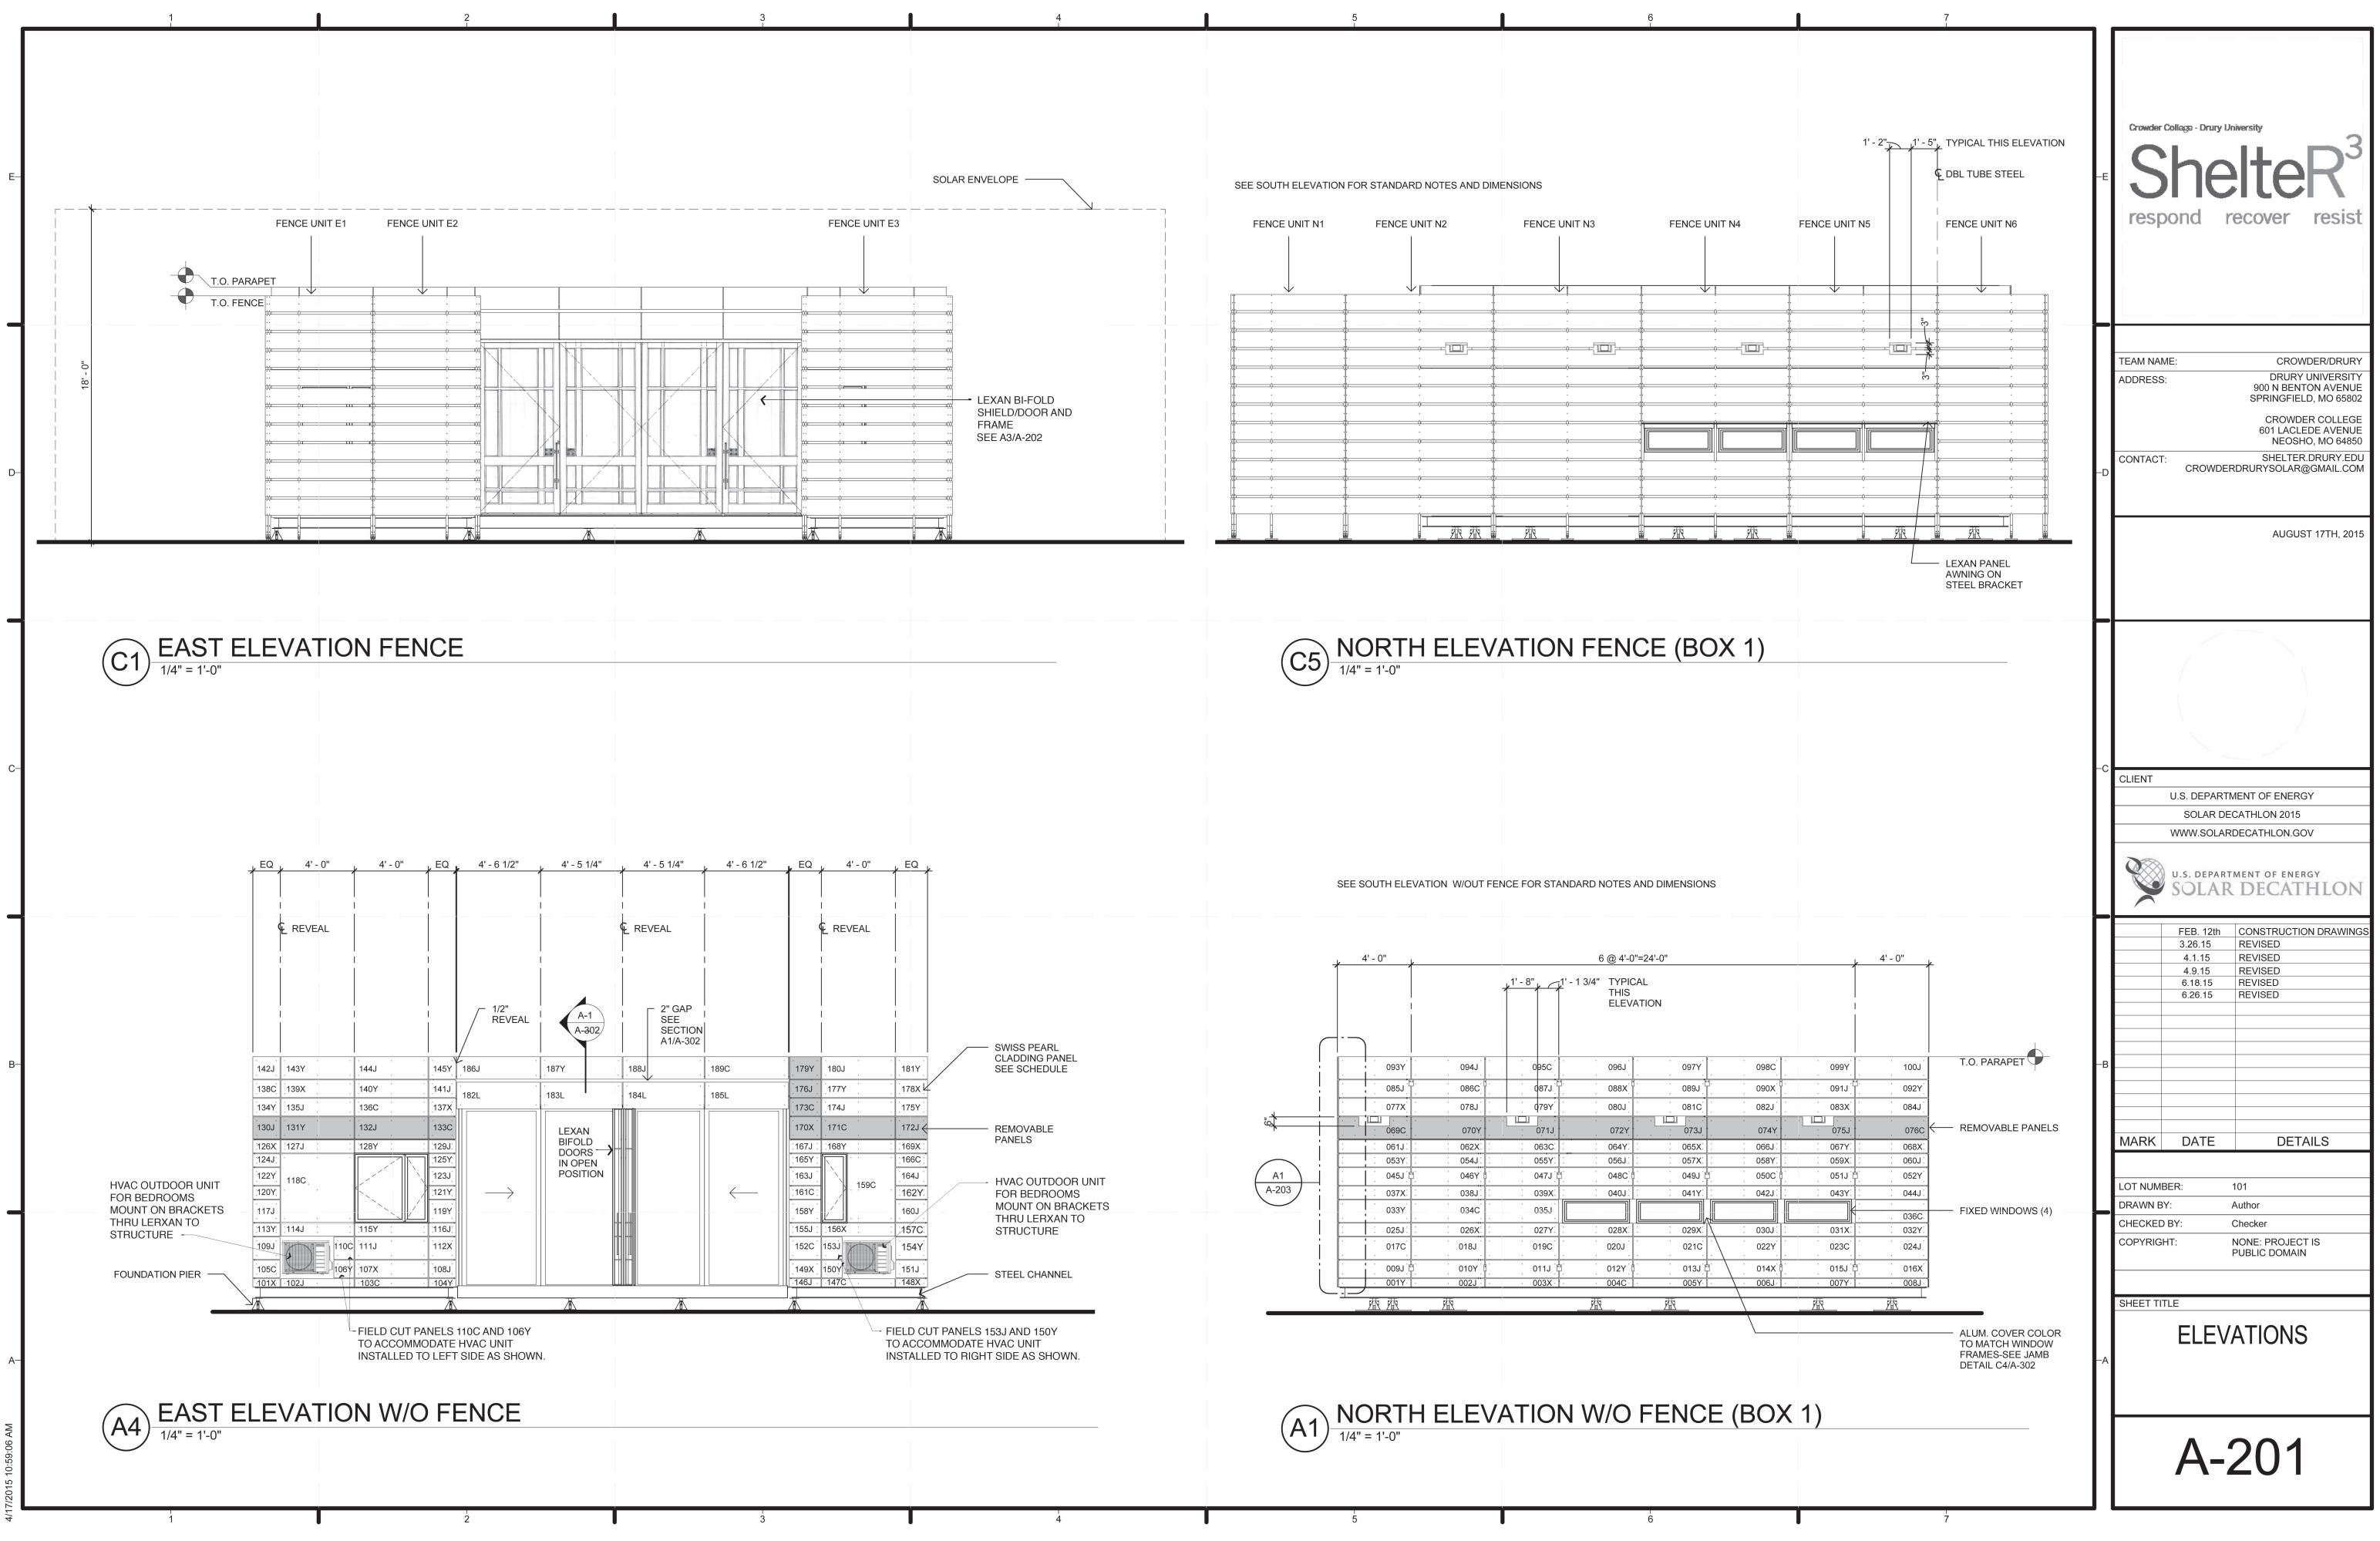


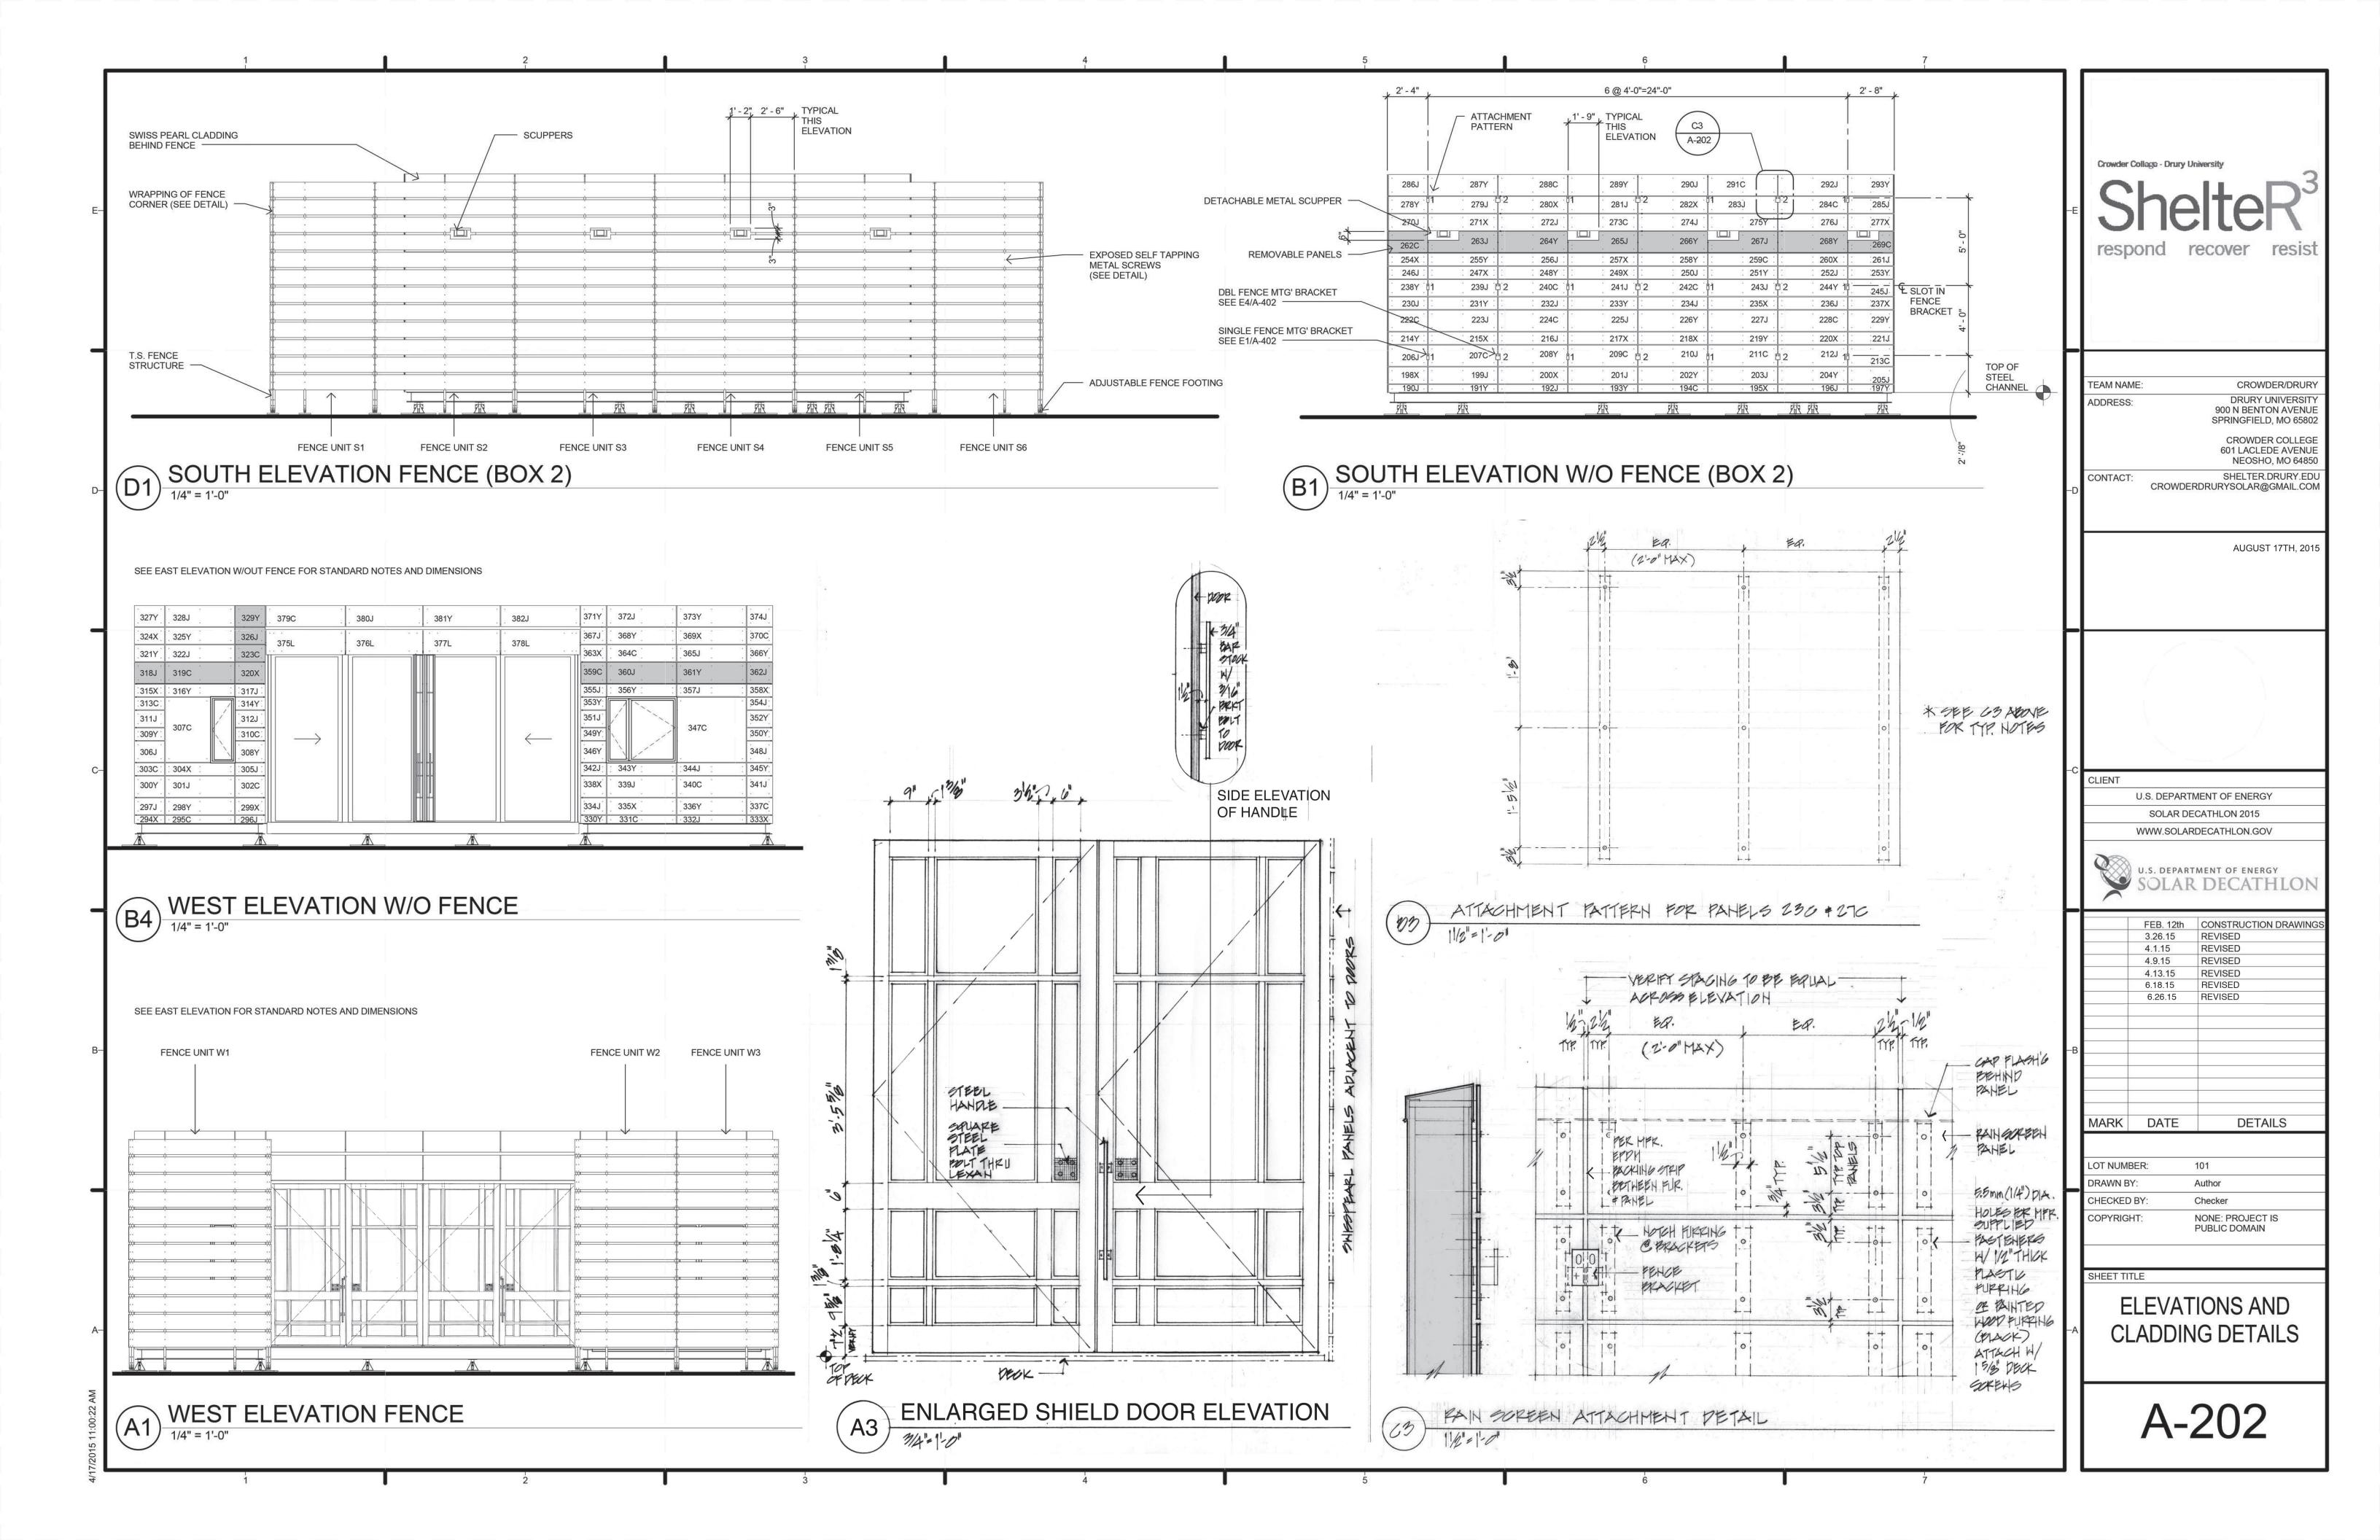

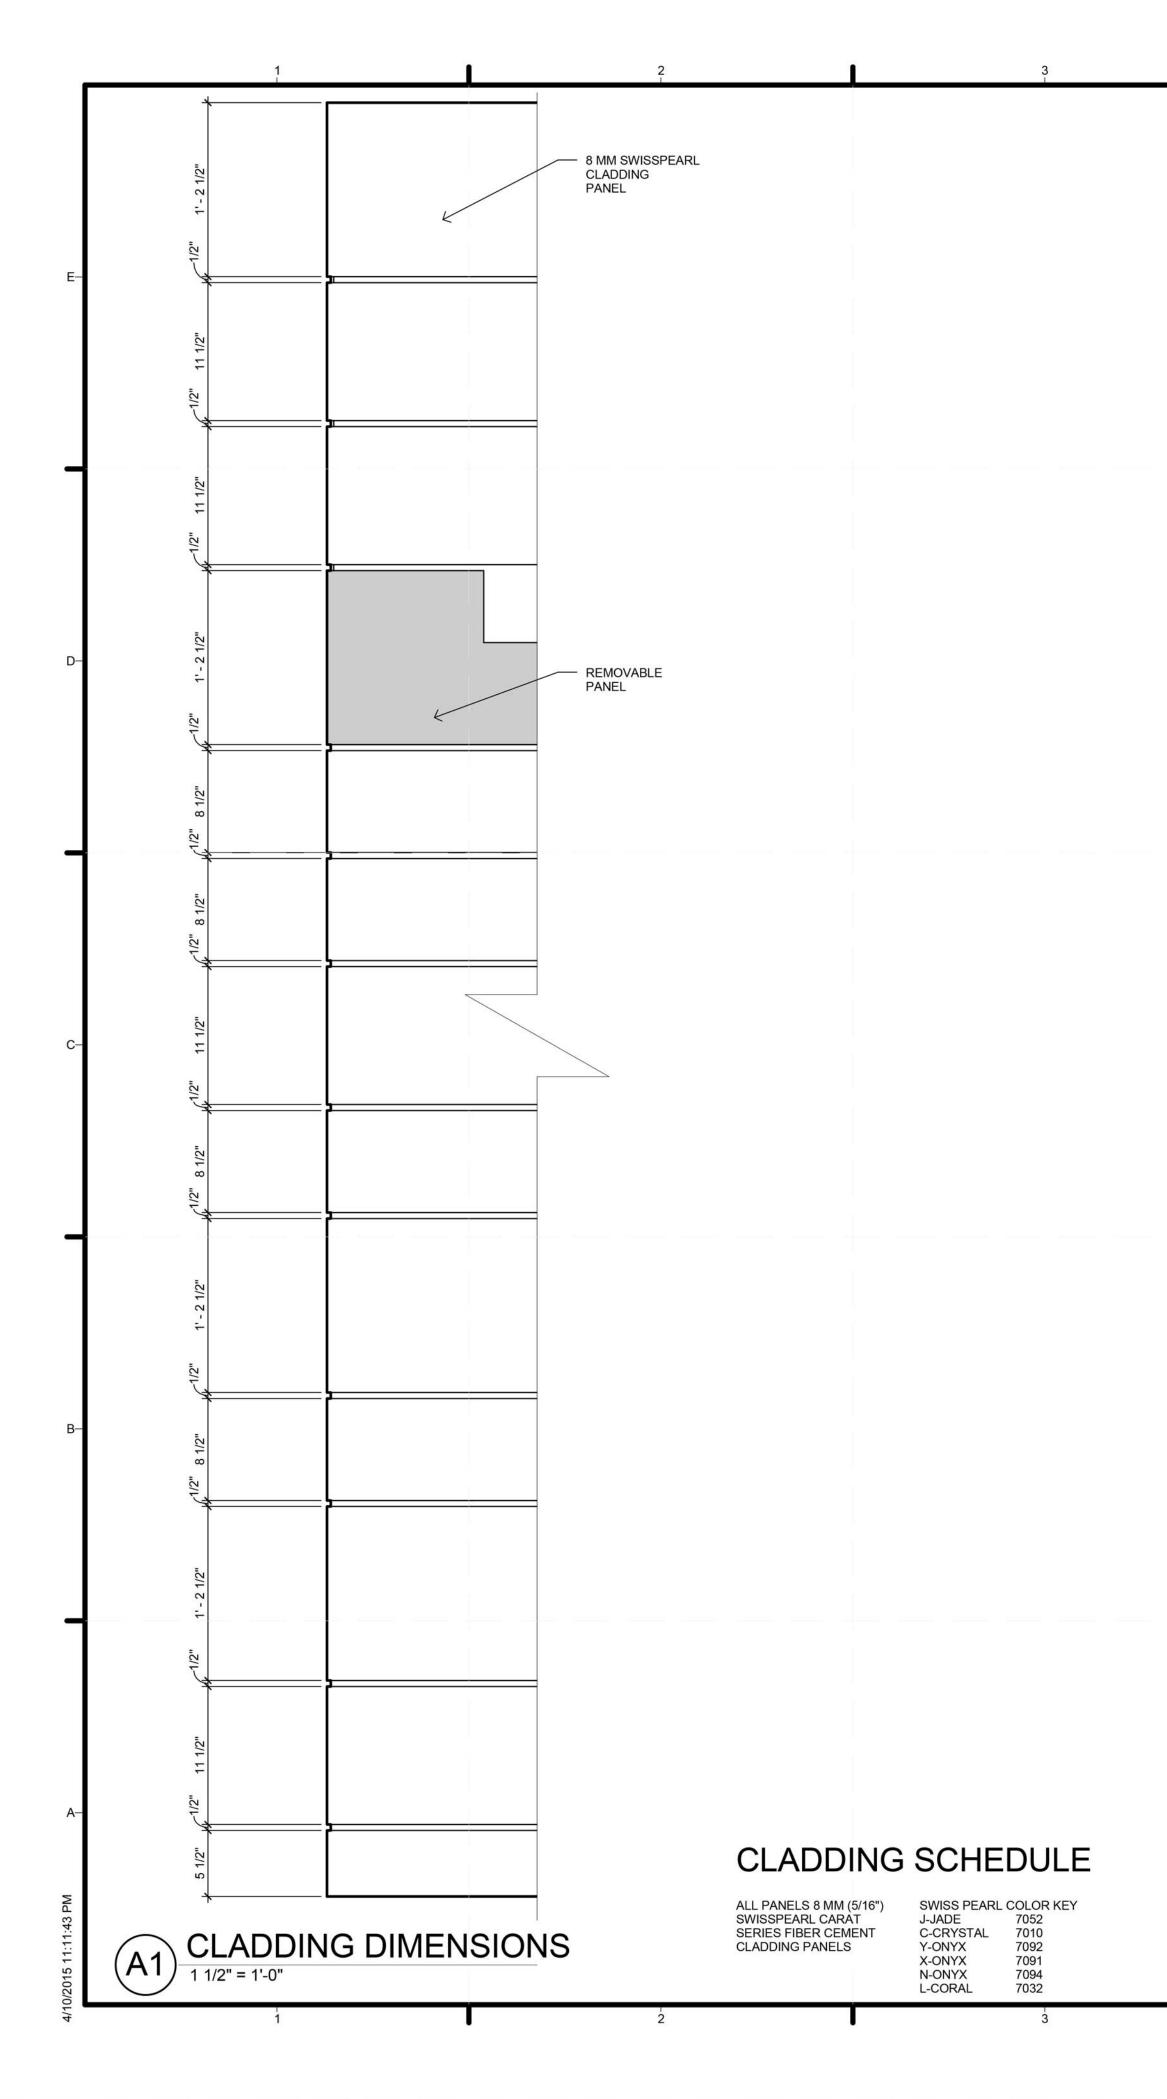


		4	1			5					6
part #         sub-assembly           A1-201-001Y	7092 5	h length color 5.5 46.75 Y 5.5 47.5 J	<b>part #</b> A4-201-140Y A4-201-141J	sub-assembly         id #           7092         7052	width 11.5 11.5	length         color           47.5         Y           17.75         J	<b>part #</b> B1-202-279J B1-202-280)	sub-assembly	id # w 7052 7091	vidth   11.5 11.5	47.5 47.5
A1-201-0023 A1-201-003X A1-201-004C A1-201-005Y	7091 5 7010 5	5.5         47.5         J           5.5         47.5         X           5.5         47.5         C           5.5         47.5         Y	A4-201-1413 A4-201-142J A4-201-143Y A4-201-144J	ATTACHMENT 7052 ATTACHMENT 7092 ATTACHMENT 7052	14.5	17.75 J 17.75 J 47.5 Y 47.5 J	B1-202-280/ B1-202-281/ B1-202-282/ B1-202-283/		7052 7091 7052	11.5 11.5 11.5 11.5	47.5
A1-201-006J A1-201-007Y A1-201-008J	7052 5 7092 5	5.5 47.5 J 5.5 47.5 Y 5.5 46.75 J	A4-201-145Y A4-201-146J A4-201-147C	ATTACHMENT 7092 7052 7010	14.5 5.5	17.75 Y 20.75 J 47.5 C	B1-202-2840 B1-202-285J B1-202-286J	ATTACHMENT	7010 7052 7052	11.5 11.5 14.5	47.5 30.75 26.75
A1-201-009J A1-201-010Y A1-201-011J	7052         11           7092         11           7052         11	1.5 46.75 J 1.5 47.5 Y	A4-201-148X A4-201-149X A4-201-150Y	7091 7091 7092		20.75 X 20.75 X 47.5 Y	B1-202-287 B1-202-2880 B1-202-289	ATTACHMENT ATTACHMENT	7092 7010 7092	14.5 14.5 14.5	47.5 47.5 47.5
A1-201-012Y A1-201-013J A1-201-014X	7092         11           7052         11           7091         11	l.5 47.5 J	A4-201-151J A4-201-152C A4-201-153J	7052 7010 7052		20.75 J 20.75 C 47.5 J	B1-202-290. B1-202-2910 B1-202-292.	ATTACHMENT C ATTACHMENT ATTACHMENT	7052 7010 7052	14.5 14.5 14.5	47.5 47.5 47.5
A1-201-015J A1-201-016X A1-201-017C	7052         11           7091         11           7010         14	1.5 46.75 X	A4-201-154Y A4-201-155J A4-201-156X	7092 7052 7091		20.75 Y 20.75 J 47.5 X	B1-202-293) B4-202-294) B4-202-2950	(	7092 7091 7010	14.5 5.5 5.5	30.75 20.75 47.5
A1-201-018J A1-201-019C A1-201-020J	7052         14           7010         14           7052         14	4.5 47.5 C	A4-201-157C A4-201-158Y A4-201-159C	7010 7092 7010	14.5	20.75 C 20.75 Y 30.25 C	B4-202-296J B4-202-297J B4-202-298	,	7052 7052 7092	5.5 11.5 11.5	20.75 20.75 47.5
A1-201-021C A1-201-022Y A1-201-023C	7010         14           7092         14           7010         14	4.5 47.5 Y 4.5 47.5 C	A4-201-160J A4-201-161C A4-201-162Y	7052 7010 7092	8.5 8.5	20.75 J 20.75 C 20.75 Y	B4-202-299) B4-202-300 B4-202-301	,	7091 7092 7052	11.5 14.5 14.5	20.75 20.75 47.5
A1-201-024J A1-201-025J A1-201-026X	7091 8	3.5         46.75         J           3.5         47.5         X	A4-201-163J A4-201-164J A4-201-165Y	7052 7052 7092	11.5 8.5	20.75 J 20.75 J 20.75 Y	B4-202-3020 B4-202-3030 B4-202-304)	3	7010 7010 7091	14.5 8.5 8.5	20.75 20.75 47.5
A1-201-027Y A1-201-028X A1-201-029X	7091 8 7091 8	3.5         47.5         Y           3.5         47.5         X           3.5         47.5         X	A4-201-166C A4-201-167J A4-201-168Y	7010 7052 7092	8.5 8.5	20.75 C 20.75 J 47.5 Y	B4-202-305J B4-202-306J B4-202-3070		7052 7052 7010	8.5 14.5 44.5	20.75 20.75 30.25
A1-201-030J A1-201-031X A1-201-032Y	7091 8 7092 8	3.5         47.5         J           3.5         47.5         X           3.5         46.75         Y	A4-201-169X A4-201-170X A4-201-171C	7091 7091 7010 7010		20.75 X 20.75 X 47.5 C	B4-202-308) B4-202-309) B4-202-3100	·	7092 7092 7010	14.5 8.5 8.5	20.75 20.75 20.75
A1-201-033Y A1-201-034C A1-201-035J	7092         14           7010         14           7052         14	4.5 47.5 C 4.5 47.5 J	A4-201-172J A4-201-173C A4-201-174J	7052 7010 7052 7052	11.5	20.75 J 20.75 C 47.5 J	B4-202-311J B4-202-312J B4-202-3130		7052 7052 7010	11.5 11.5 8.5	20.75 20.75 20.75
A1-201-036C A1-201-037X A1-201-038J A1-201-039X	7052 8	8.5 46.75 X 8.5 47.5 J	A4-201-175Y A4-201-176J A4-201-177Y	7092 7052 7092 7092		20.75 Y 20.75 J 47.5 Y	B4-202-314) B4-202-315) B4-202-316)	,	7092 7091 7092	8.5 8.5 8.5	20.75 20.75 47.5
A1-201-039X A1-201-040J A1-201-041Y A1-201-042J	7052 8 7092 8	3.5         47.5         X           3.5         47.5         J           3.5         47.5         Y           3.5         47.5         J	A4-201-178X A4-201-179Y A4-201-180J A4-201-181Y	7091 ATTACHMENT 7092 ATTACHMENT 7052 ATTACHMENT 7092	14.5 14.5	20.75 X 20.75 Y 47.5 J 20.75 Y	84-202-317J 84-202-318J 84-202-3190 84-202-3200	:	7052 7052 7010 7091	8.5 14.5 14.5 14.5	20.75 20.75 47.5 20.75
A1-201-0423 A1-201-043Y A1-201-044J A1-201-045J	7092 8	3.5 47.5 Y 3.5 46.75 J	A4-201-181Y A4-201-182L A4-201-183L A4-201-184L	7032 7032 7032 7032	15	54.5 L 53.25 L 53.25 L	B4-202-320) B4-202-321) B4-202-3221 B4-202-3230		7091 7092 7052 7010	14.5 11.5 11.5 11.5	20.75 20.75 47.5 20.75
A1-201-0453 A1-201-046Y A1-201-047J A1-201-048C	7032         11           7092         11           7052         11           7010         11	1.5 47.5 Y 1.5 47.5 J	A4-201-184L A4-201-185L A4-201-186J A4-201-187Y	7032           7032           ATTACHMENT           7052           ATTACHMENT           7091	15	54.5 J 53.25 Y	B4-202-323 B4-202-324) B4-202-325) B4-202-325)	(	7091 7092 7052	11.5 11.5 11.5 11.5	20.75 20.75 47.5 20.75
A1-201-049J A1-201-050C A1-201-051J	7010         11           7052         11           7010         11           7052         11	1.5 47.5 J 1.5 47.5 C	A4-201-1871 A4-201-188J A4-201-189C B1-202-190J	ATTACHMENT 7031 ATTACHMENT 7052 ATTACHMENT 7010 7052	14.5 14.5	53.25 J 53.25 J 54.5 C 26.75 J	B4-202-3203 B4-202-327) B4-202-3283 B4-202-329)	ATTACHMENT	7092 7052 7092	14.5 14.5 14.5	20.75 20.75 47.5 20.75
A1-201-0517 A1-201-052Y A1-201-053Y A1-201-054J	7092 11 7092 8		B1-202-1937 B1-202-191Y B1-202-192J B1-202-193Y	7032 7092 7052 7052	5.5 5.5	47.5 Y 47.5 J 47.5 Y	B4-202-332 B4-202-330 B4-202-3310 B4-202-332	·	7092 7092 7010 7052	5.5 5.5 5.5	17.75 47.5 47.5
A1-201-055Y A1-201-056J A1-201-057X	7092 8 7052 8	3.5         47.5         Y           3.5         47.5         J           3.5         47.5         X	B1-202-194C B1-202-195X B1-202-196J	7010 7091 7052	5.5 5.5	47.5 C 47.5 X 47.5 J	B4-202-333) B4-202-334J B4-202-335)		7091 7052 7091	5.5 11.5 11.5	17.75 17.75 47.5
A1-201-058Y A1-201-059X A1-201-060J	7092 8 7091 8	3.5         47.5         Y           3.5         47.5         X           3.5         46.75         J	B1-202-197Y B1-202-198X B1-202-199J	7092 7091 7052	5.5 11.5	30.75 Y 26.75 X 47.5 J	B4-202-336 B4-202-337 B4-202-338)	(	7092 7091 7091	11.5 11.5 14.5	47.5 17.75 17.75
A1-201-061J A1-201-062X A1-201-063C	7091 8	3.5         46.75         J           3.5         47.5         X           3.5         47.5         C	B1-202-200X B1-202-201J B1-202-202Y	7091 7052 7092	11.5 11.5 11.5	47.5 X 47.5 J 47.5 Y	B4-202-339J B4-202-3400 B4-202-341J	2	7052 7010 7052	14.5 14.5 14.5	47.5 47.5 17.75
A1-201-064Y A1-201-065X A1-201-066J	7091 8	3.5         47.5         Y           3.5         47.5         X           3.5         47.5         J	B1-202-203J B1-202-204Y B1-202-205J	7052 7092 7052	11.5 11.5 11.5	47.5 J 47.5 Y 30.75 J	B4-202-342J B4-202-343 B4-202-344J	6	7052 7092 7052	8.5 8.5 8.5	17.75 40.75 40.75
A1-201-067Y A1-201-068X A1-201-069C NOTCHED	7091 8 7010 14		B1-202-206J B1-202-207C B1-202-208Y	7052 7010 7092	14.5 14.5	26.75 J 47.5 C 47.5 Y	B4-202-345 B4-202-346 B4-202-3470		7092 7092 7010	8.5 14.5 44.5	17.75 17.75 47.5
A1-201-070Y A1-201-071J NOTCHED A1-201-072Y	7092         14           7052         14           7092         14	47.5 J 4.5 47.5 Y	B1-202-209C B1-202-210J B1-202-211C	7010 7052 7010		47.5 C 47.5 J 47.5 C	B4-202-348J B4-202-349) B4-202-350)		7052 7092 7092	14.5 8.5 8.5	17.75 17.75 17.75
A1-201-073J NOTCHED A1-201-074Y A1-201-075J NOTCHED A1-201-076C	7052         14           7092         14           7052         14           7050         14           7010         14	4.5 47.5 Y 4.5 47.5 J	B1-202-212J B1-202-213C B1-202-214Y B1-202-215X	7052 7010 7092 7091	14.5 14.5 8.5 8.5	47.5 J 30.75 C 26.75 Y 47.5 X	B4-202-351J B4-202-352 B4-202-353 B4-202-354J		7052 7092 7092 7052	11.5 11.5 8.5 8.5	17.75 17.75 17.75 17.75
A1-201-0708 A1-201-077X A1-201-078J A1-201-079Y	7010         11           7091         11           7052         11           7092         11	1.5 46.75 X 1.5 47.5 J	B1-202-213X B1-202-216J B1-202-217X B1-202-218X	7051 7052 7091 7091	8.5 8.5	47.5 X 47.5 X 47.5 X	B4-202-355J B4-202-355J B4-202-356V B4-202-357J	,	7052 7052 7092 7052	8.5 8.5 8.5 8.5	17.75 17.75 47.5 47.5
A1-201-080J A1-201-080J A1-201-081C A1-201-082J	7052         11           7052         11           7010         11           7052         11	1.5 47.5 J 1.5 47.5 C	B1-202-219Y B1-202-220X B1-202-221J	7092 7091 7052	8.5 8.5	47.5 Y 47.5 X 30.75 J	B4-202-358) B4-202-3590 B4-202-3600		7091 7010 7052	8.5 14.5 14.5	17.75 17.75 47.5
A1-201-083X A1-201-084J A1-201-085J	7091 11 7052 11 7052 11	L.5 46.75 J	B1-202-222C B1-202-223J B1-202-224C	7010 7052 7010	14.5	26.75 C 47.5 J 47.5 C	B4-202-361 B4-202-362 B4-202-363		7092 7052 7091	14.5 14.5 11.5	47.5 17.75 17.75
A1-201-086C A1-201-087J A1-201-088X	701011705211709111	L.5 47.5 J	B1-202-225J B1-202-226Y B1-202-227J	7052 7092 7052	14.5 14.5 14.5	47.5 J 47.5 Y 47.5 J	B4-202-3640 B4-202-365J B4-202-3665		7010 7052 7092	11.5 11.5 11.5	47.5 47.5 17.75
A1-201-089J A1-201-090X A1-201-091J	7052         11           7091         11           7052         11	1.5 47.5 X	B1-202-228C B1-202-229Y B1-202-230J	7010 7092 7052	14.5 8.5	47.5 C 30.75 Y 26.75 J	B4-202-367 B4-202-368 B4-202-369		7052 7092 7091	11.5 11.5 11.5	17.75 47.5 47.5
A1-201-092Y A1-201-093Y ATTACHMENT A1-201-094J ATTACHMENT	7092         11           7092         14           7052         14	4.5 46.75 Y 4.5 47.5 J	B1-202-231Y B1-202-232J B1-202-233Y	7092 7052 7092	8.5 8.5	47.5 Y 47.5 J 47.5 Y	B4-202-3700 B4-202-3711 B4-202-372	ATTACHMENT ATTACHMENT	7010 7092 7052	11.5 14.5 14.5	17.75 17.75 47.5
A1-201-095C         ATTACHMENT           A1-201-096J         ATTACHMENT           A1-201-097Y         ATTACHMENT	7010         14           7052         14           7092         14	4.5 47.5 J 4.5 47.5 Y	B1-202-234J B1-202-235X B1-202-236J	7052 7091 7052	8.5 8.5	47.5 J 47.5 X 47.5 J	B4-202-373) B4-202-374J B4-202-375J	ATTACHMENT ATTACHMENT	7092 7052 7032	14.5 14.5 15	47.5 17.75 54.5
A1-201-098C ATTACHMENT A1-201-099Y ATTACHMENT A1-201-100J ATTACHMENT	7010         14           7092         14           7052         14	4.5 47.5 Y 4.5 46.75 J	B1-202-237X B1-202-238Y B1-202-239J	7091 7092 7052	8.5 11.5 11.5	30.75 X 26.75 Y 47.5 J	B4-202-3761 B4-202-3771 B4-202-3781		7032 7032 7032	15 15 15 14.5	53.25 53.25 54.5
A4-201-101X A4-201-102J A4-201-103C A4-201-104Y	7052 5 7010 5	5.5 17.75 X 5.5 47.5 J 5.5 47.5 C 5.5 17.75 Y	B1-202-240C B1-202-241J B1-202-242C B1-202-243J	7010 7052 7010 7052		47.5 C 47.5 J 47.5 C 47.5 J	B4-202-3790 B4-202-380J B4-202-381J B4-202-382J	ATTACHMENT	7010 7052 7092 7052	14.5 14.5 14.5 14.5	54.5 53.25 53.25 54.5
A4-201-105C A4-201-105C A4-201-106Y A4-201-107X	7032         3           7010         11           7092         11           7091         11	L.5 17.75 C L.5 47.5 Y	B1-202-2443 B1-202-244Y B1-202-245J B1-202-246J	7032 7092 7052 7052	11.5 11.5 11.5 8.5	47.5 Y 30.75 J 26.75 J	A1-301-383) A1-301-384) A1-301-385)	(	7091 7091 7091	5.5 5.5 5.5	8.625 41.75 10.5
A4-201-108J A4-201-109J A4-201-110C	7051         11           7052         11           7052         14           7010         14	1.5 17.75 J 1.5 17.75 J	B1-202-247X B1-202-248Y B1-202-248Y B1-202-249X	7091 7092 7092 7091	8.5 8.5 8.5	47.5 X 47.5 Y 47.5 X	A1-301-3860 A1-301-3870 A1-301-3880	l	7094 7091 7091	5.5 5.5 5.5	5.75 5.75 18.5
A4-201-111J A4-201-112X A4-201-113Y	7052 14 7091 14	4.5 47.5 J	B1-202-250J B1-202-251Y B1-202-252J	7052 7092 7052	8.5	47.5 J 47.5 Y 47.5 J	A1-301-389 A1-301-390 A1-301-3910	( 	7091 7094 7010	5.5 11.5 11.5	20.5 8.625 41.75
A4-201-114J A4-201-115Y A4-201-116J	7092 8	3.5         47.5         J           3.5         47.5         Y           3.5         17.75         J	B1-202-253Y B1-202-254X B1-202-255Y	7092 7091 7092	8.5 8.5 8.5	30.75 Y 26.75 X 47.5 Y	A1-301-392 A1-301-393 A1-301-394	(	7094 7091 7094	11.5 11.5 11.5	10.5 5.75 5.75
A4-201-117J A4-201-118C A4-201-119Y	7052         14           7010         44           7092         14	4.5 47.5 C	B1-202-256J B1-202-257X B1-202-258Y	7052 7091 7092	8.5 8.5 8.5	47.5 J 47.5 X 47.5 Y	A1-301-3957 A1-301-3967 A1-301-3970	(	7091 7091 7010	11.5 11.5 14.5	18.5 20.5 8.625
A4-201-120Y A4-201-121Y A4-201-122Y		8.5 17.75 Y 8.5 17.75 Y 1.5 17.75 Y	B1-202-259C B1-202-260X B1-202-261J	7010 7091 7052	8.5	47.5 C 47.5 X 30.75 J	A1-301-398 A1-301-399 A1-301-400	(	7094 7091 7091	14.5 14.5 14.5	41.75 10.5 5.75
A4-201-123J A4-201-124J A4-201-125Y	7092 8	8.5 17.75 J 3.5 17.75 Y	B1-202-262C B1-202-263J B1-202-264Y	7010 NOTCHED 7052 7092	14.5 14.5	26.75 C 47.5 J 47.5 Y	A1-301-4012 A1-301-4022 A1-301-4030	1	7091 7094 7010	14.5 14.5 14.5	5.75 18.5 20.5
A4-201-126X A4-201-127J A4-201-128Y	7052 8 7092 8	3.5         17.75         X           3.5         47.5         J           3.5         47.5         Y	B1-202-265J B1-202-266Y B1-202-267J		14.5	47.5 J 47.5 Y 47.5 J	A1-301-4042 A1-301-4050 A1-301-4062		7091 7010 7091	8.5 8.5 8.5	8.625 41.75 10.5
A4-201-129J A4-201-130J A4-201-131Y	7052         8           7052         14           7092         14	3.5         17.75         J           4.5         17.75         J           4.5         47.5         Y	B1-202-268Y B1-202-269C B1-202-270J	7092 NOTCHED 7010 7052	14.5 14.5 11.5	47.5 Y 30.75 C 26.75 J	A1-301-407/ A1-301-408/ A1-301-409/		7094 7094 7091	8.5 8.5 8.5	5.75 5.75 18.5
A4-201-132J A4-201-133C A4-201-134Y	7052         14           7010         14           7092         11           7052         14	4.5 17.75 C 1.5 17.75 Y	B1-202-271X B1-202-272J B1-202-273C	7091 7052 7010	11.5	47.5 X 47.5 J 47.5 C	A1-301-4100 A1-301-4110 A1-301-4122		7094 7010 7091	8.5 14.5 14.5	20.5 8.625 41.75
A4-201-135J A4-201-136C A4-201-137X A4-201-137X	7052         11           7010         11           7091         11           7010         11	1.5 47.5 C 1.5 17.75 X	B1-202-274J B1-202-275Y B1-202-276J B1-202-276J	7052 7092 7052 7052	11.5 11.5	47.5 J 47.5 Y 47.5 J	A1-301-4130 A1-301-4142 A1-301-4152 A1-301-4152	(	7094 7091 7091 7094	14.5 14.5 14.5	10.5 5.75 5.75
A4-201-138C A4-201-139X	7010 11 7091 11	and a second	B1-202-277X B1-202-278Y	7091		30.75 X 26.75 Y	A1-301-416 A1-301-4170		7094 7010	14.5 14.5	18.5 20.5

01-418N 01-419N 01-420X 01-421N 01-421N 01-422X 01-423X 01-423X 01-425N 01-425N 01-426C 01-427X 01-426C 01-427X 01-428X 01-429N 01-430X 01-431N 01-432C 01-433X 01-435N 01-436X 01-426X 01-426X 01-426X	7 7 7 7 7 7 7 7 7 7	7094 7094 7091 7094	8.5 8.5 8.5	8.625 41.75	
-423X -424X -425N -426C -427X -428X -429N -430X -430X -431N -432C -433X -434X -435N -436X	7		8.5	10.5 5.75	X N
426C 427X 428X 429N 430X 431N 432C 433X 433X 435N 436X	7	7091 7091 7091	8.5 8.5 8.5	5.75 18.5 20.5	x x
L-429N L-430X L-431N L-432C L-433X L-433X L-434X L-435N L-436X	7	7094 7010 7091	11.5 11.5 11.5	8.625 41.75 10.5	C X
01-432C 01-433X 01-434X 01-435N 01-435N 01-436X	7	7091 7094 7091	11.5 11.5 11.5	5.75 5.75 18.5	N X
1-435N 1-436X	7	7094 7010 7091	11.5 8.5 8.5	20.5 8.625 41.75	С
	7	7091 7094 7091	8.5 8.5 8.5	10.5 5.75 5.75	X N
01-437N 01-438C 01-439X	7	7094 7010 7091	8.5 8.5 8.5	18.5 20.5 46.125	N C
01-440C 01-441N 01-442X	7	7010 7094 7091	8.5 8.5 8.5	41.75 10.5 35.5	C N
01-443X 01-444N 01-445X	7	7091 7094 7091	8.5 8.5 8.5	95.5 95.5 95.5 18.5	X N
01-446X 01-447C 01-448N	7	7091 7010 7094	8.5 14.5 14.5	20.5 46.125 41.75	X C
01-449X 01-450N 01-451X	7	7091 7094 7091	14.5 14.5 14.5 14.5	10.5 35.5 95.5	X N
01-451X 01-452X 01-453N 01-454C	7	7091 7091 7094 7010	14.5 14.5 14.5 14.5	95.5 95.5 18.5 20.5	X N
01-454C 01-455N 01-456X 01-457N	7	7094 7091 7094	14.5 11.5 11.5 8.5	46.125 41.75 10.5	N X
01-459N 01-459N 01-460X	7	7094 7091 7094 7091	8.5 8.5 8.5	35.5 95.5 95.5	X N
01-460X 01-461X 01-462N 01-463X	7	7091 7091 7094 7091	8.5 8.5 8.5 11.5	95.5 18.5 20.5 46.125	X N
01-464C 01-465C ATTAG	CHMENT 7	7010 7010 7010 7094	11.5 11.5 14.5 14.5	46.125 22 46.125 22	C C
01-466N ATTAC 01-467C 01-468N 01-469X	7	7094 7010 7094 7091	14.5 5.5 5.5 5.5	30.75 21.5 18.5	C N
01-469X 01-470N 01-471X 01-472N	7	7091 7094 7091 7094	5.5 5.5 5.5 5.5	18.5 17.75 5.75 46.5	N X
01-472N 01-473C 01-474N 01-475C	7	7010 7094 7010	5.5 5.5 11.5 11.5	46.5 20.5 30.75 21.5	C N
01-475C 01-476N 01-477X 01-478N	7	7094 7091	11.5 11.5 11.5 11.5	21.5 18.5 17.75 5.75	N X
01-479X 01-480N	7	7094 7091 7094 7010	11.5 11.5	46.5 20.5	X N
01-481C 01-482X 01-483N	7	7010 7091 7094	14.5 14.5 14.5	30.75 21.5 18.5	X N
01-484X 01-485N 01-486X	7	7091 7094 7091	14.5 14.5 14.5	17.75 5.75 46.5	N X
01-487X 01-488X 01-489N	7	7091 7091 7094	14.5 8.5 8.5	20.5 30.75 21.5	X N
01-490X 01-491N 01-492X	7	7091 7094 7091	8.5 8.5 8.5	18.5 17.75 5.75	N X
01-493N 01-494C 01-495N	7	7094 7010 7094	8.5 8.5 14.5	46.5 20.5 30.75	C N
01-496C 01-497N 01-498X	7	7010 7094 7091	14.5 14.5 14.5	21.5 18.5 17.75	N X
01-499N 01-500X 01-501N	7	7094 7091 7094	14.5 14.5 14.5	5.75 46.5 20.5	X N
01-502C 01-503N 01-504X	7	7010 7094 7091	8.5 8.5 8.5	30.75 21.5 18.5	N X
01-505N 01-506X 01-507N	7	7094 7091 7094	8.5 8.5 8.5	17.75 5.75 46.5	X N
01-508C 01-509X 01-510C	7	7010 7091 7010	8.5 11.5 11.5	20.5 30.75 21.5	X C
01-511N 01-512X 01-513N	7	7094 7091 7094	11.5 11.5 11.5	18.5 17.75 5.75	X N
01-514X 01-515X 01-516C	7	7091 7091 7010	11.5 11.5 8.5	46.5 20.5 30.75	x c
01-517X 01-518X 01-519N	7	7091 7091 7094	8.5 8.5 8.5	21.5 18.5 17.75	X N
01-520X 01-521X 01-522X	7	7091 7091 7091	8.5 8.5 8.5	5.75 46.5 20.5	x x
01-523N 01-524X 01-525X	7	7094 7091 7091	8.5 8.5 8.5	30.75 21.5 18.5	x x
01-526X 01-527X 01-528N	7	7091 7091 7094	8.5 8.5 8.5	95.5 95.5 46.5	X N
01-529C 01-530X 01-531C	7	7010 7091 7010	8.5 14.5 14.5	20.5 30.75 21.5	X C
01-532N 01-533X 01-534N	7	7094 7091 7094	14.5 14.5 14.5	18.5 95.5 95.5	X N
01-535X 01-536N 01-537C	7	7091 7094 7010	14.5 14.5 11.5	46.5 20.5 30.75	N C
01-538N 01-539X 01-540N	7	7094 7091 7094	8.5 8.5 8.5	21.5 18.5 95.5	х
01-541X 01-542N 01-543X	7	7091 7094 7091	8.5 8.5 8.5	95.5 46.5 20.5	X N
01-544N	CHMENT 7	7094 7010 7032	11.5 14.5 20.25	30.75 30.75 54.5	N C
01-547L 01-548L 01-549L	7	7032 7032 7032	20.25 20.25 20.25 20.25	53.25 53.25 53.25 54.5	L L
01-550L 01-551L 01-552L	7	7032 7032 7032	20.25 20.25 20.25	54.5 53.25 53.25	L L

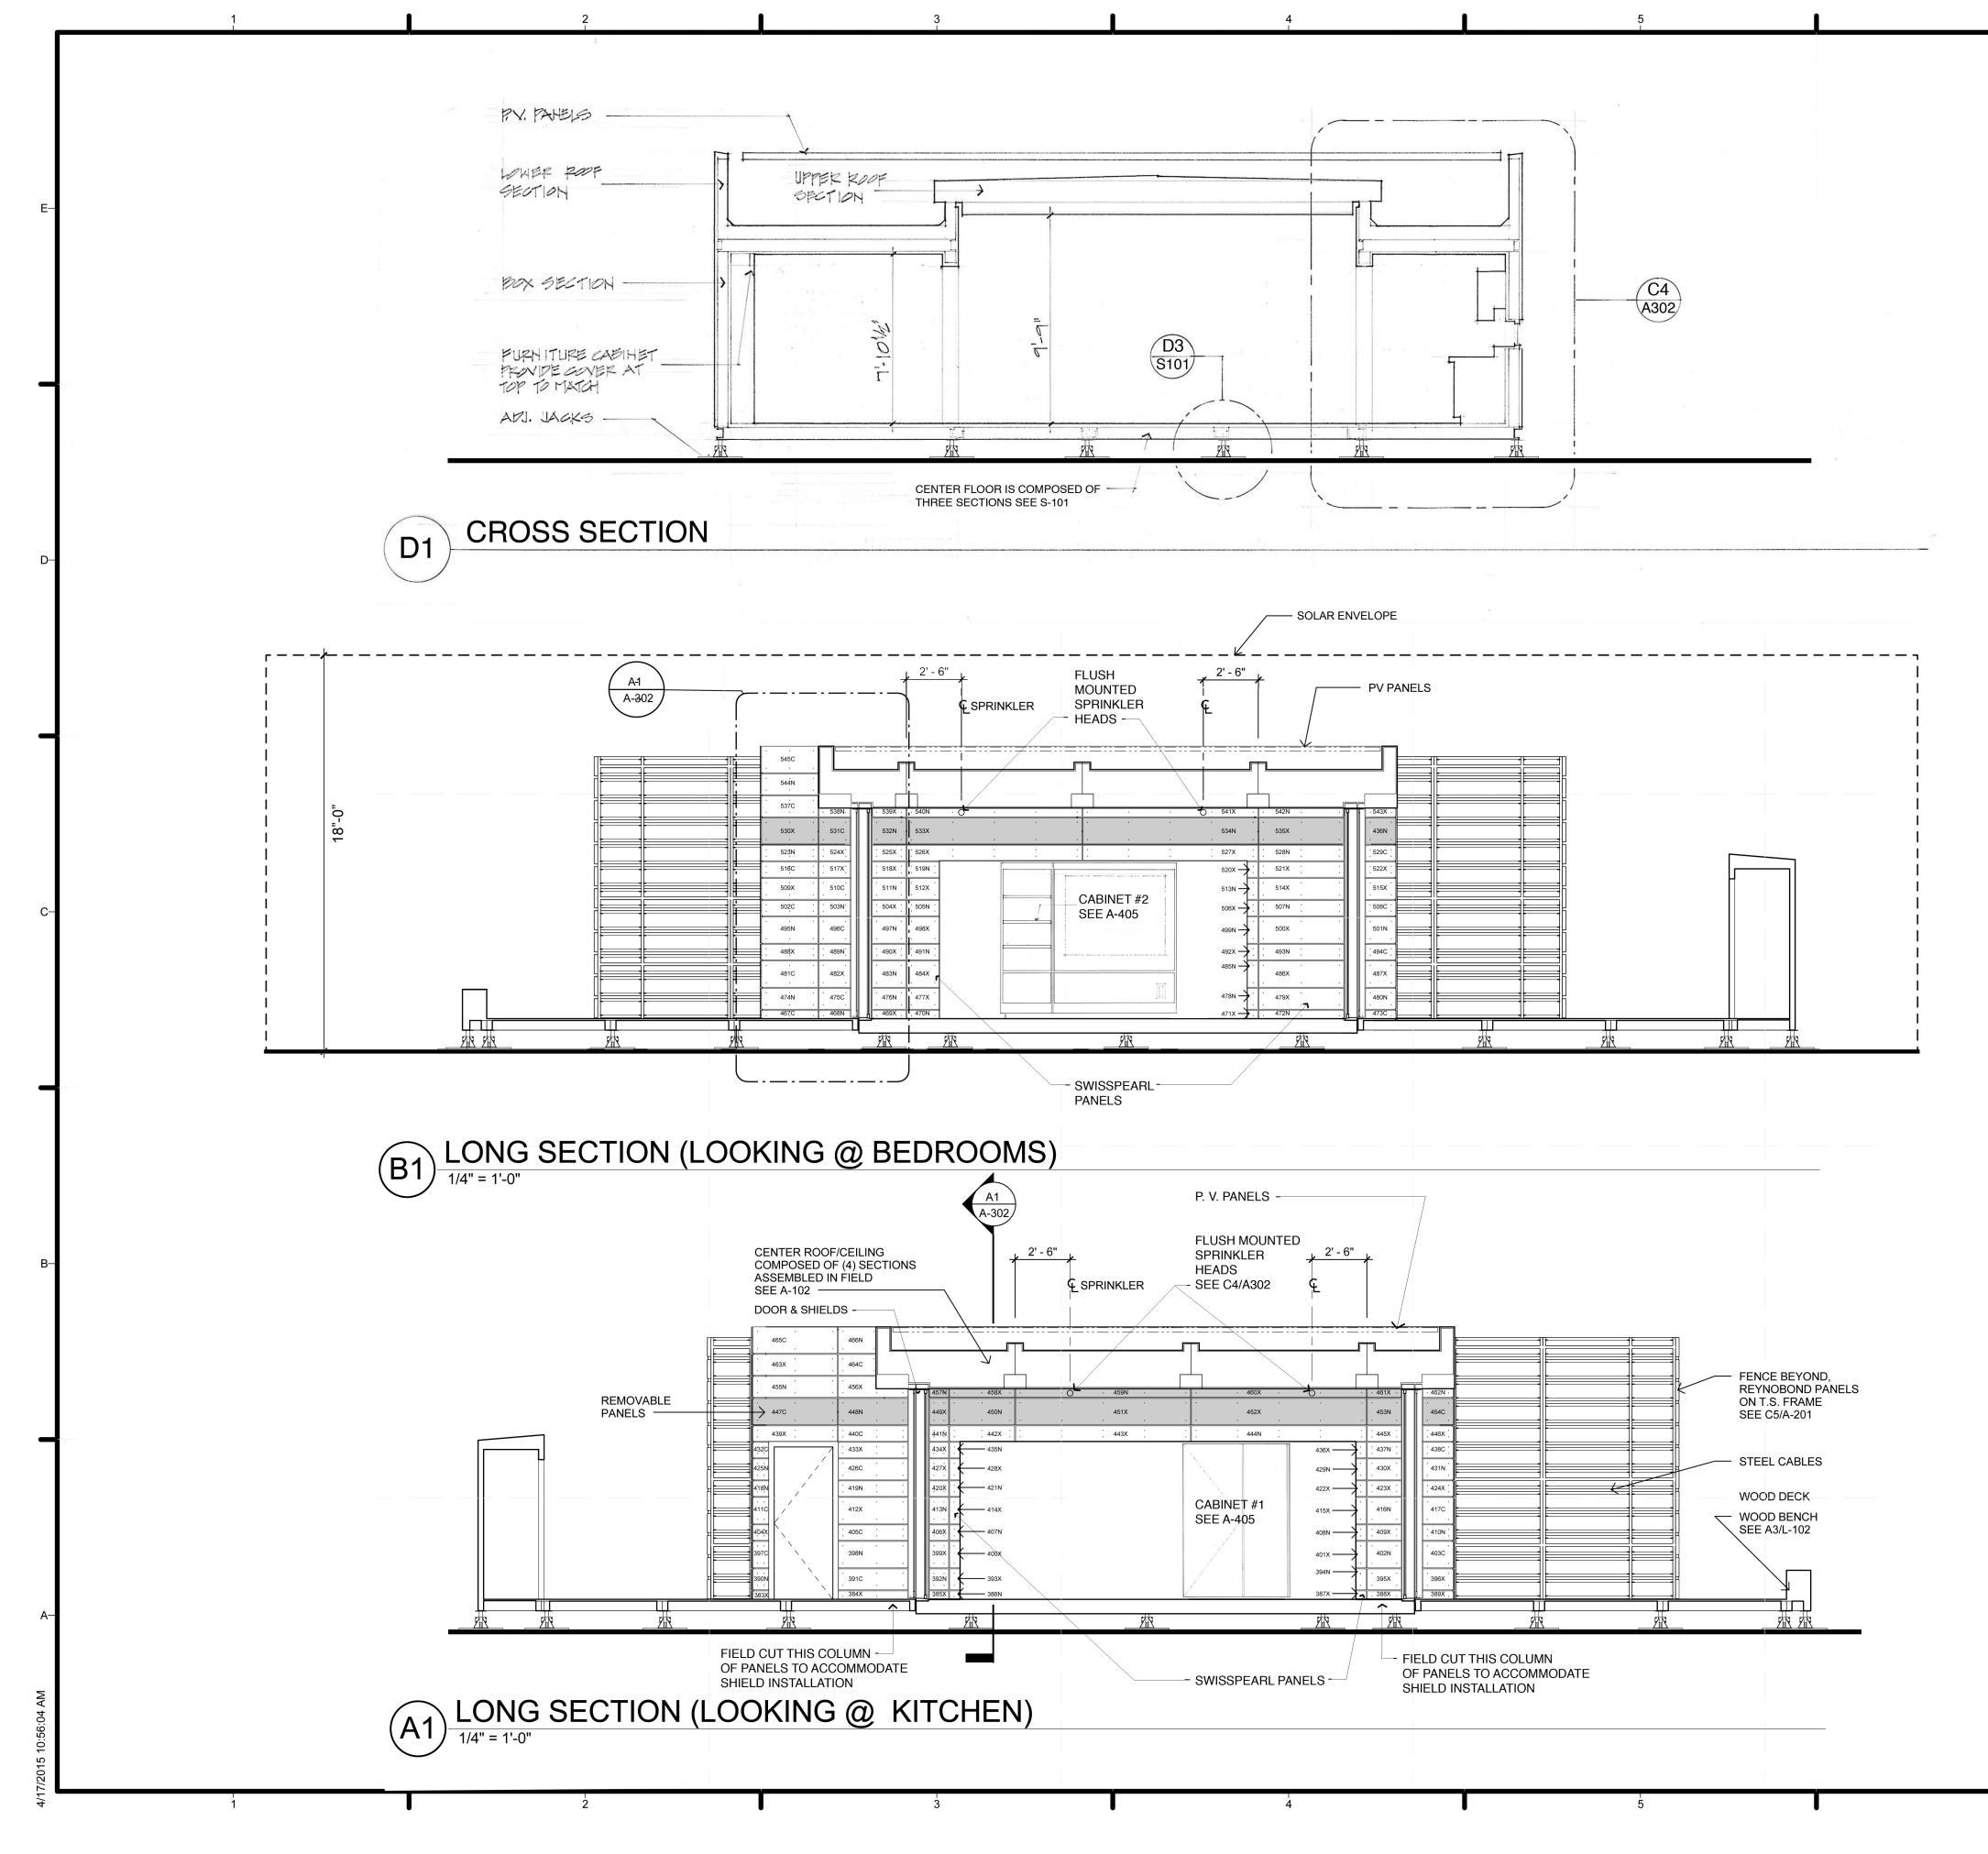



Ż


-E	S		niversity <b>IteR<sup>3</sup></b> recover resist							
	TEAM NA		CROWDER/DRURY DRURY UNIVERSITY							
			900 N BENTON AVENUE SPRINGFIELD, MO 65802							
			CROWDER COLLEGE 601 LACLEDE AVENUE NEOSHO, MO 64850							
-D	CONTACT		SHELTER.DRURY.EDU RDRURYSOLAR@GMAIL.COM							
			AUGUST 17TH, 2015							
Γ		/								
–c	CLIENT									
	U.S. DEPARTMENT OF ENERGY SOLAR DECATHLON 2015									
			DECATHLON.GOV							
	Ŵ	U.S. DEPART	DECATHLON							
		FEB. 12th 3.26.15	CONSTRUCTION DRAWINGS REVISED							
		4.1.15 4.9.15 4.17.15	REVISED REVISED REVISED							
		6.26.15	REVISED							
—В										
	MARK	DATE	DETAILS							
	LOT NUM	BER:	101							
$\mathbf{F}$	DRAWN E	SY:	Author							
	COPYRIG		NONE: PROJECT IS PUBLIC DOMAIN							
	SHEET TI	TLE								
	BL		SECTIONS							
—A			NTERIOR							
		ELEV	ATIONS							
		A-:	301							

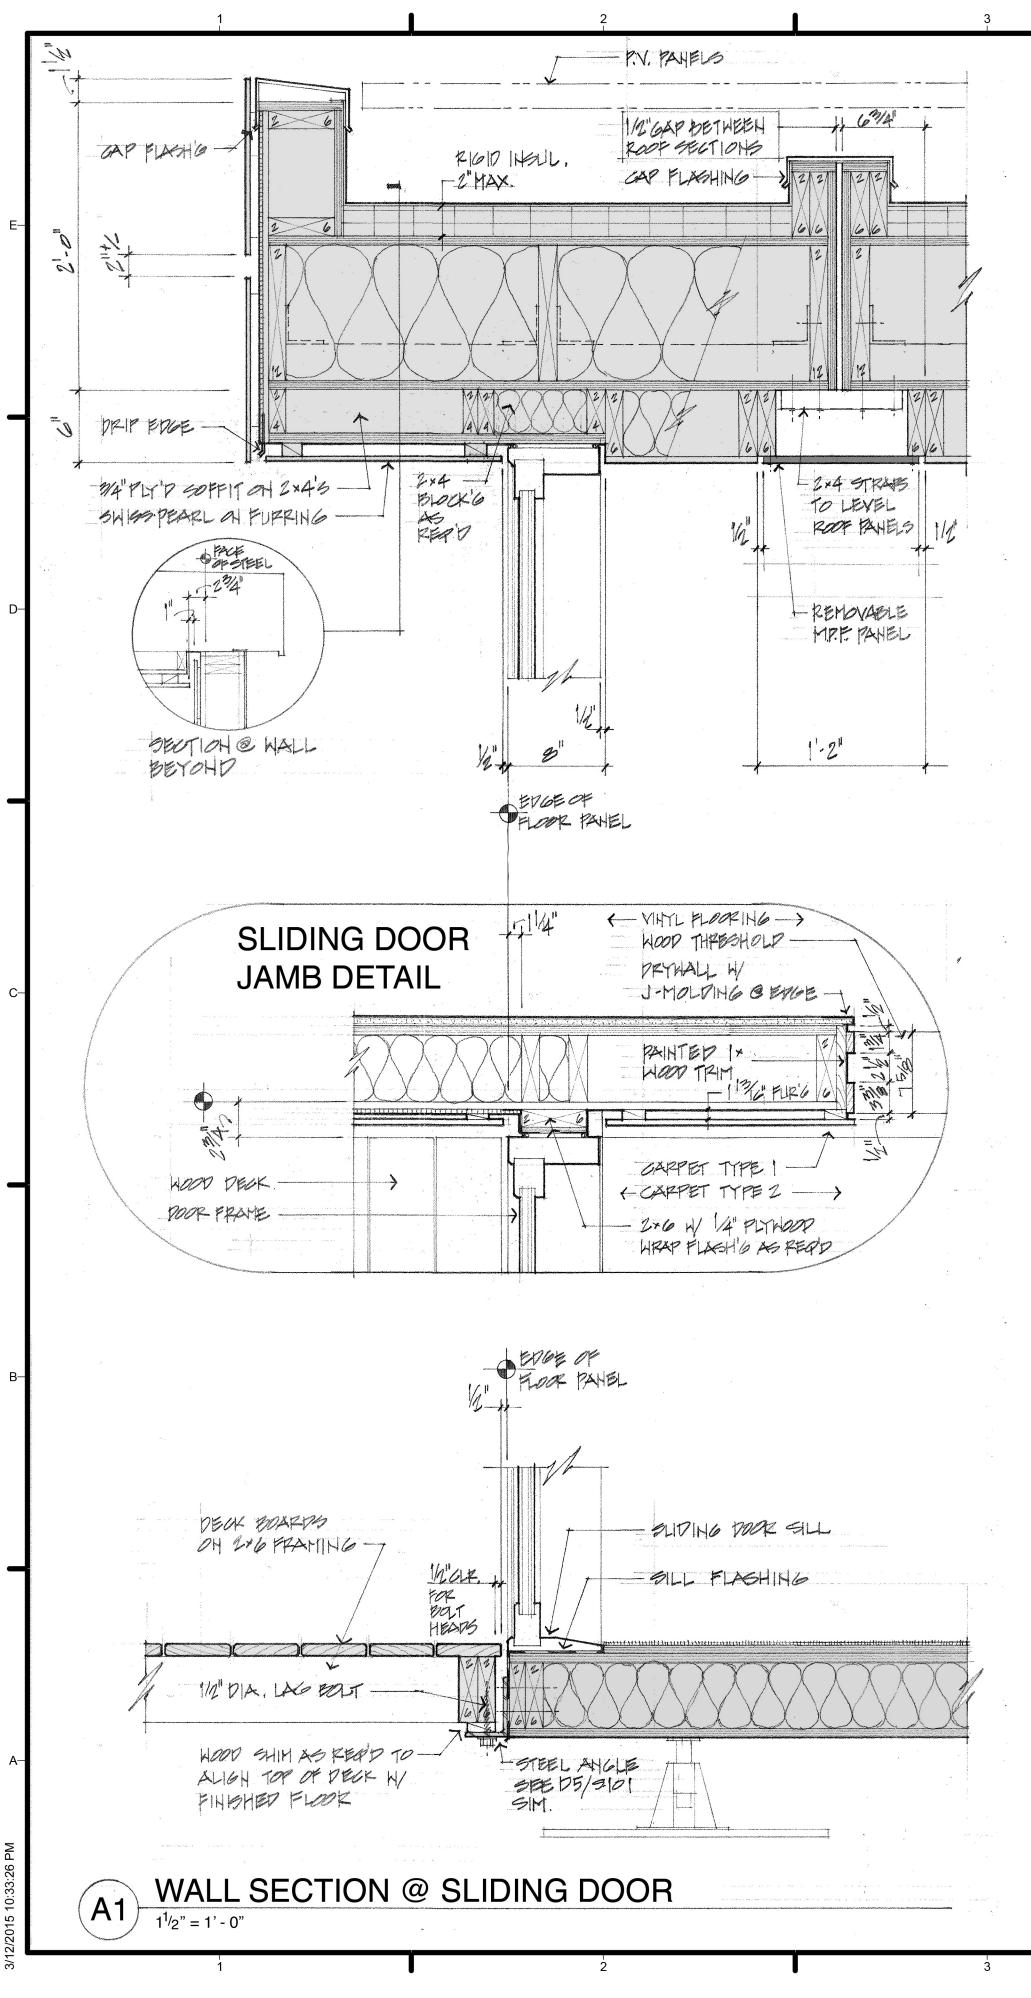


÷

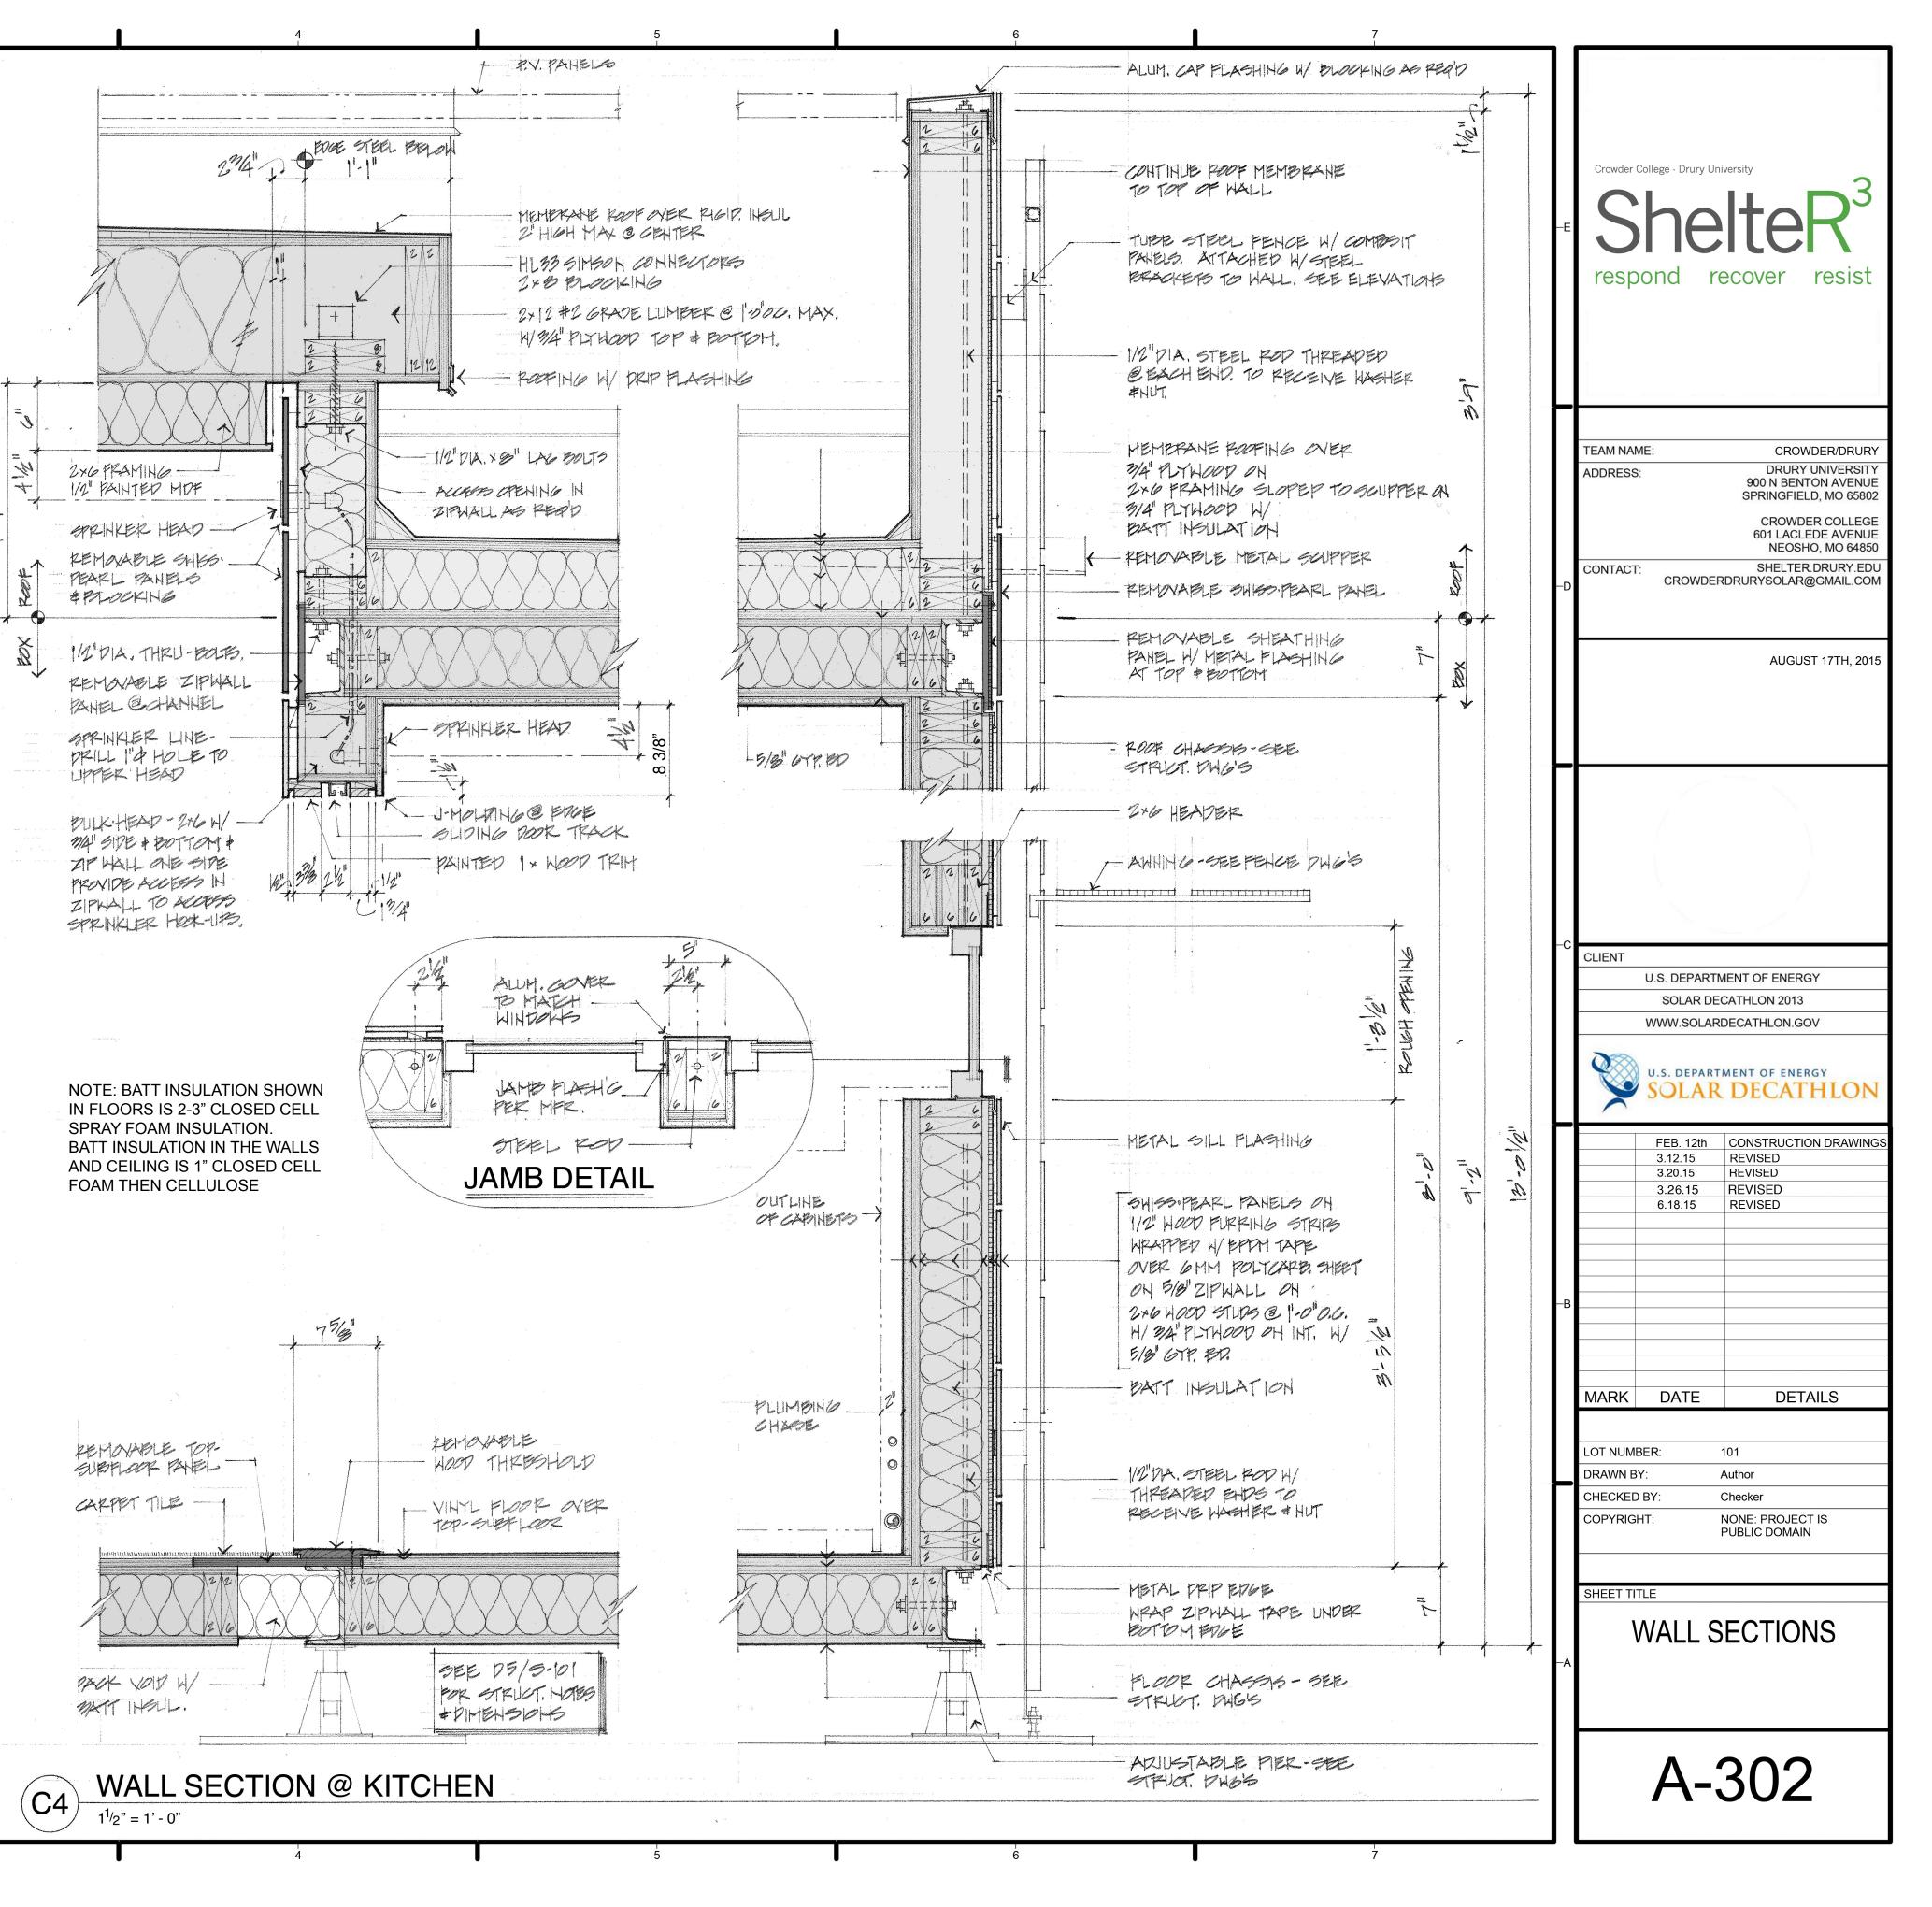


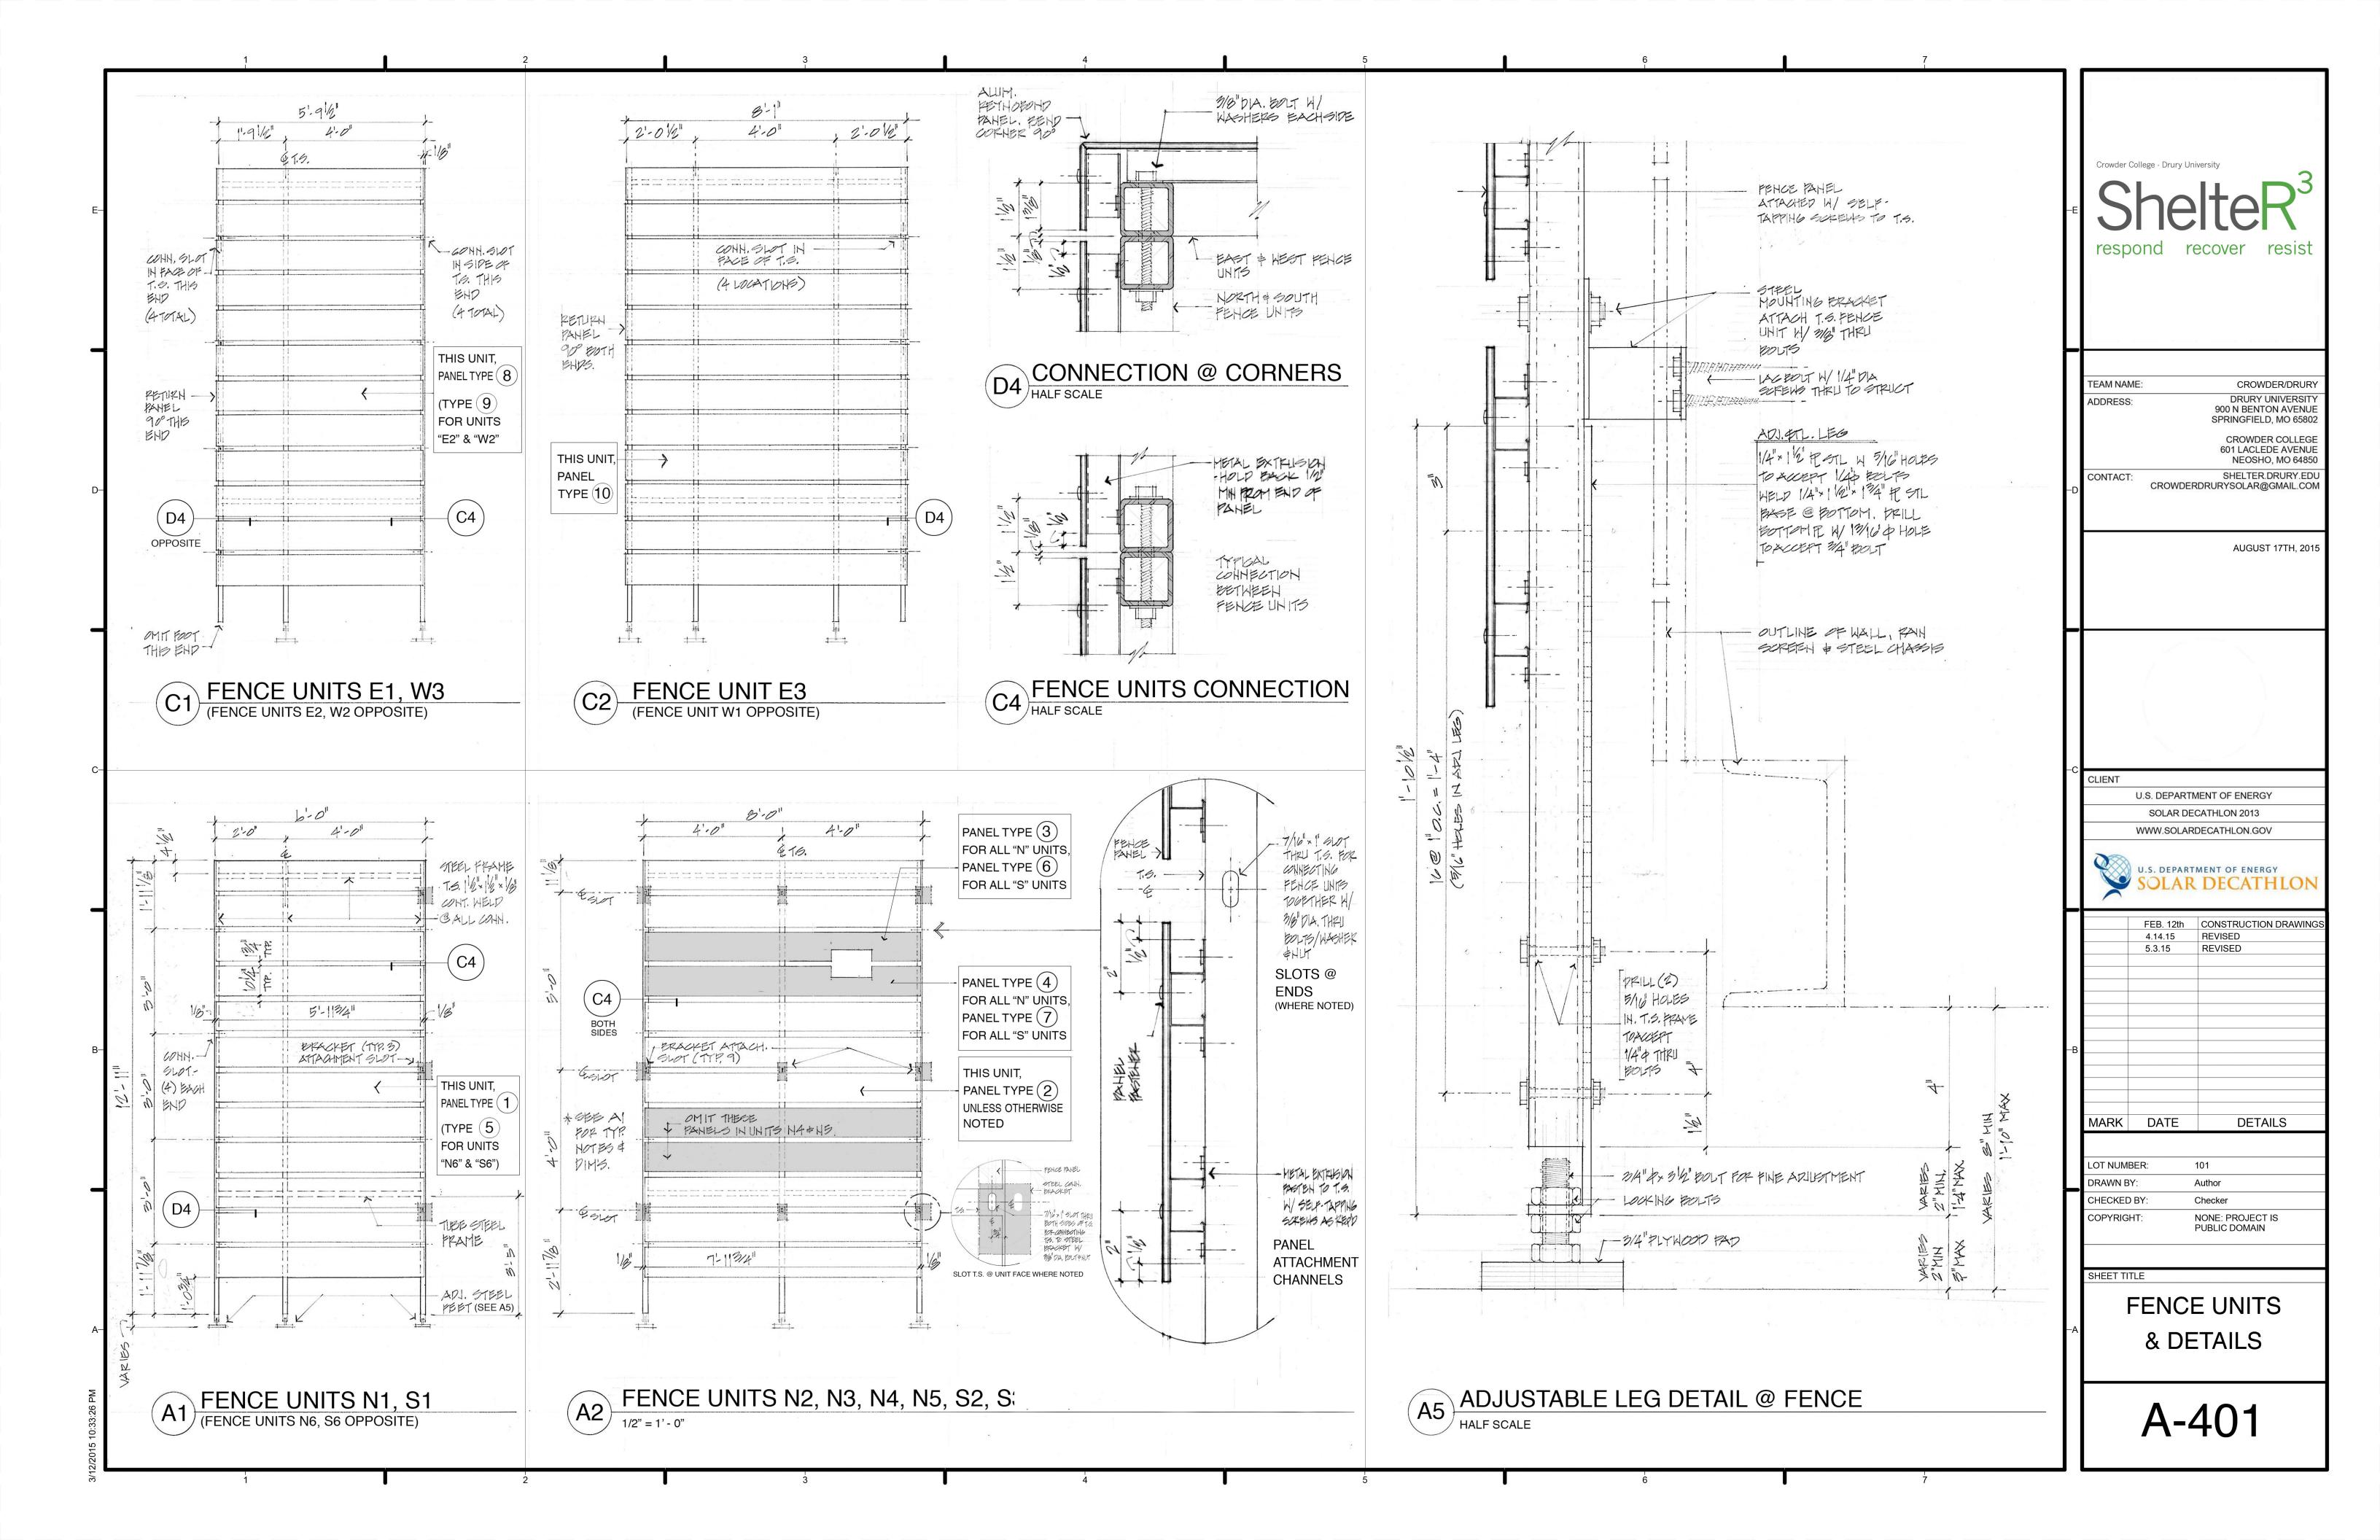


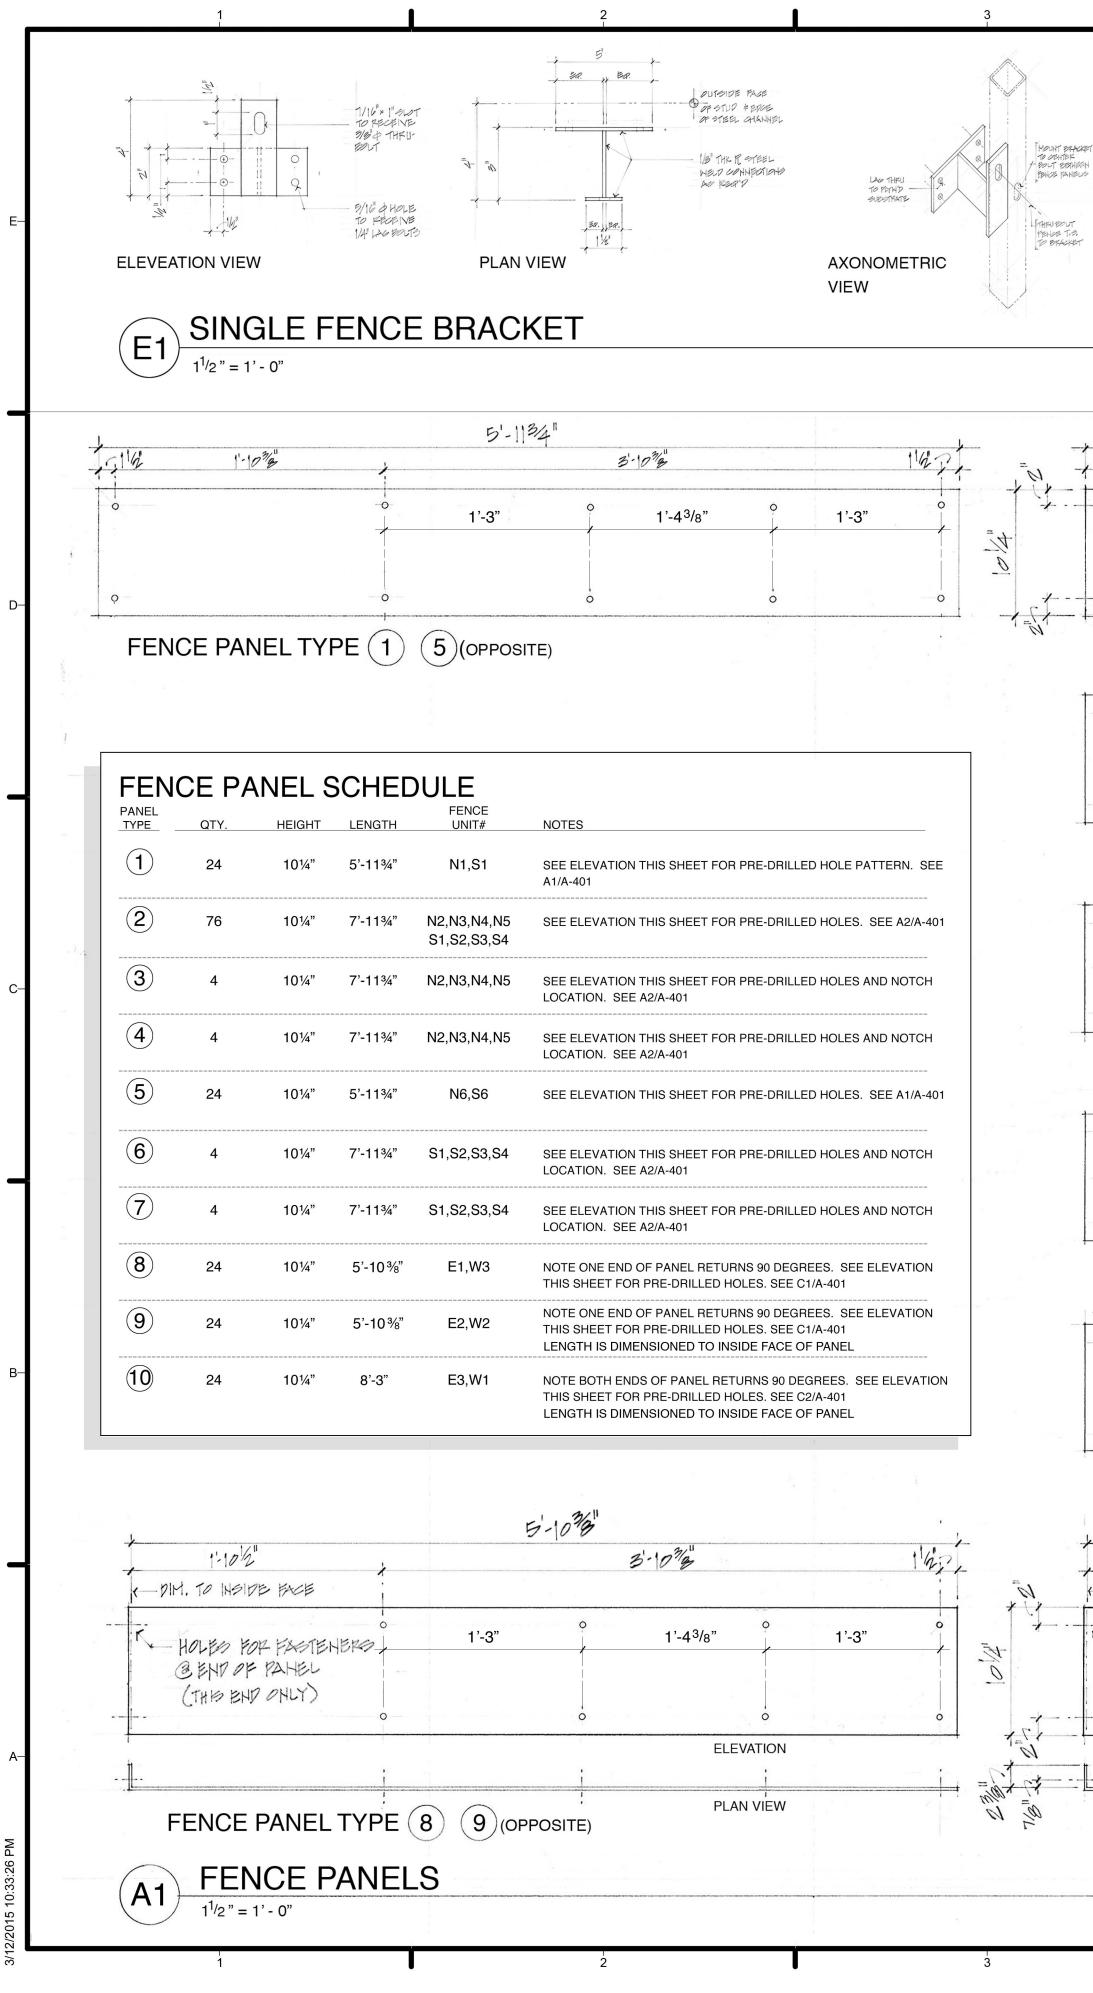



1	$\frac{4}{1^{1}/2^{n}} = 1^{n}$	BLE FEN	OLE NB WUT3	PLAN VIEW	5 5 5 5 5 7 5 7 5 7 7 7 7 7 7 7 7 7 7 7	н  /9" ТНК П Мер ССР Дет Кер	1416051049 19	Lie 14 To Phy eutorit eutorit AXONOME VIEW		HOUNT BAT TO CENTER BOLT SEAN BALCE PANE THEU BOUT THENDE T.S TO BRACKE
G142	3'-10 <sup>3</sup> /2"		7	-1134"		3-103				14.
-0	-3" 0′′⁄⁄⁄ -3" 1'-4 <sup>5</sup>	3/c," O	1'-3"		1' 0"	3-10"\$ 0	1'-4 <sup>3</sup> /	-" •	1' 0"	
	-3 1-4	578	1-3		1'-3"		1 -4%	8	1'-3"	
FENCE	PANEL TYPE (2)	°K		- PRE-DRILLE REQUIRED B SELF TAPPI	P HOLES R MFR S	AS UPPLIED		o		0
-0	Ŷ	<b>Q</b>		-0-	HØ 974718	, o		Q		-0-
0	ò			0	=		•	 o		
FENCE	PANEL TYPE 3						1-0"		1'-5 <sup>7</sup> /8"	
O	Q	Q		O ·	-M	ò				-0
0	0	0		-O - ·		ò		ò		0-
FENCE	PANEL TYPE (4)									N.,
0	Q	Q		0		ò		ò		-0
0	ò	•	- M	0				ò		0
FENCE	PANEL TYPE 6		{		1.0"			2'-6 <sup>7</sup> /8	3"	
0	ò	ò	n=	O				Ŷ		O
0	ò	0		0		<b>.</b> O .		0		-0
FENCE	PANEL TYPE 7	)		8'-3"						· · · · · · ·
2'- -THIS DIM. TO IN	-11/2"			4'-0"					2-11/2	
HOLES @ EHT	PEOR PACTENERS	1'-4"		1'-4"	•   	1'-4'	" "	, , ,	1. TO INGDE FAC	<u>е                                    </u>
-	0	····· ÷	0	<u>.</u>			(	ELEVAT	ION	i
FENCE	PANEL TYPE (10	)						PLAN V	IEW	

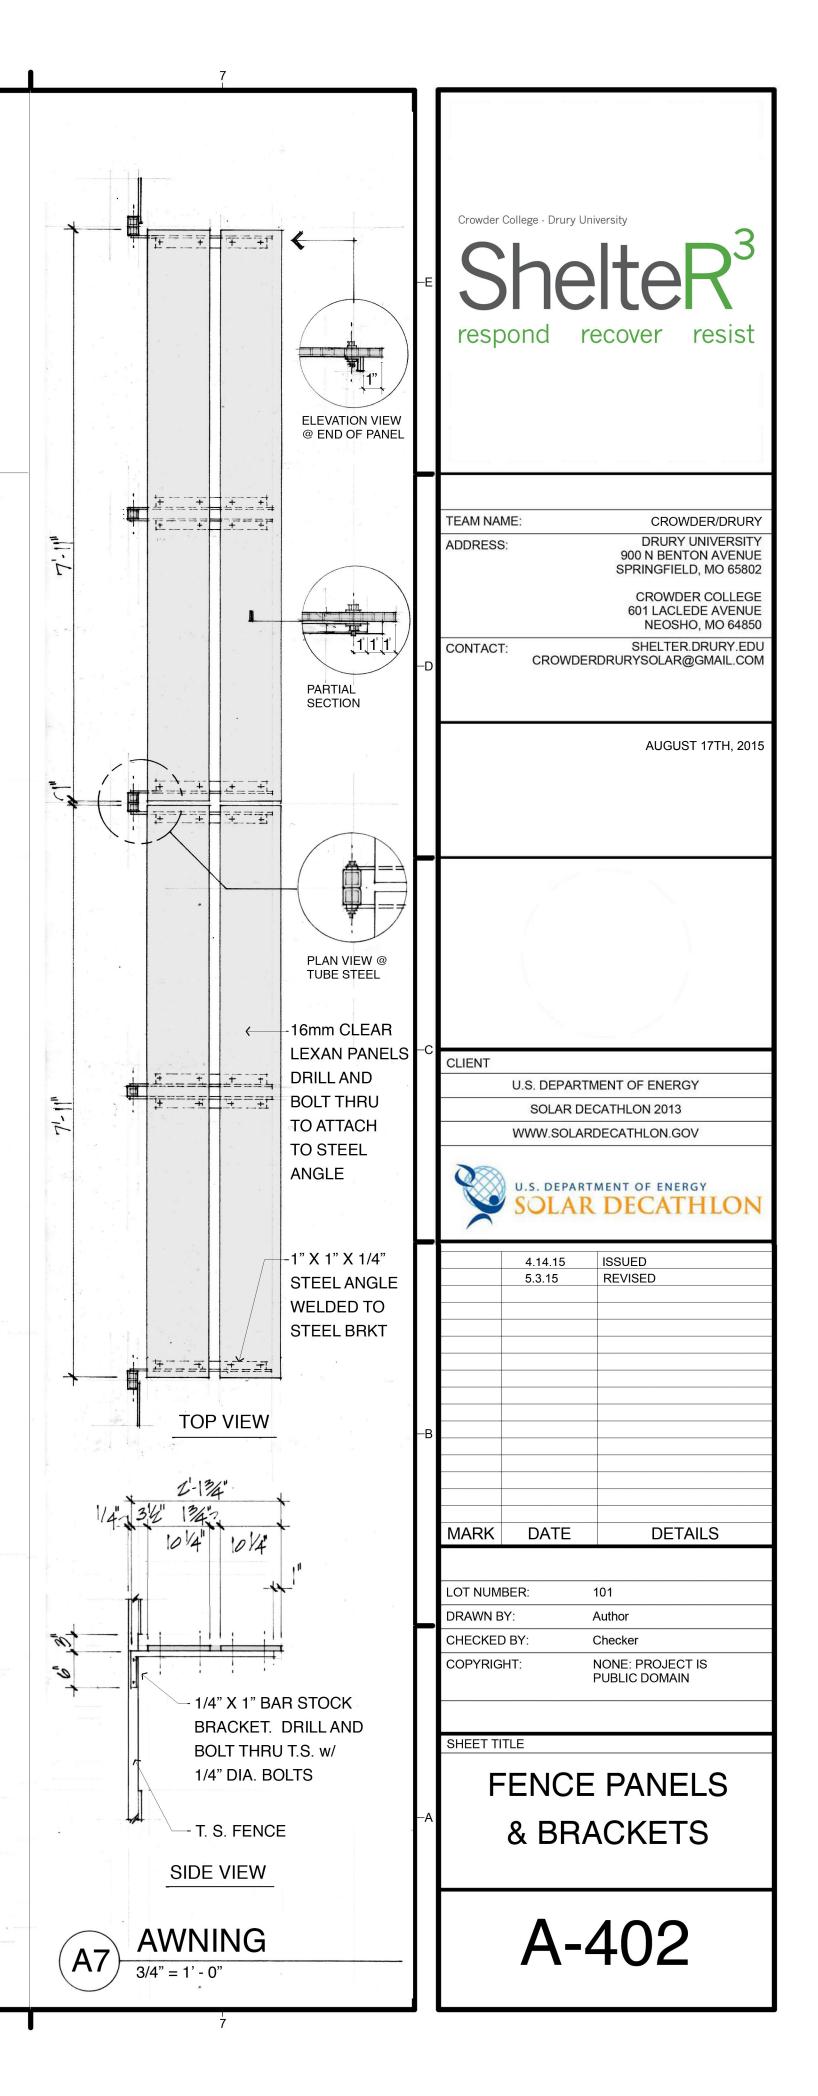


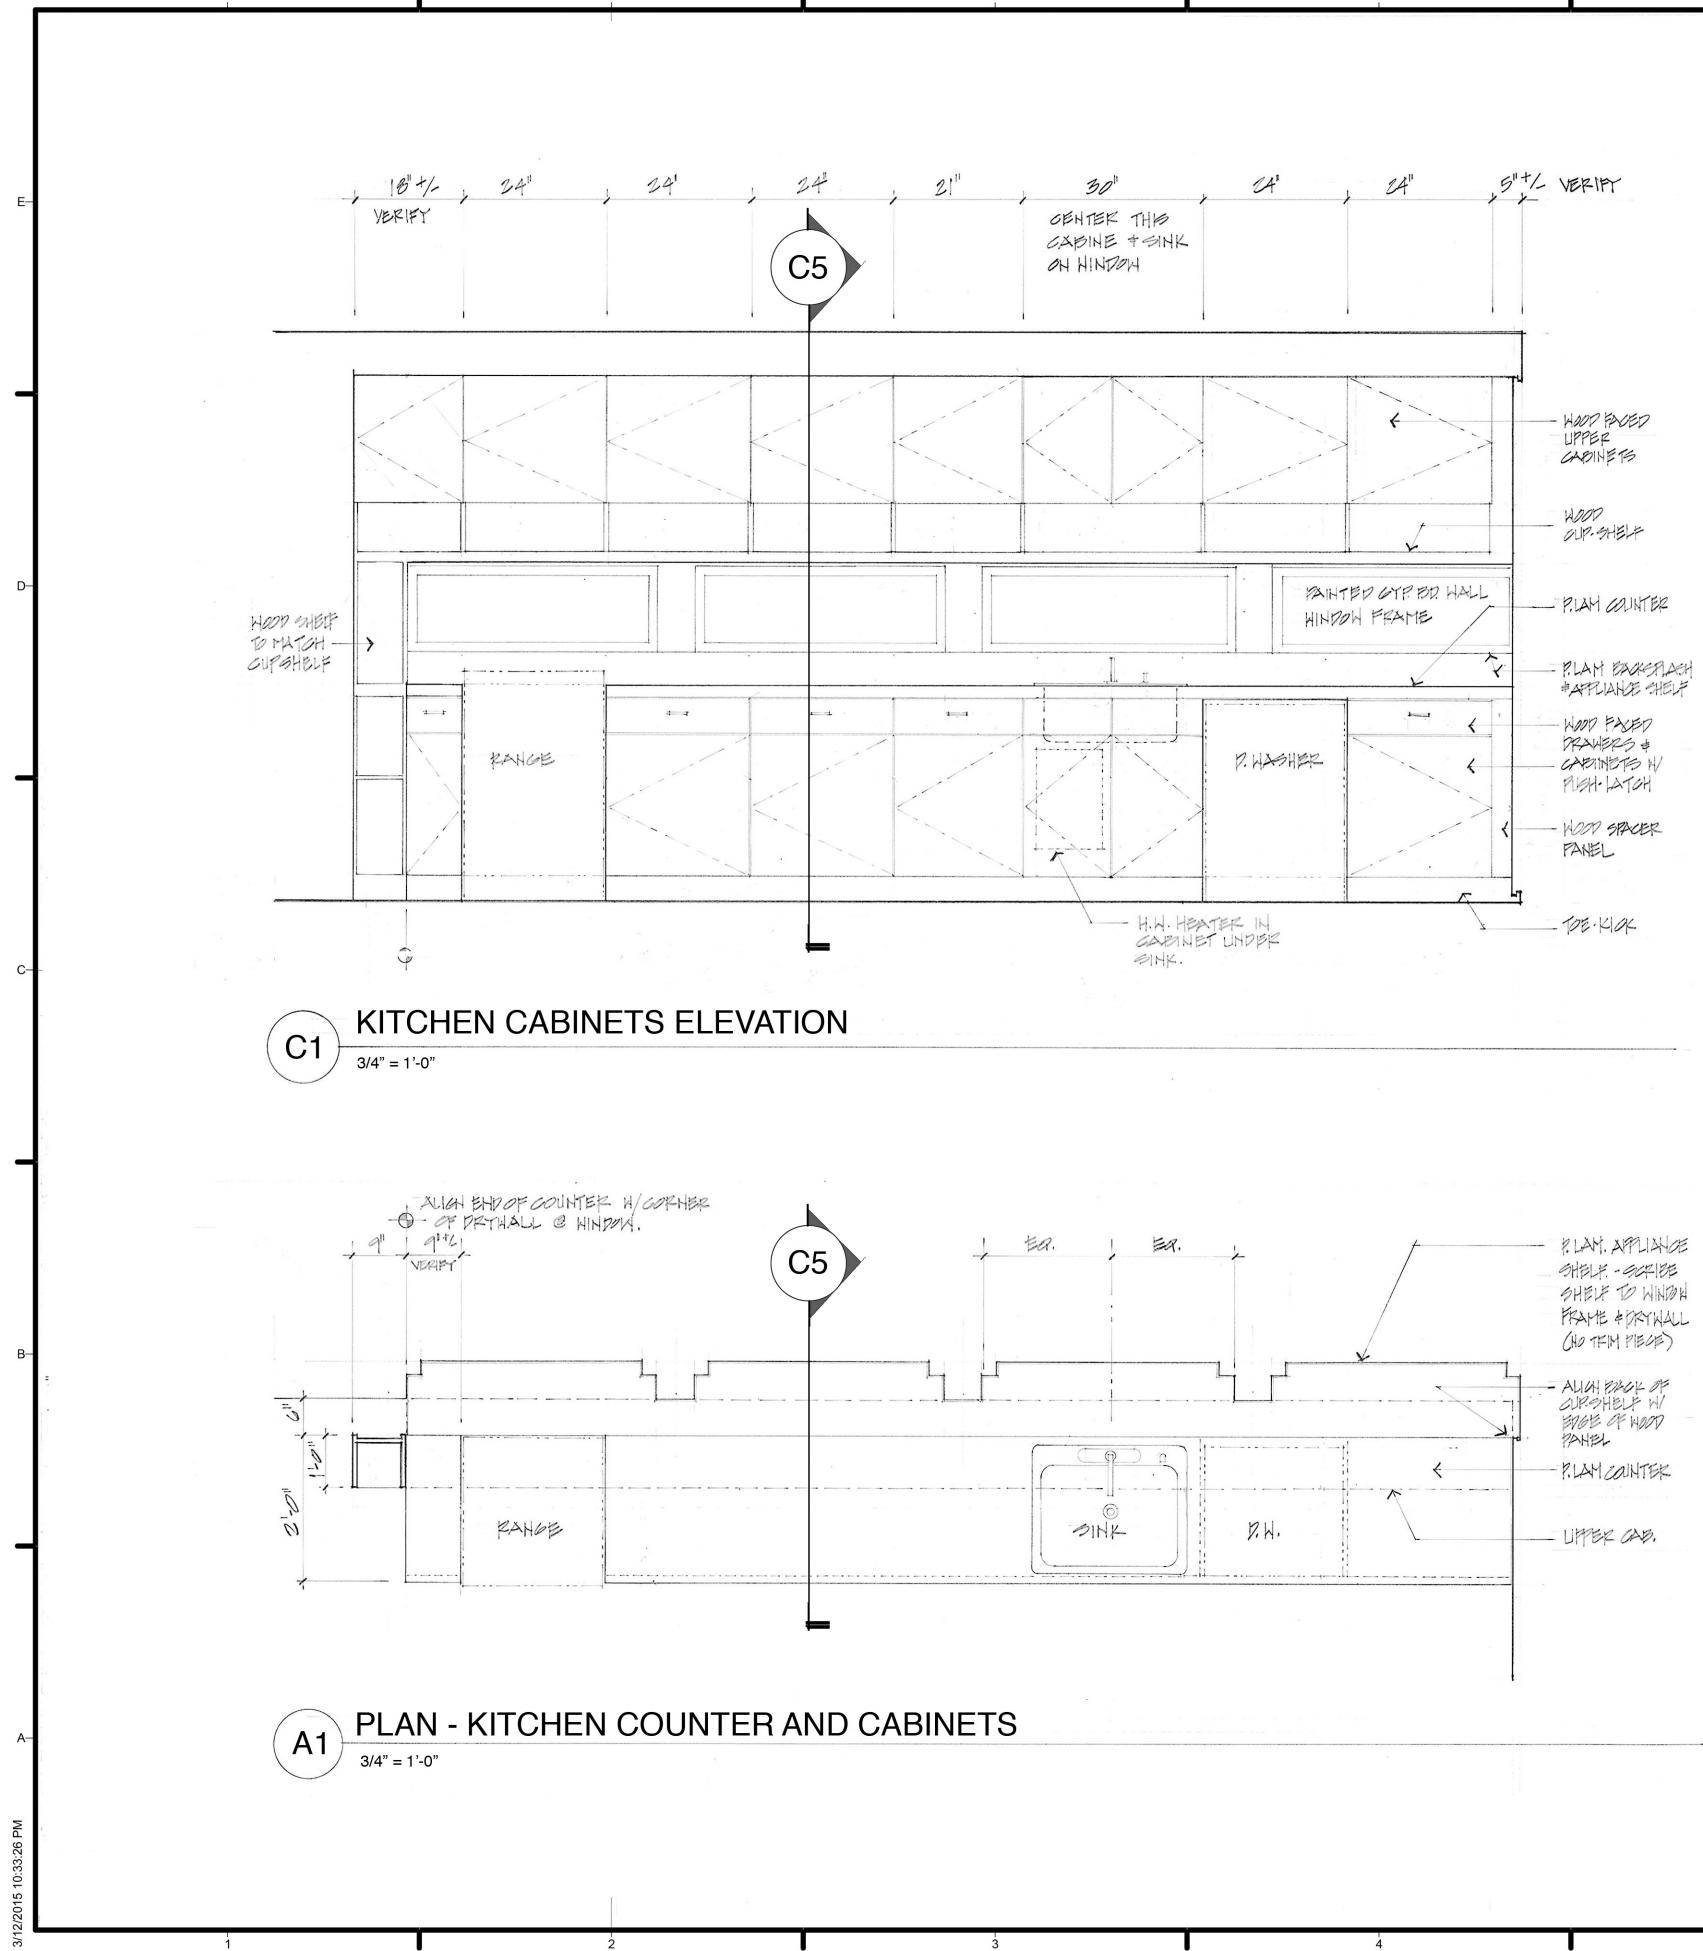

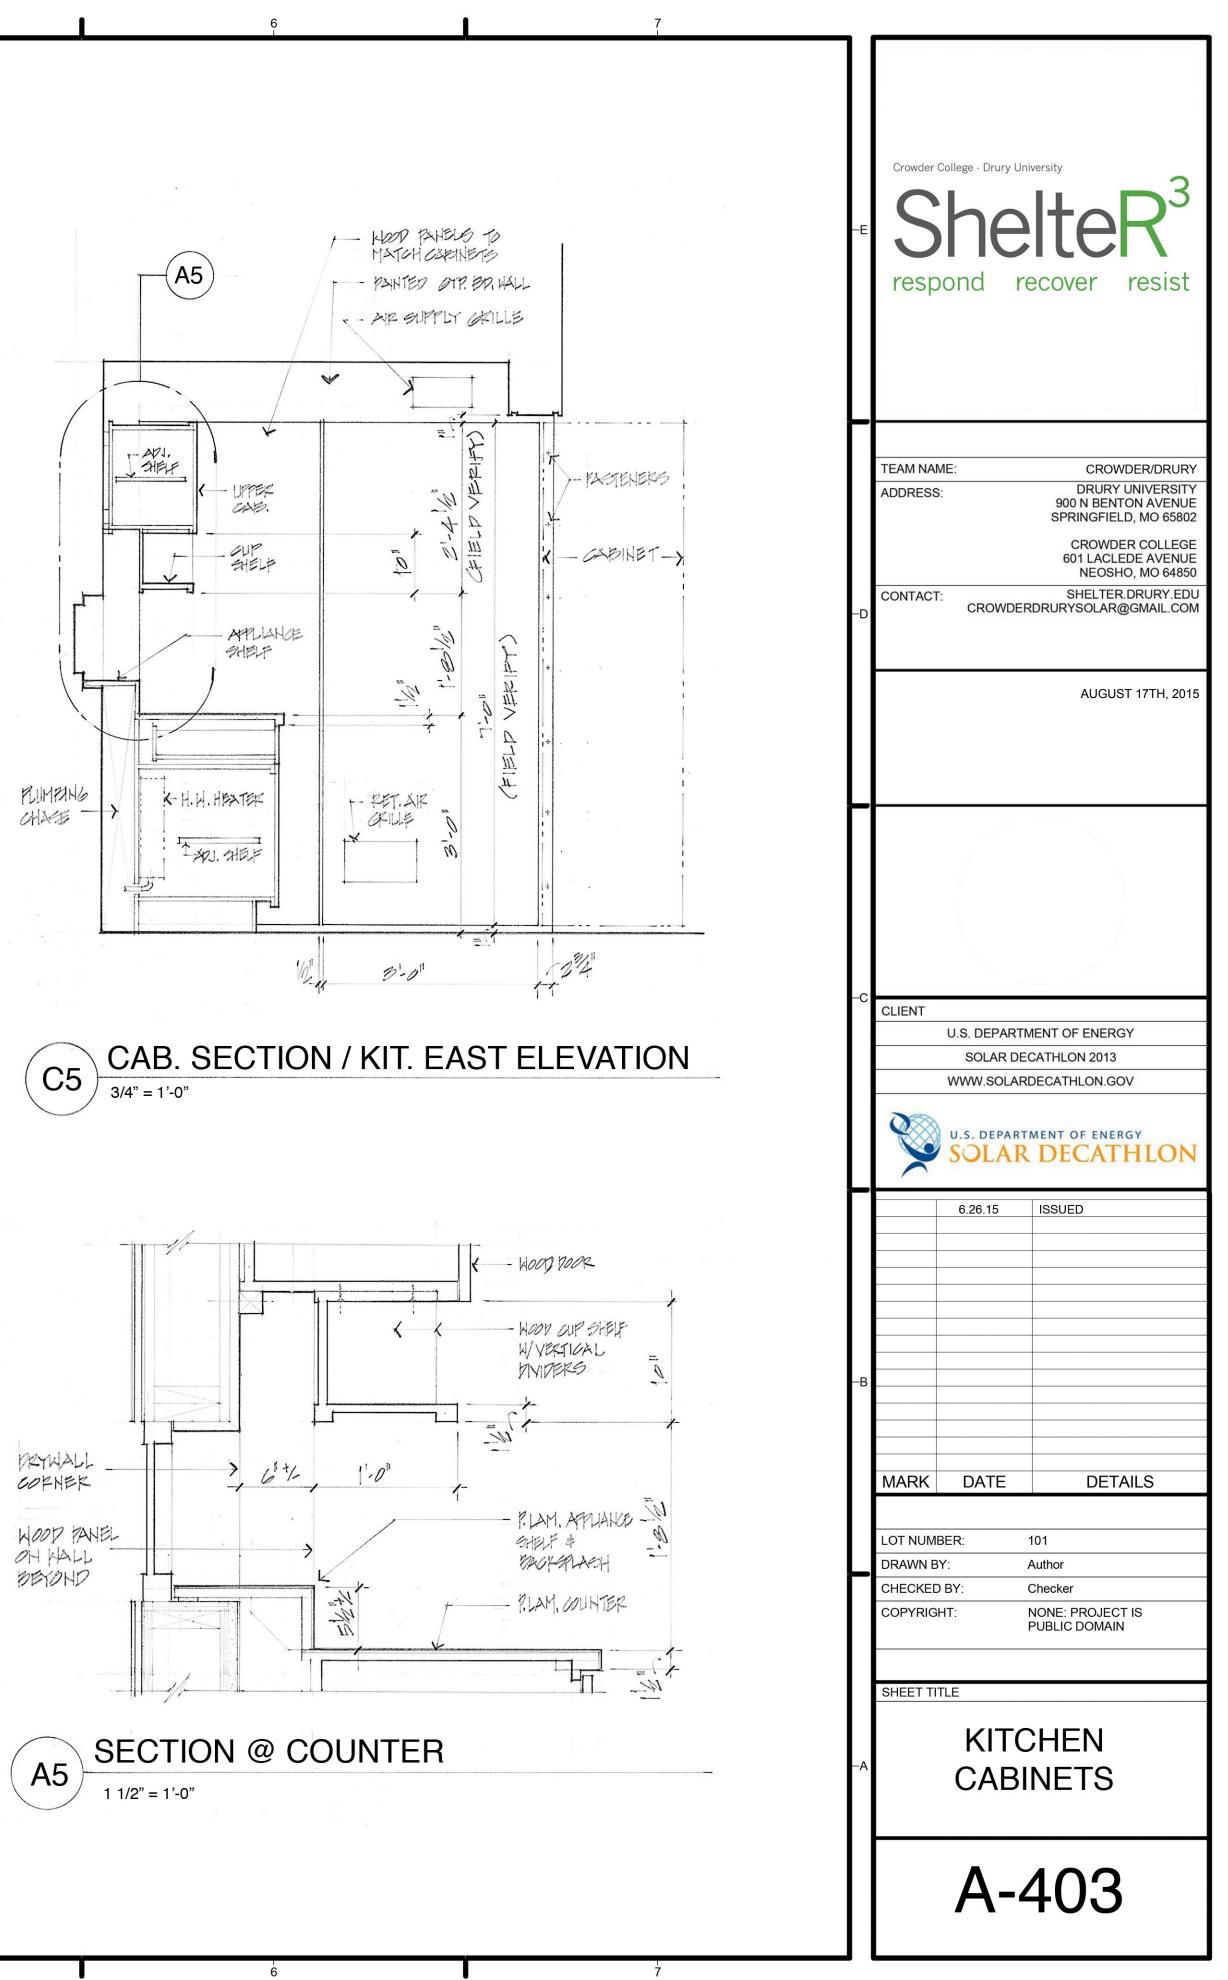

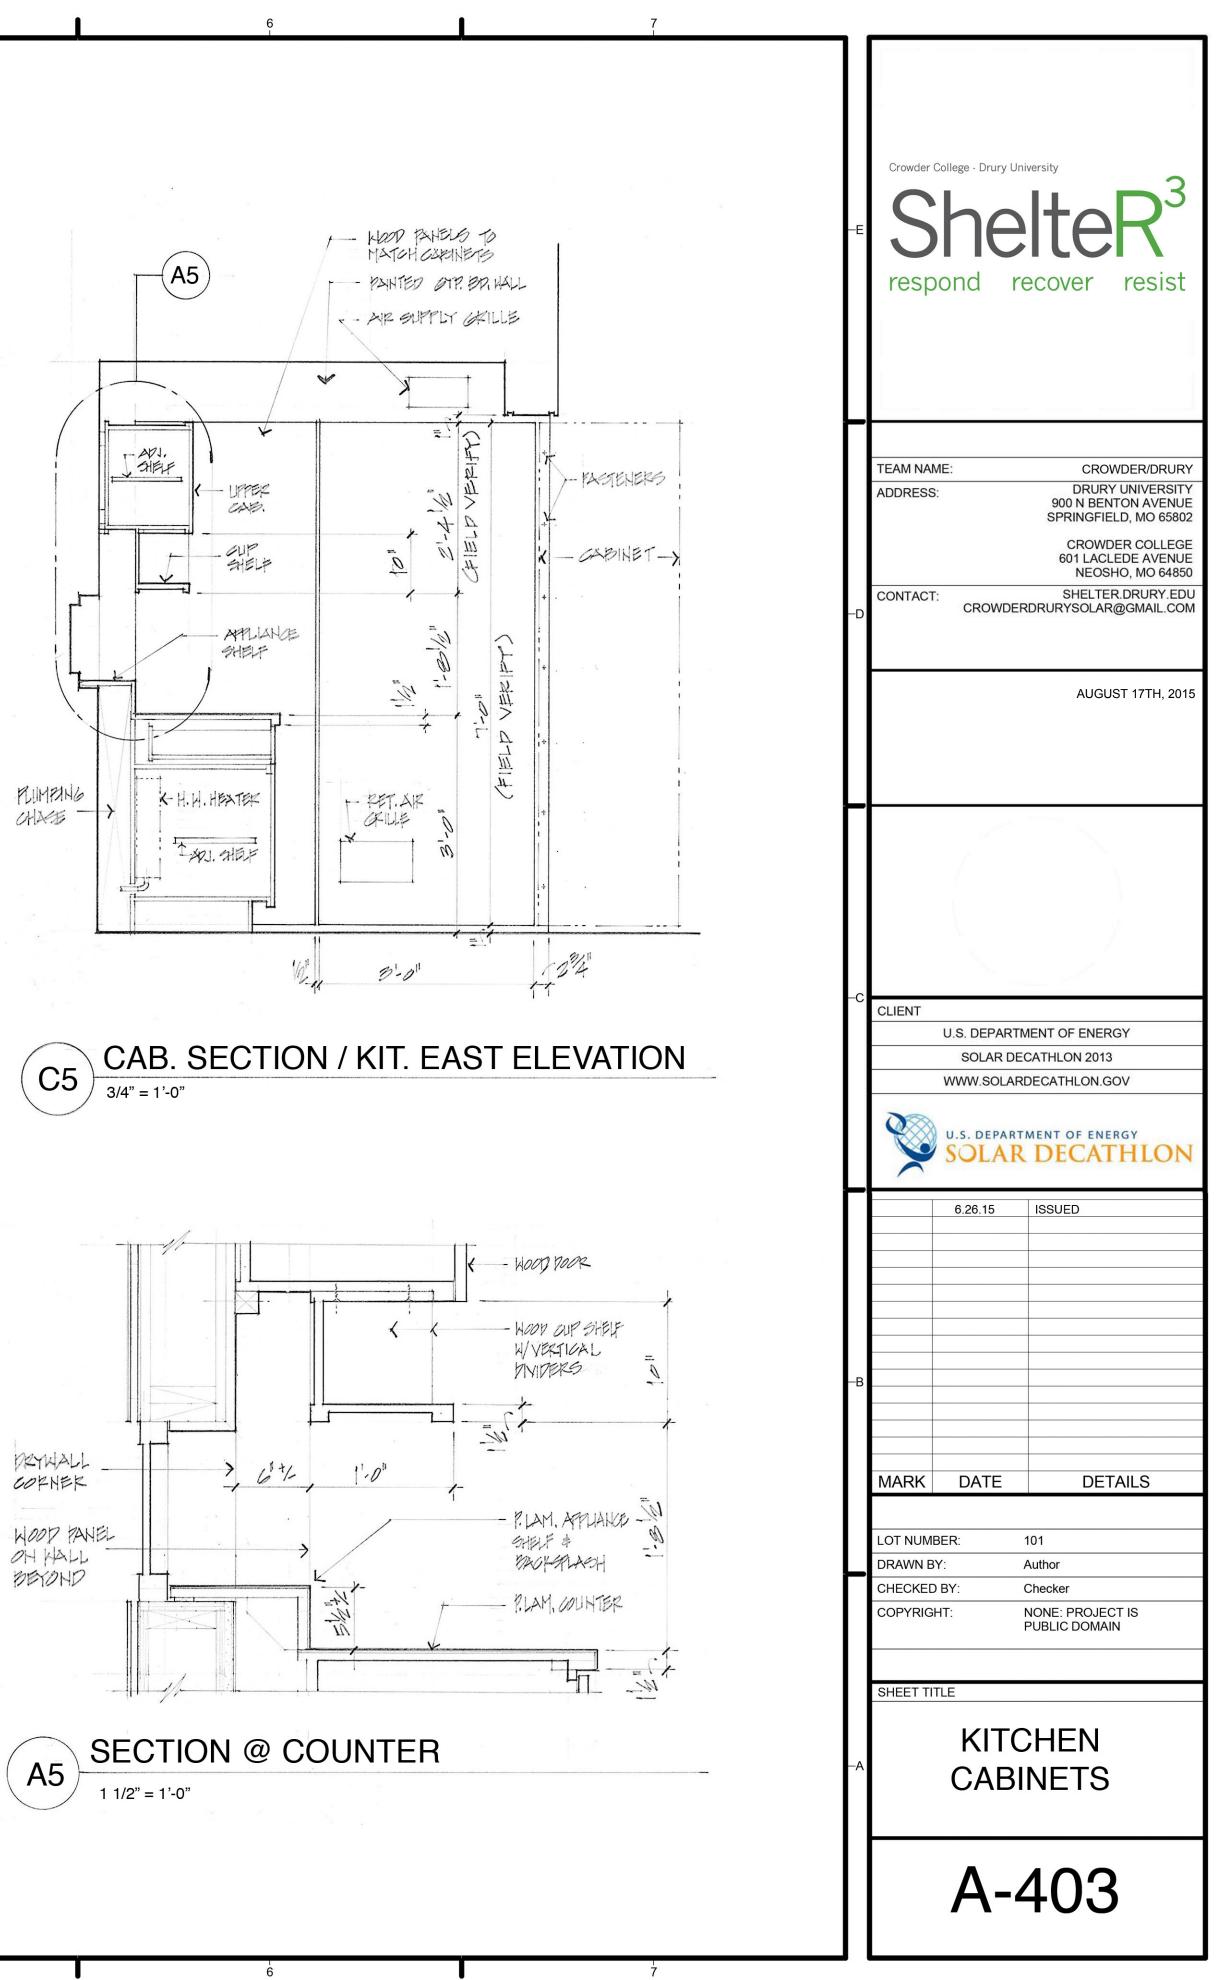

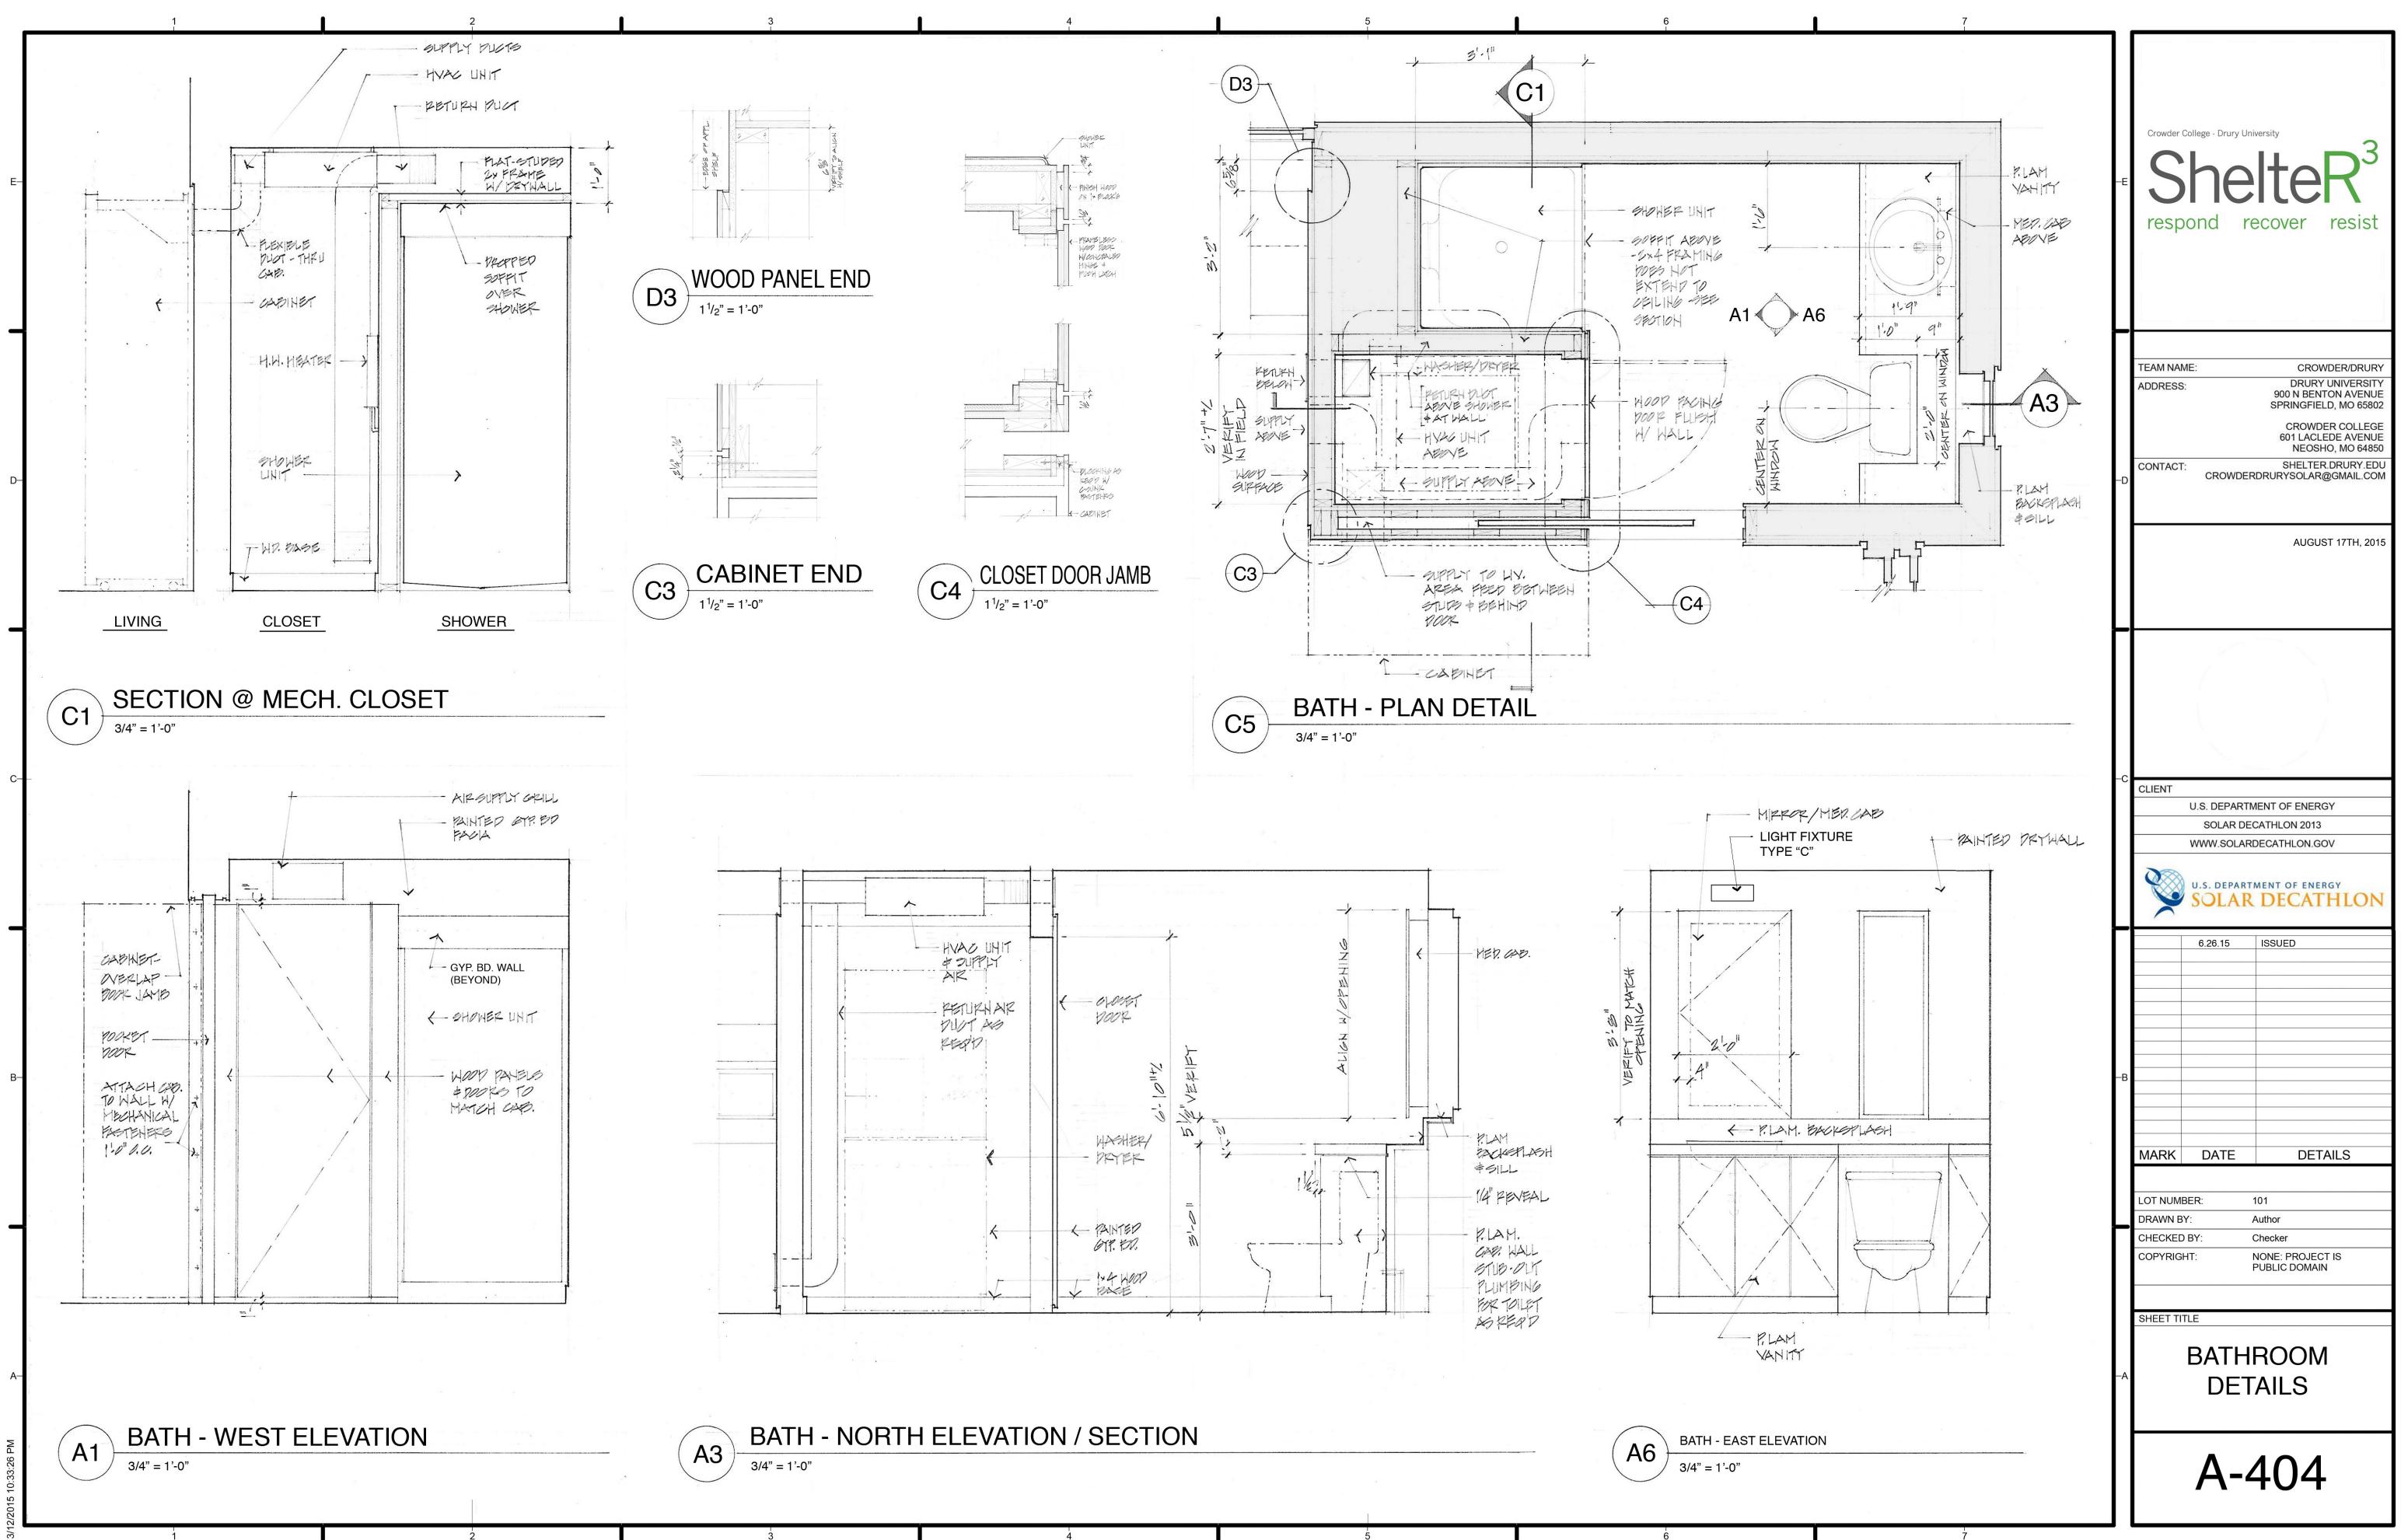

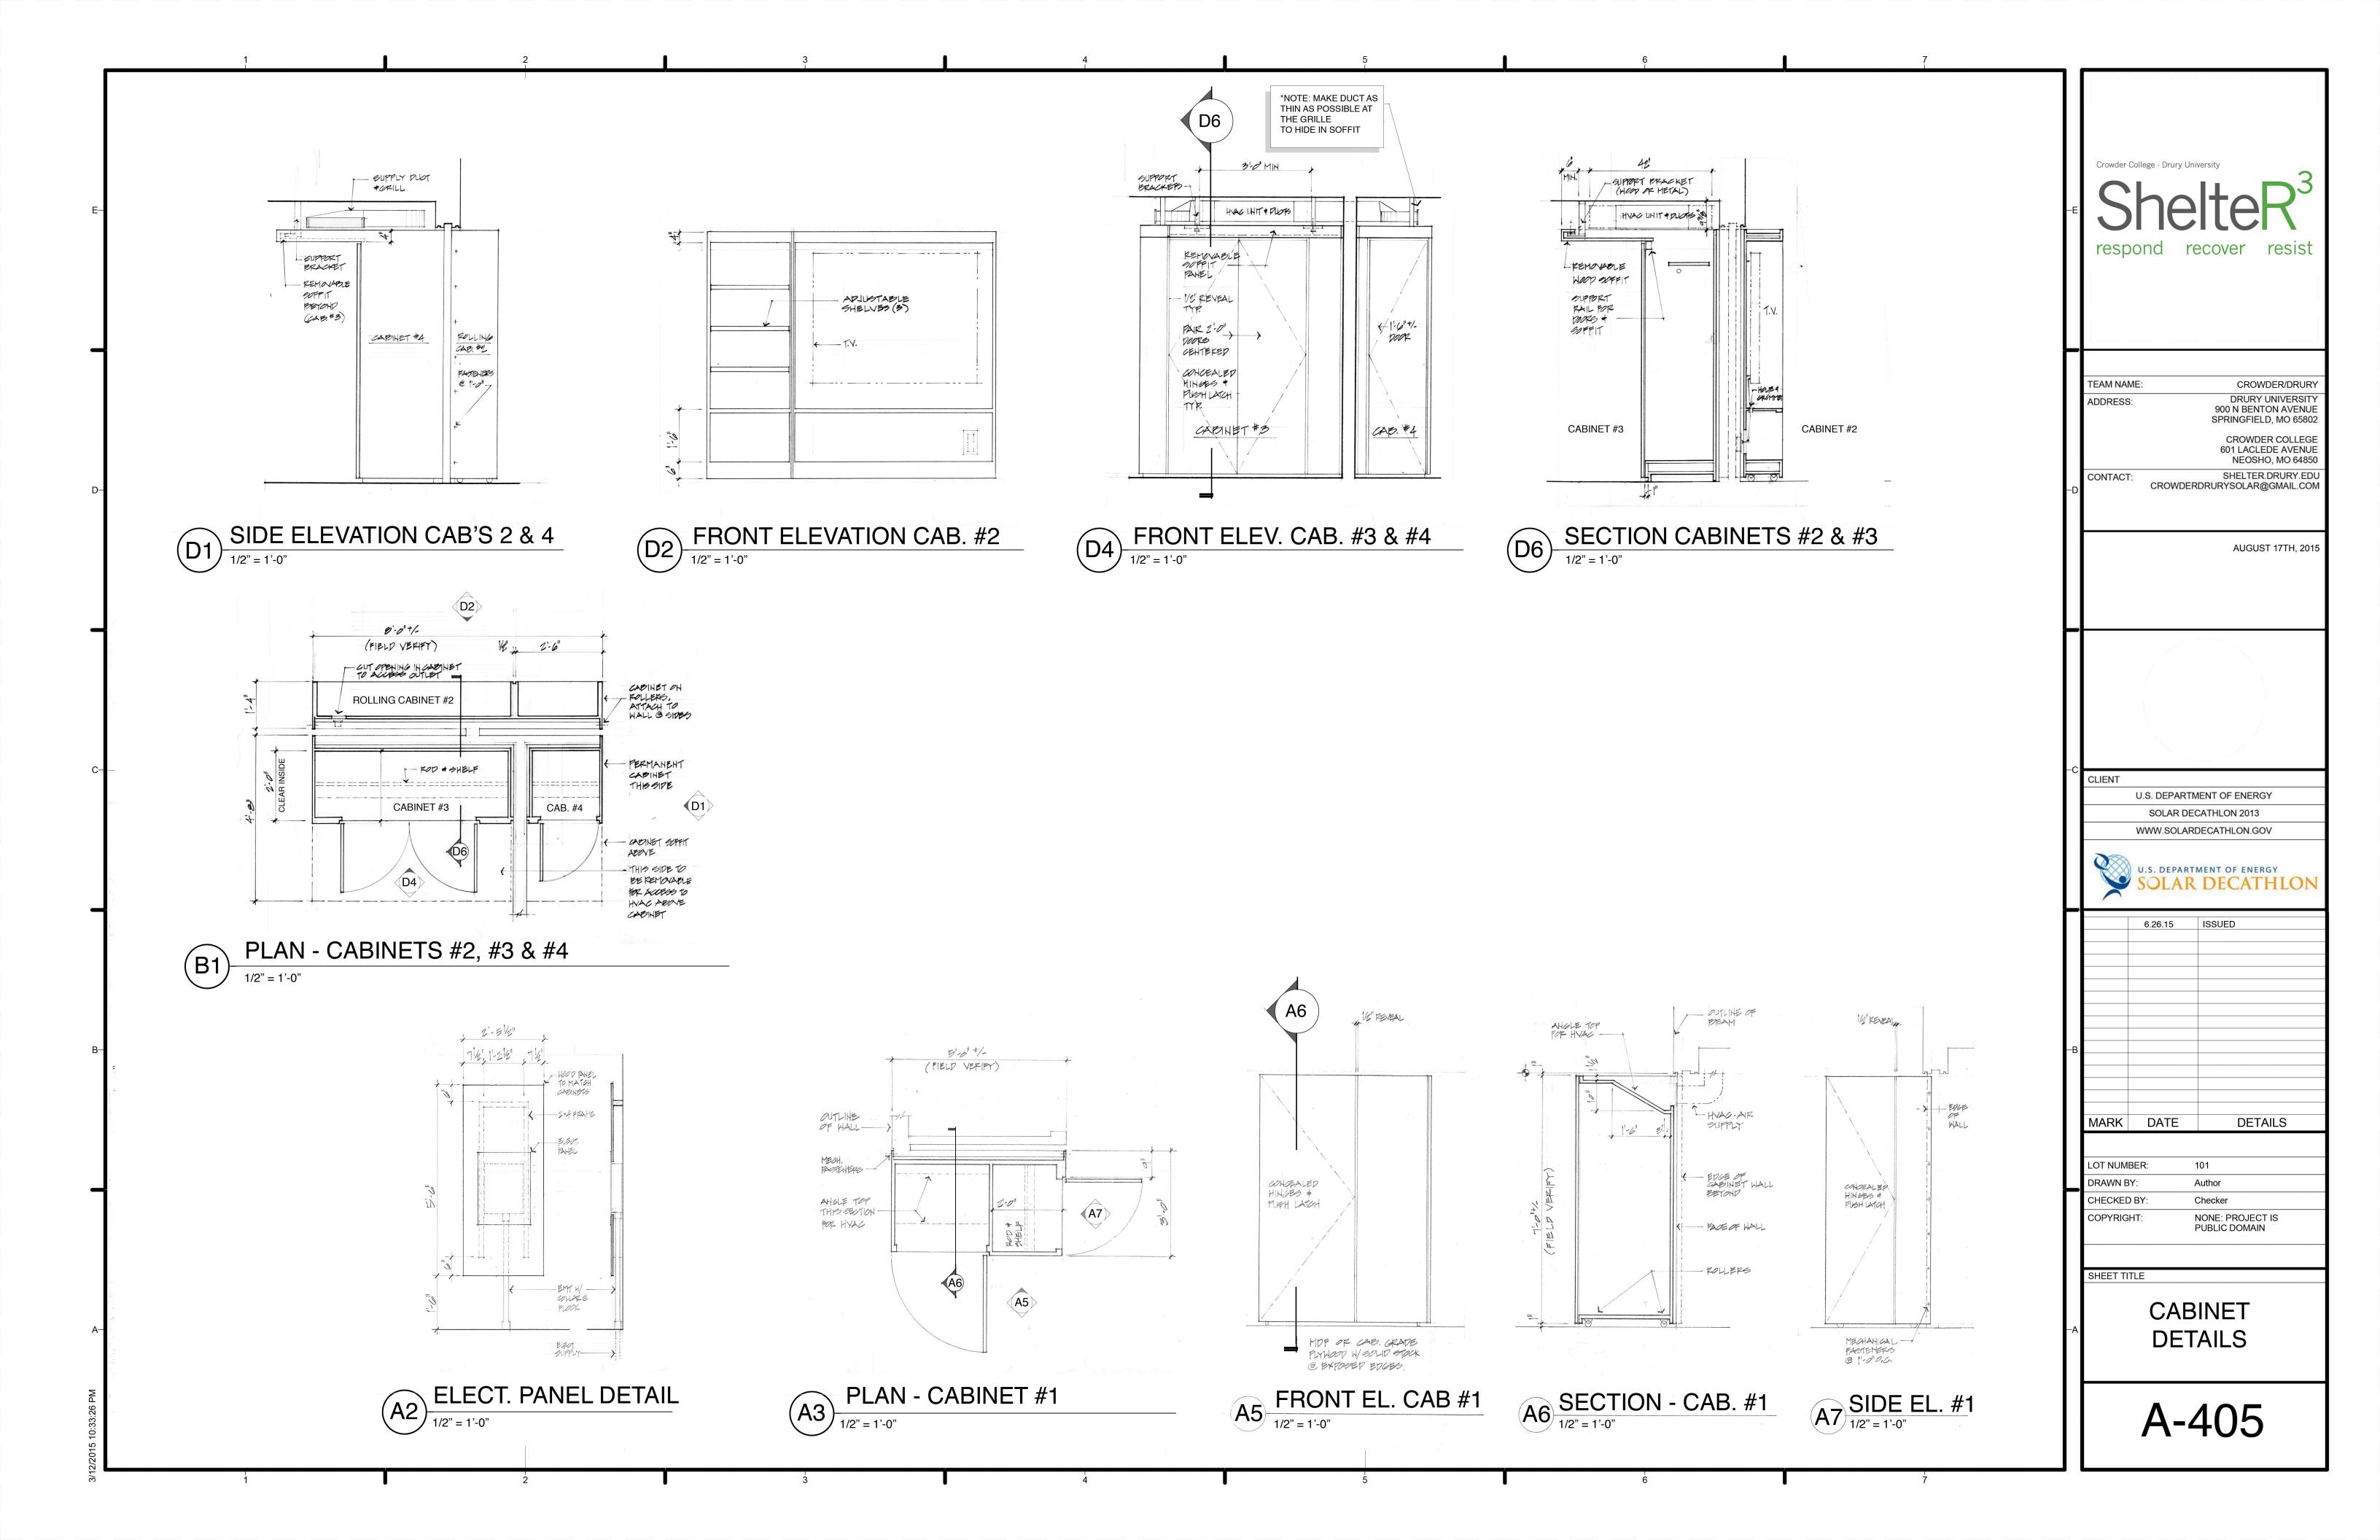













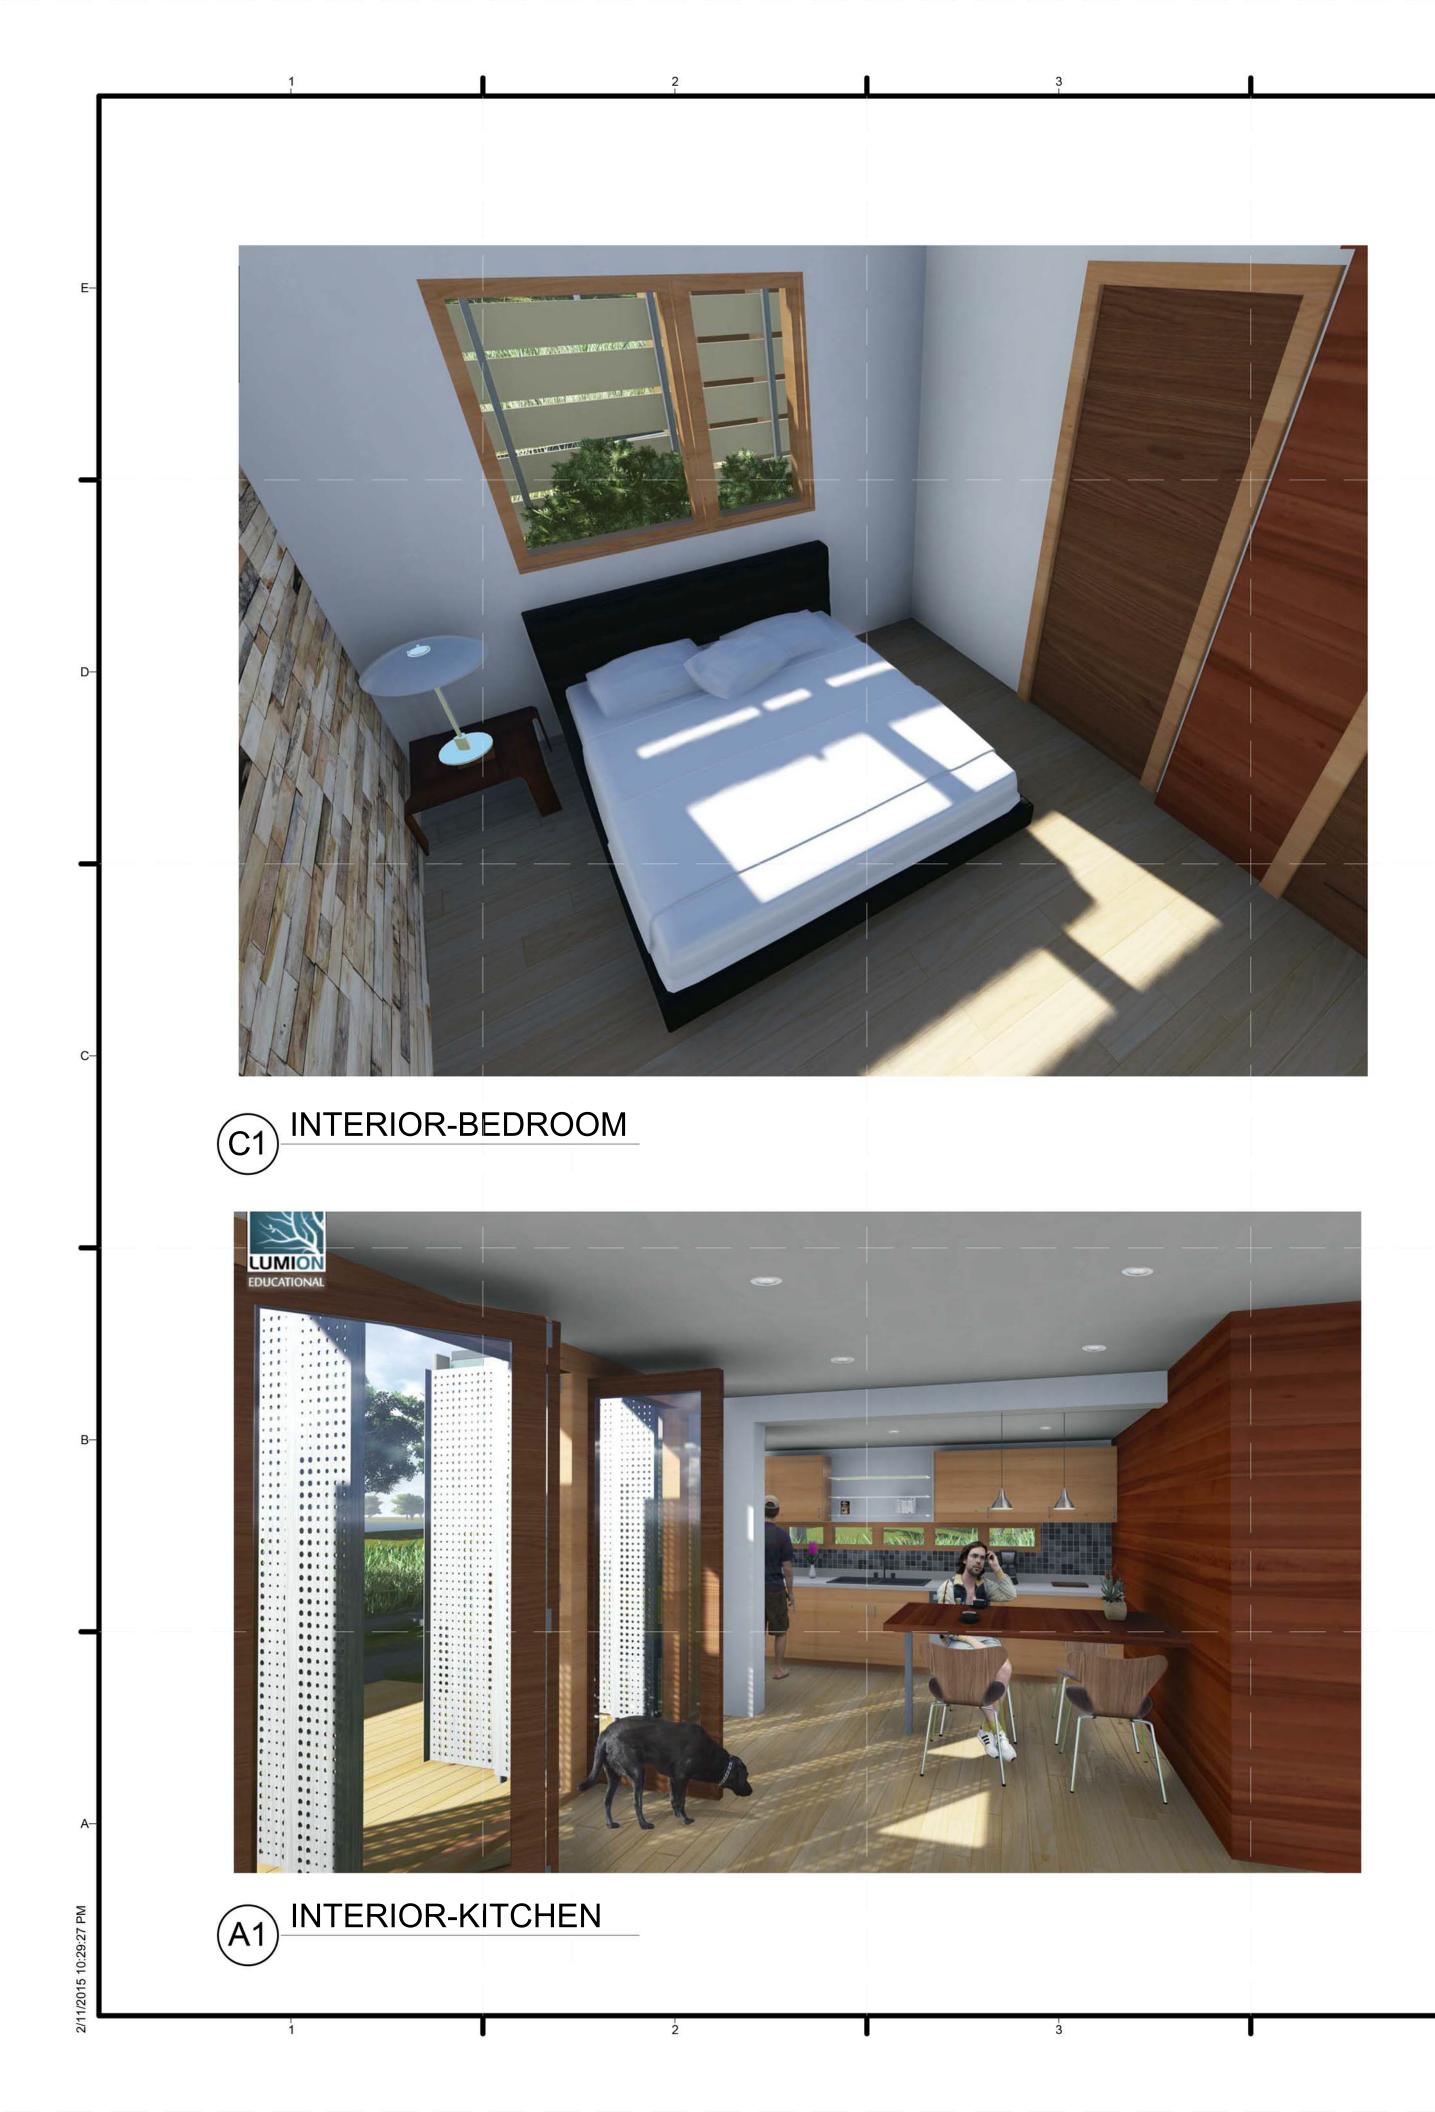








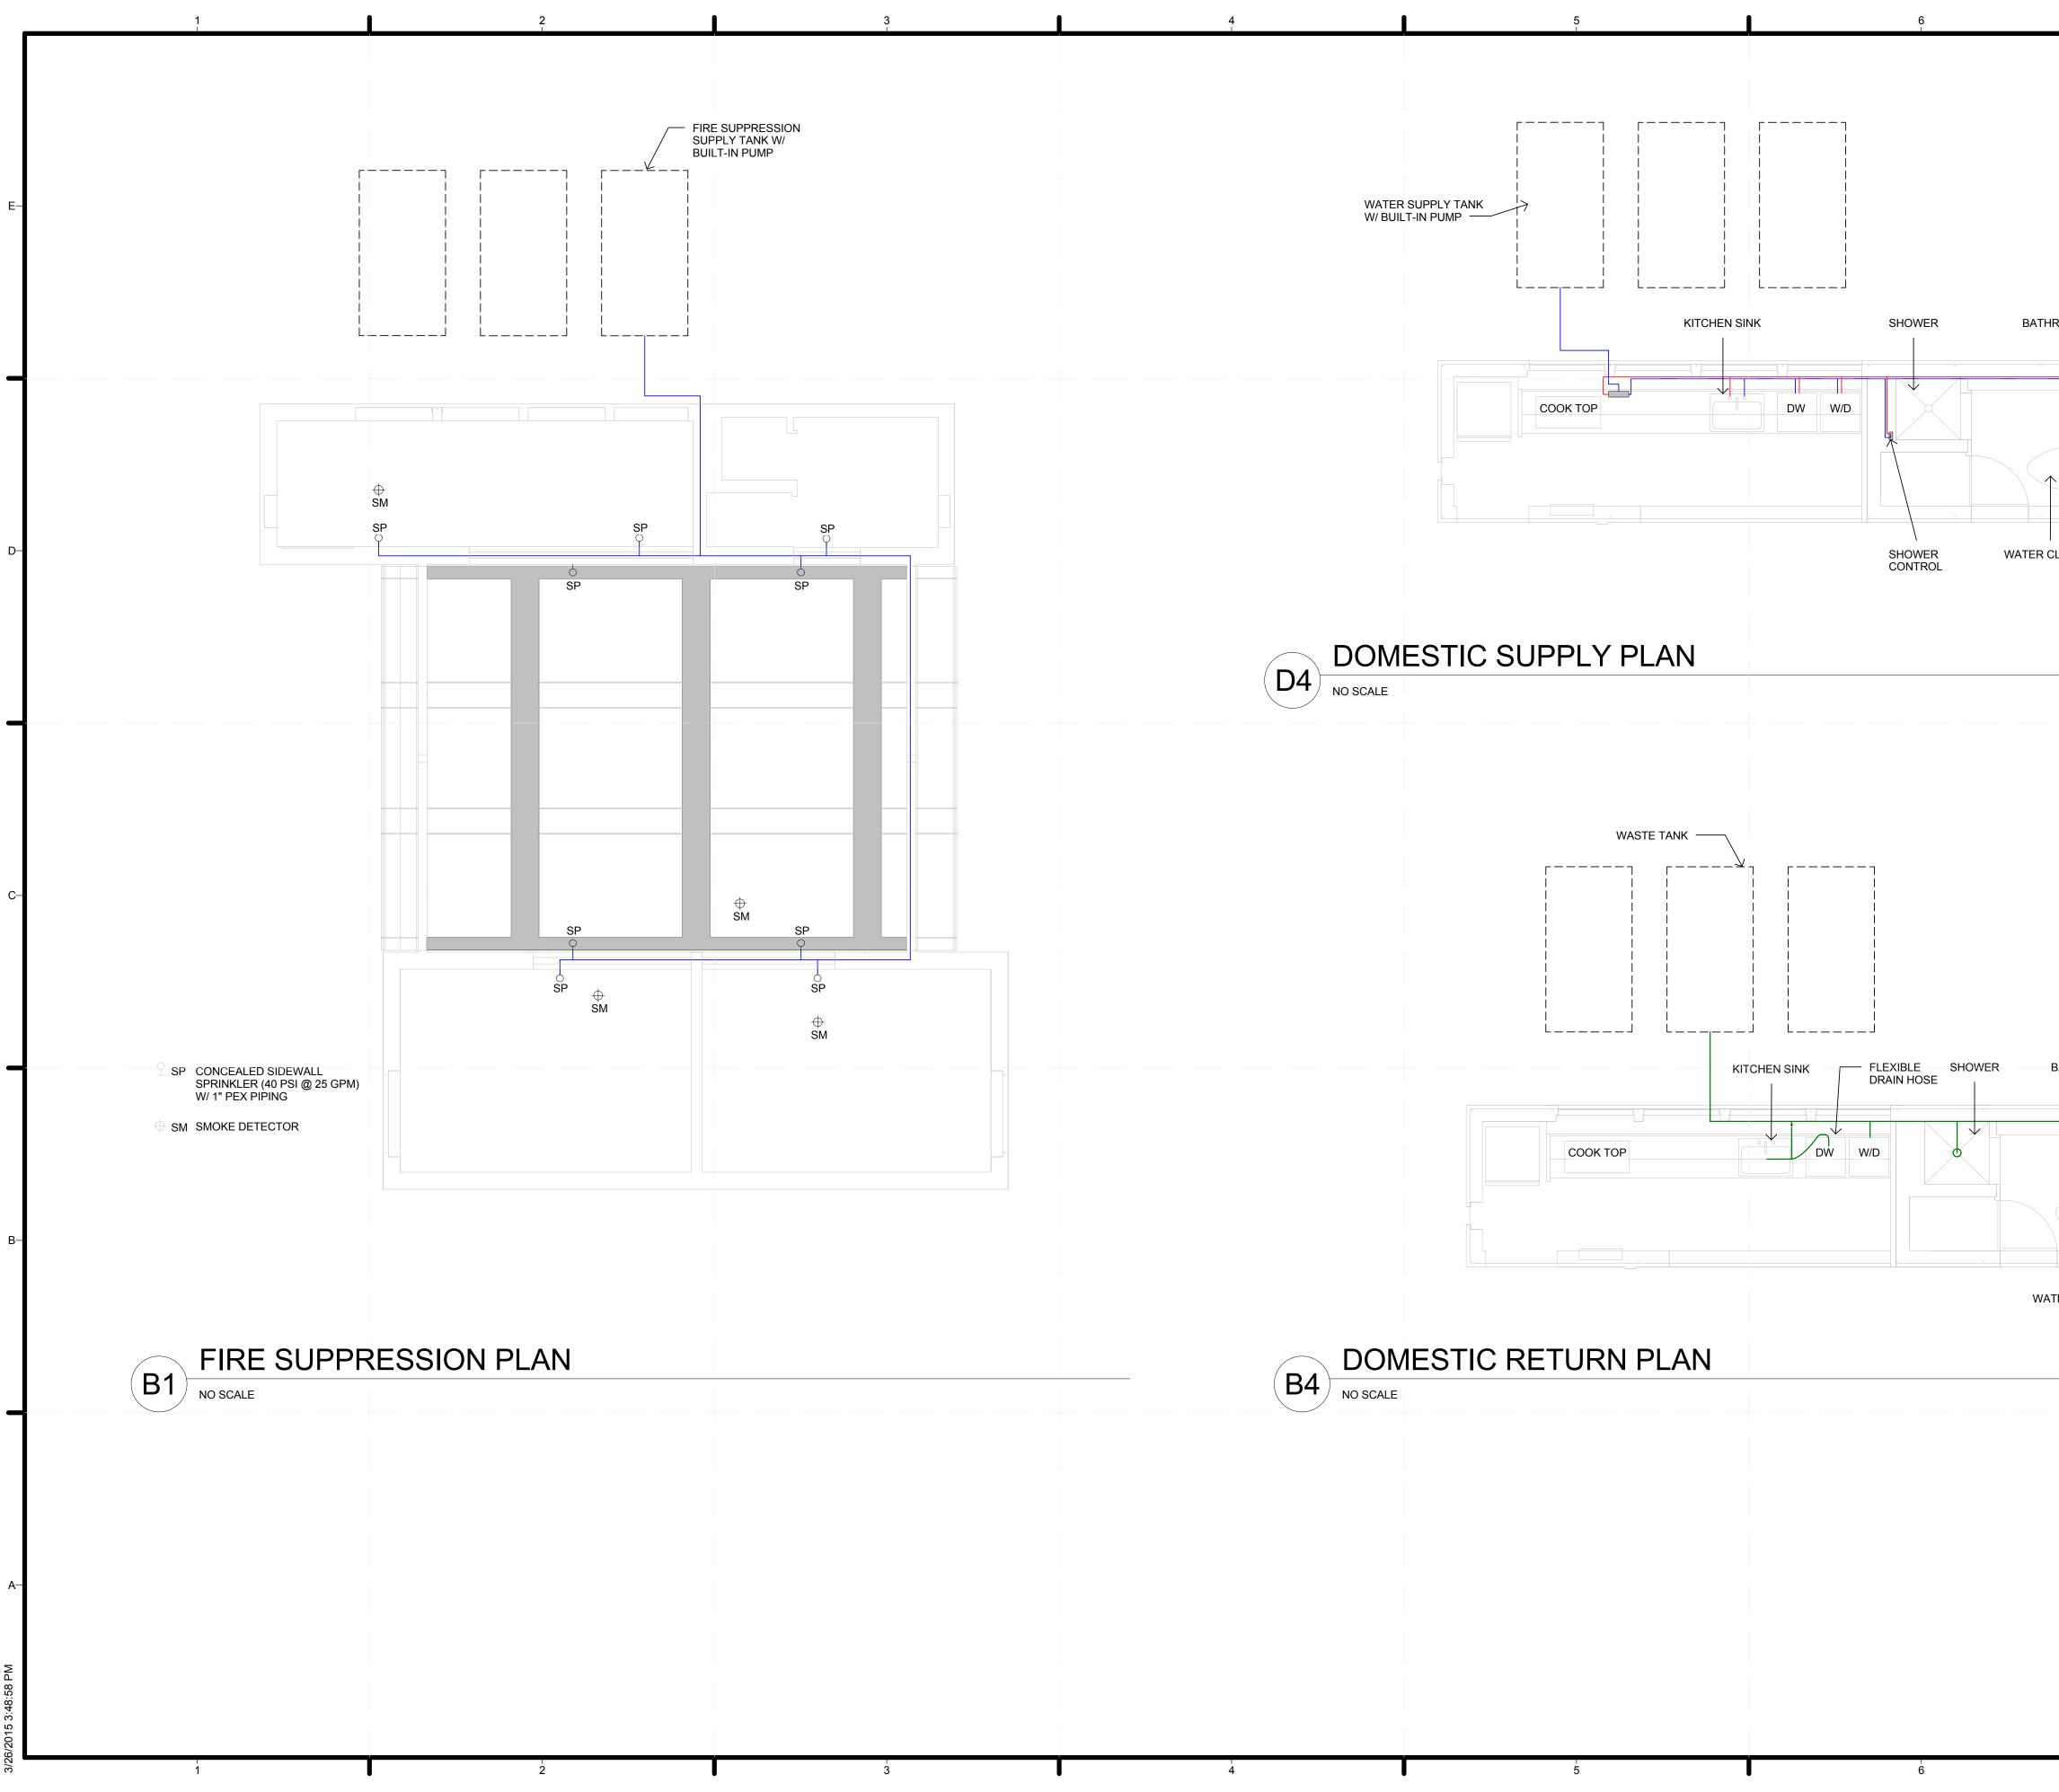


	7				
IROOM SINK		-E	S		niversity etters 3 recover resist
CLOSET		-D	TEAM NAI	; -:	CROWDER/DRURY DRURY UNIVERSITY 900 N BENTON AVENUE SPRINGFIELD, MO 65802 CROWDER COLLEGE 601 LACLEDE AVENUE NEOSHO, MO 64850 SHELTER.DRURY.EDU RDRURYSOLAR@GMAIL.COM
		-c	CLIENT	SOLAR DE WWW.SOLAF	MENT OF ENERGY ECATHLON 2013 RDECATHLON.GOV
BATHROOM SINK		—В	MARK	FEB. 12th 3.26.15	CONSTRUCTION DRAWINGS REVISED
		-A		те MT: MT: MESTI	101 Author Checker NONE: PROJECT IS PUBLIC DOMAIN
	7			P-	101

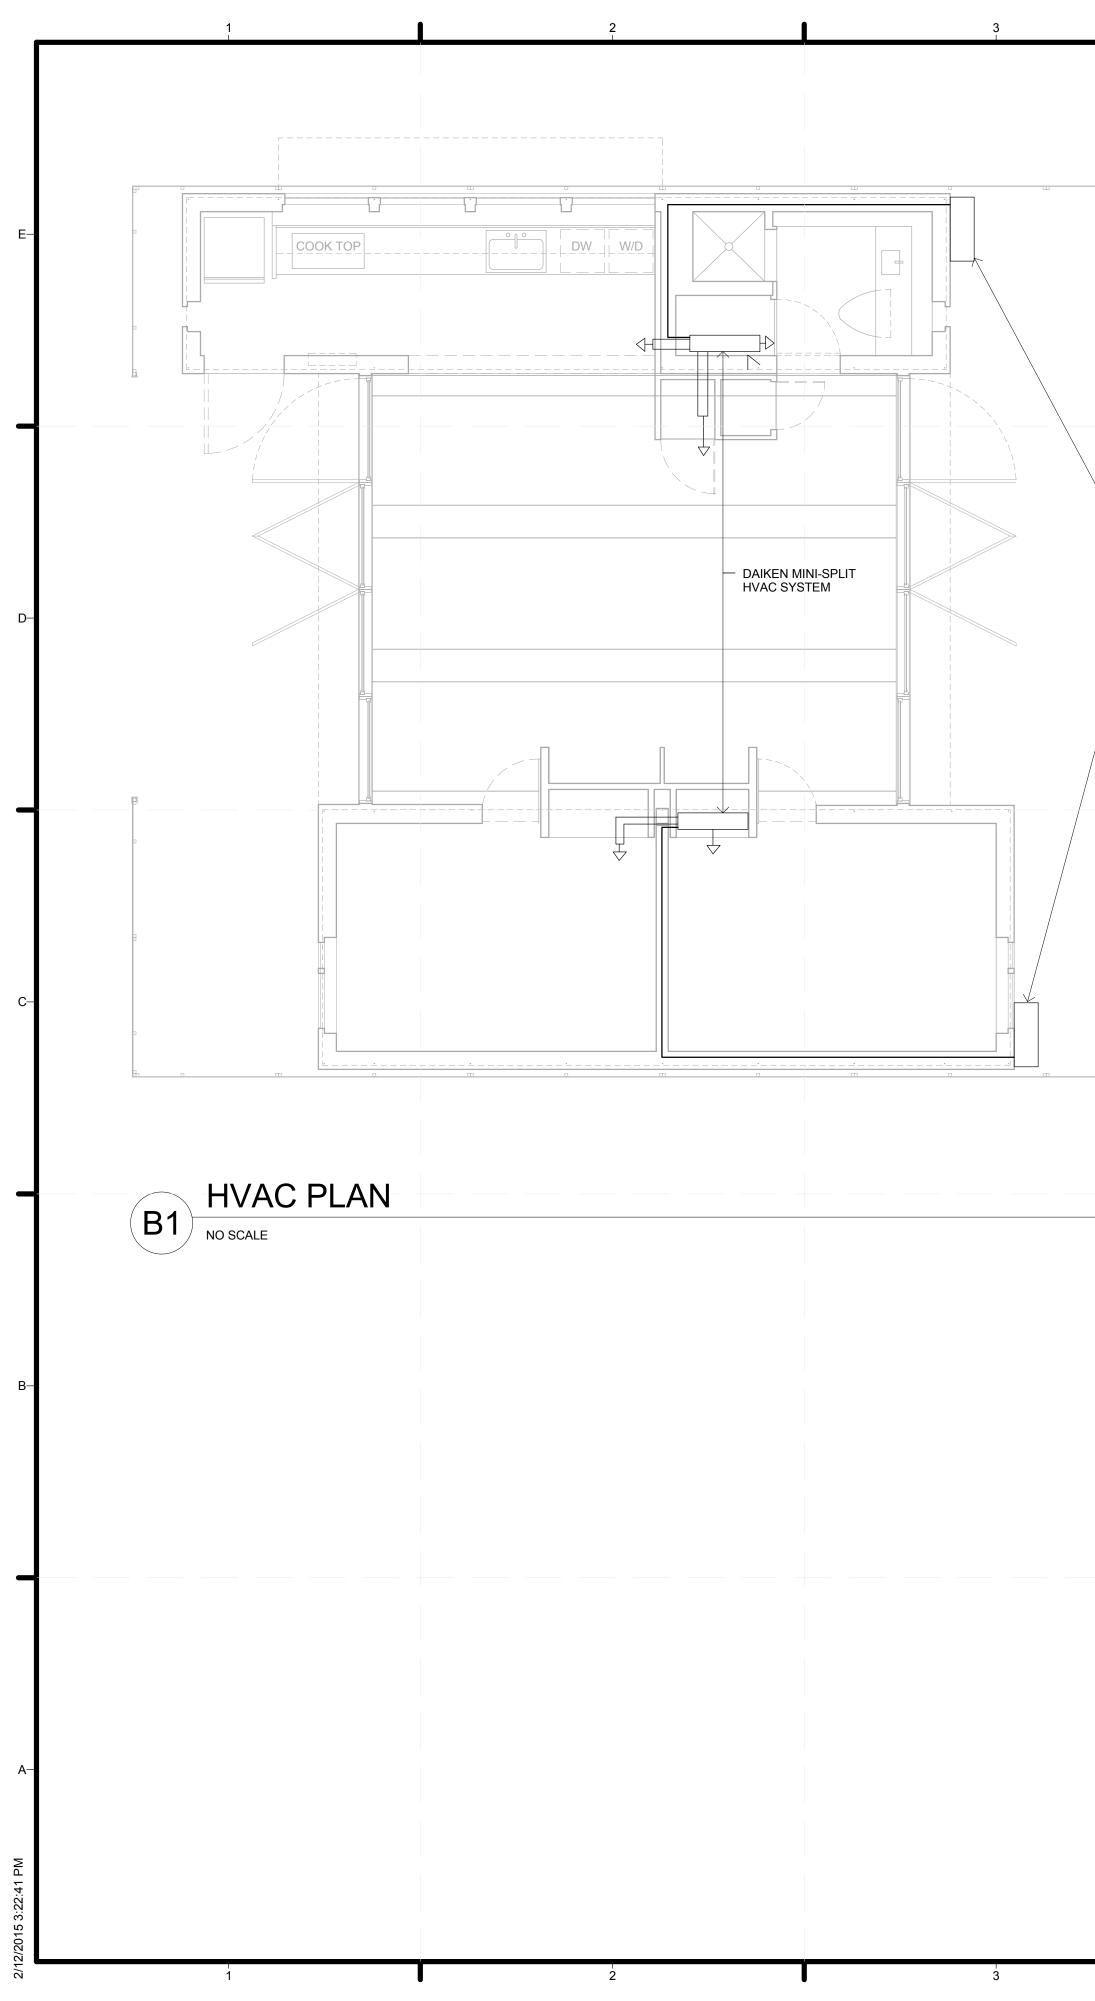


		4	Į	5	e e	3
	— DAIKEN MINI-SPLIT OUTDOOR UNITS					
	5 					
ł						
l	ļ ,	4	Į	5		3

7				
	-Е	S		hiversity <b>IteR<sup>3</sup></b> recover resist
	-D	TEAM NAM ADDRESS	:	CROWDER/DRURY DRURY UNIVERSITY 900 N BENTON AVENUE SPRINGFIELD, MO 65802 CROWDER COLLEGE 601 LACLEDE AVENUE NEOSHO, MO 64850 SHELTER.DRURY.EDU RDRURYSOLAR@GMAIL.COM
	-c	CLIENT	SOLAR DE WWW.SOLAR	MENT OF ENERGY CATHLON 2015 DECATHLON.GOV MENT OF ENERGY DECATHLON
	-в		FEB. 12th	CONSTRUCTION DRAWINGS
	-A	MARK LOT NUME DRAWN B CHECKED COPYRIGI	Y: BY: HT: TLE	DETAILS 101 Author Checker NONE: PROJECT IS PUBLIC DOMAIN CPLAN
7			M-	101

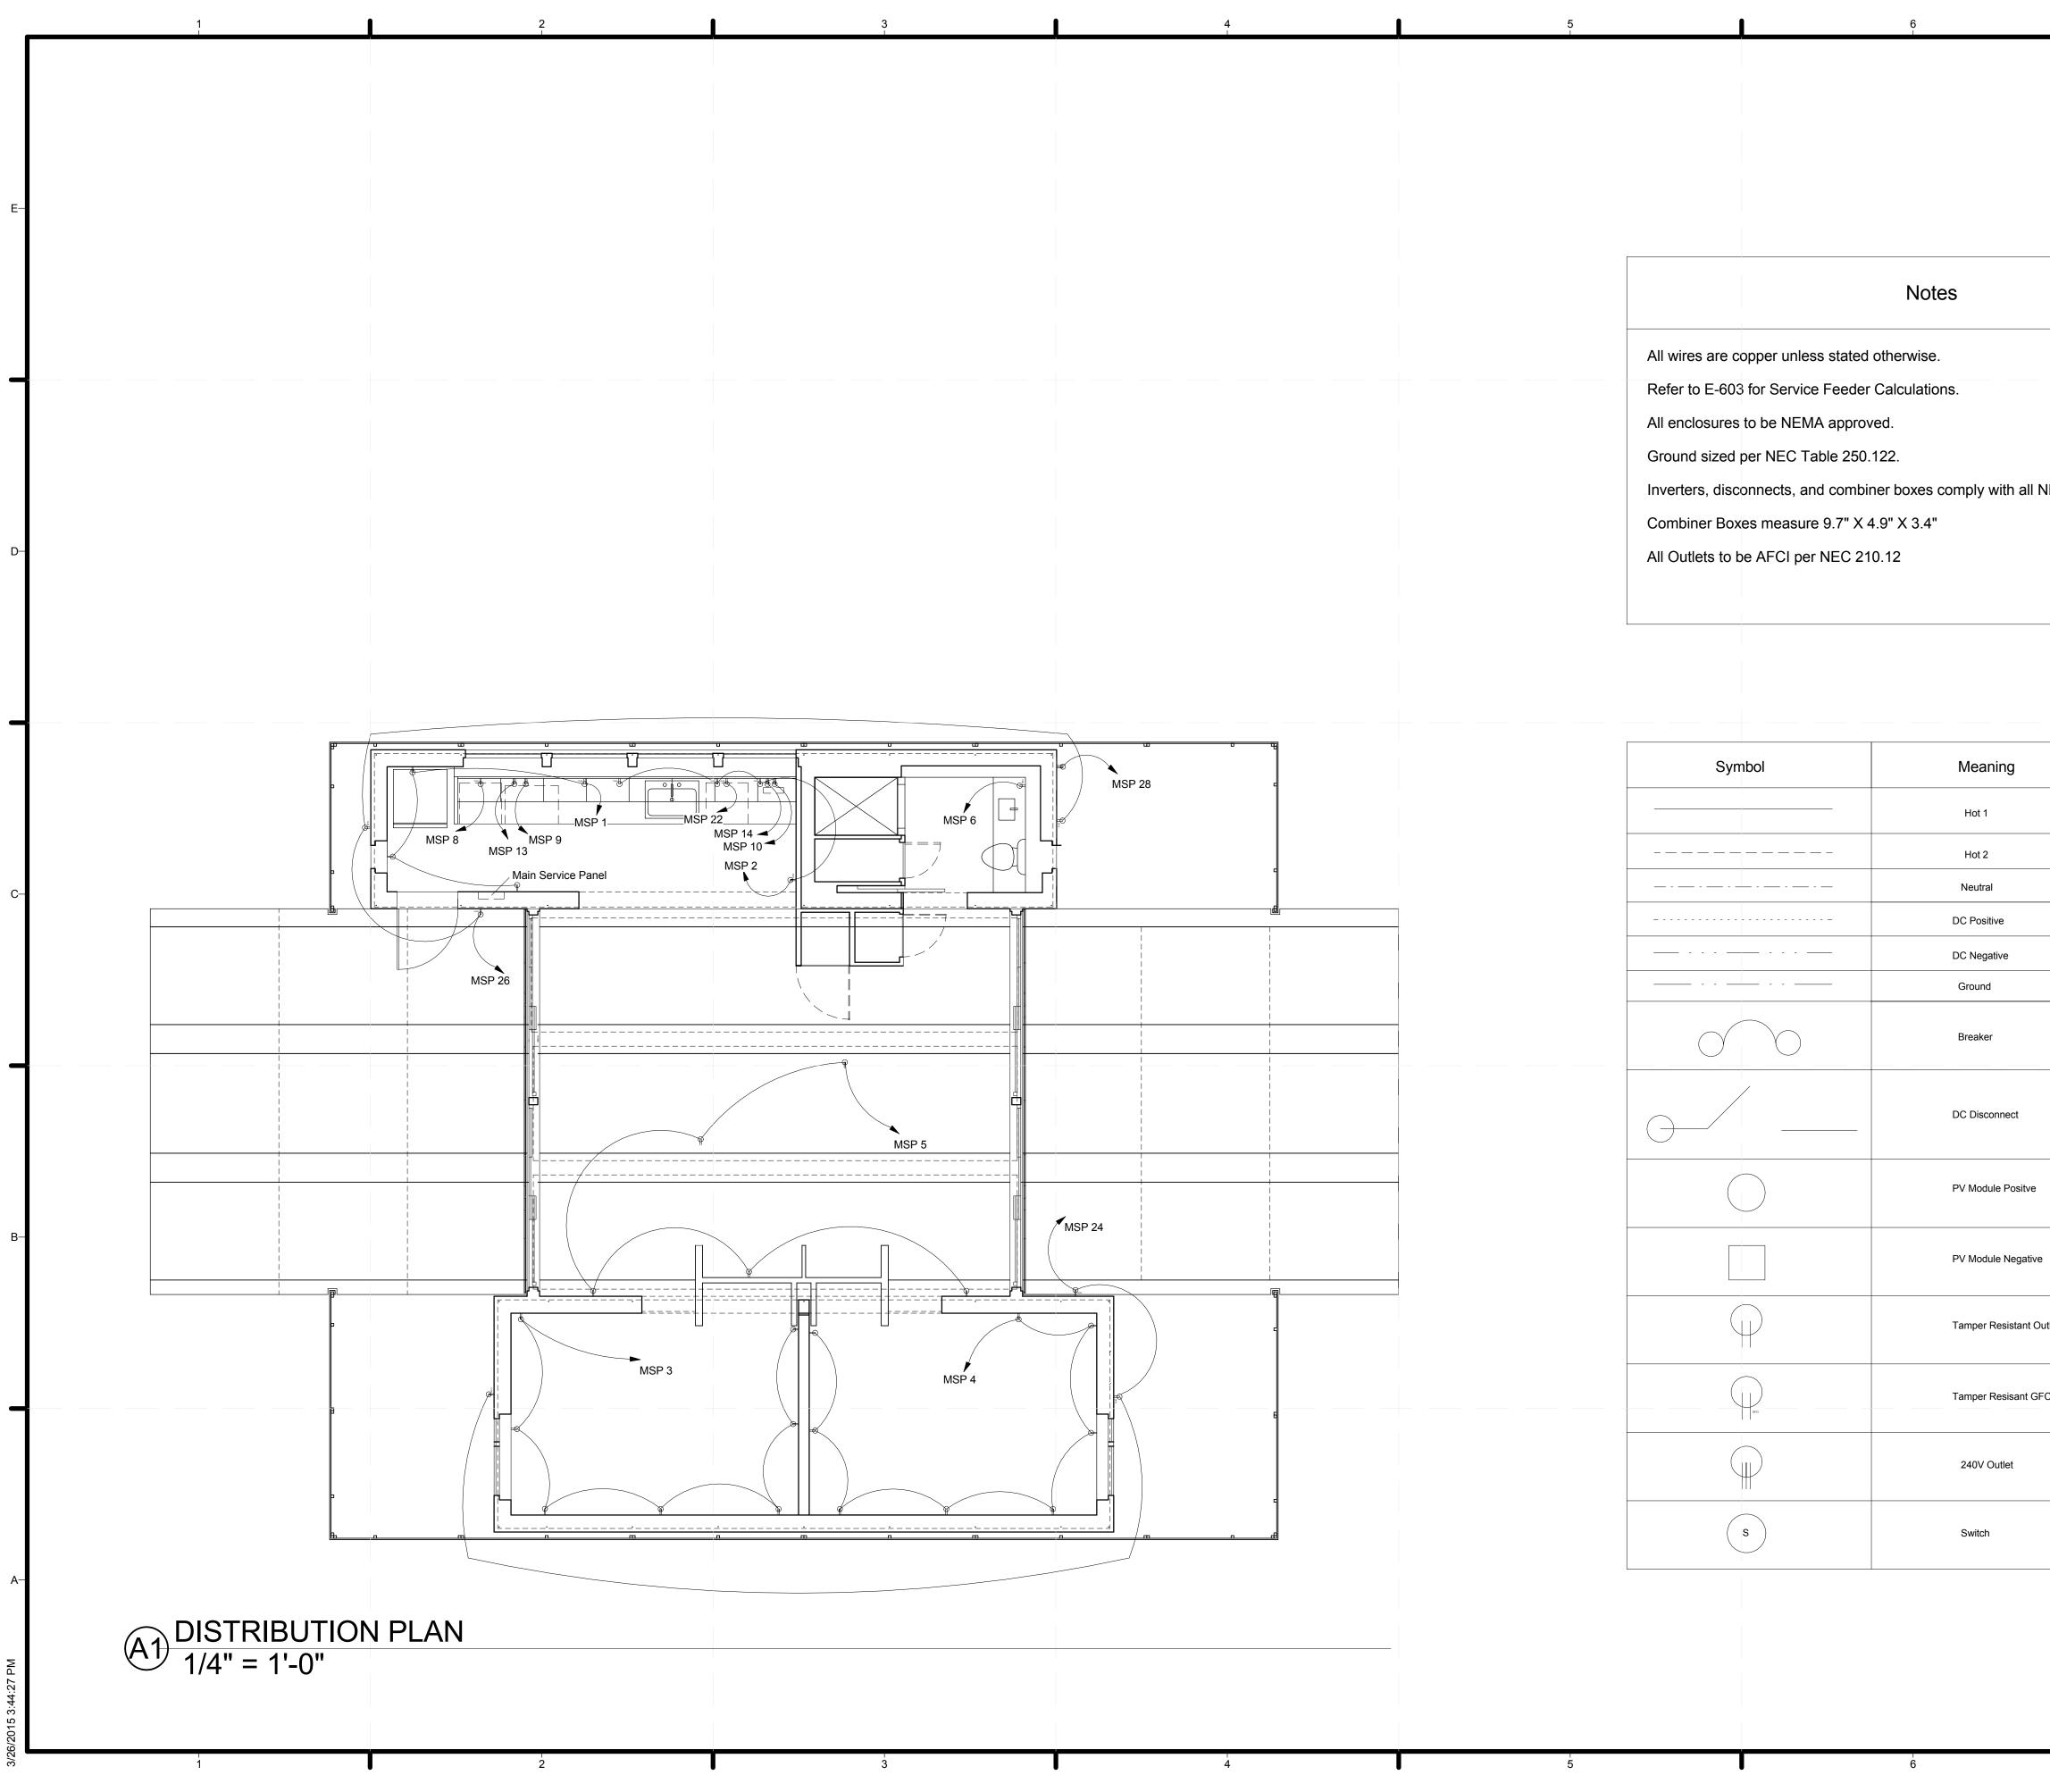

	7		
		-E	crowder College - Drury University Shelter 3 respond recover resist
NEC codes.		-D	TEAM NAME:       TEAM TEMPLATE         ADDRESS:       DRURY UNIVERSITY         900 N BENTON AVENUE       SPRINGFIELD, MO 65802         CROWDER COLLEGE       601 LACLEDE AVENUE         NEOSHO, MO 64850       NEOSHO, MO 64850         CONTACT:       SHELTER.DRURY.EDU         CROWDERDRURYSOLAR@GMAIL.COM       AUGUST 17TH, 2015
		C	CLIENT U.S. DEPARTMENT OF ENERGY SOLAR DECATHLON 2013 WWW.SOLARDECATHLON.GOV
e ve Outlet		—В	FEB. 12th       CONSTRUCTION DRAWINGS         3.26.15       REVISED         Image: Stress of the
GFCI Outlet		—A	DRAWN BY: Author CHECKED BY: Checker COPYRIGHT: NONE: PROJECT IS PUBLIC DOMAIN SHEET TITLE DISTRIBUTION PLAN E-101

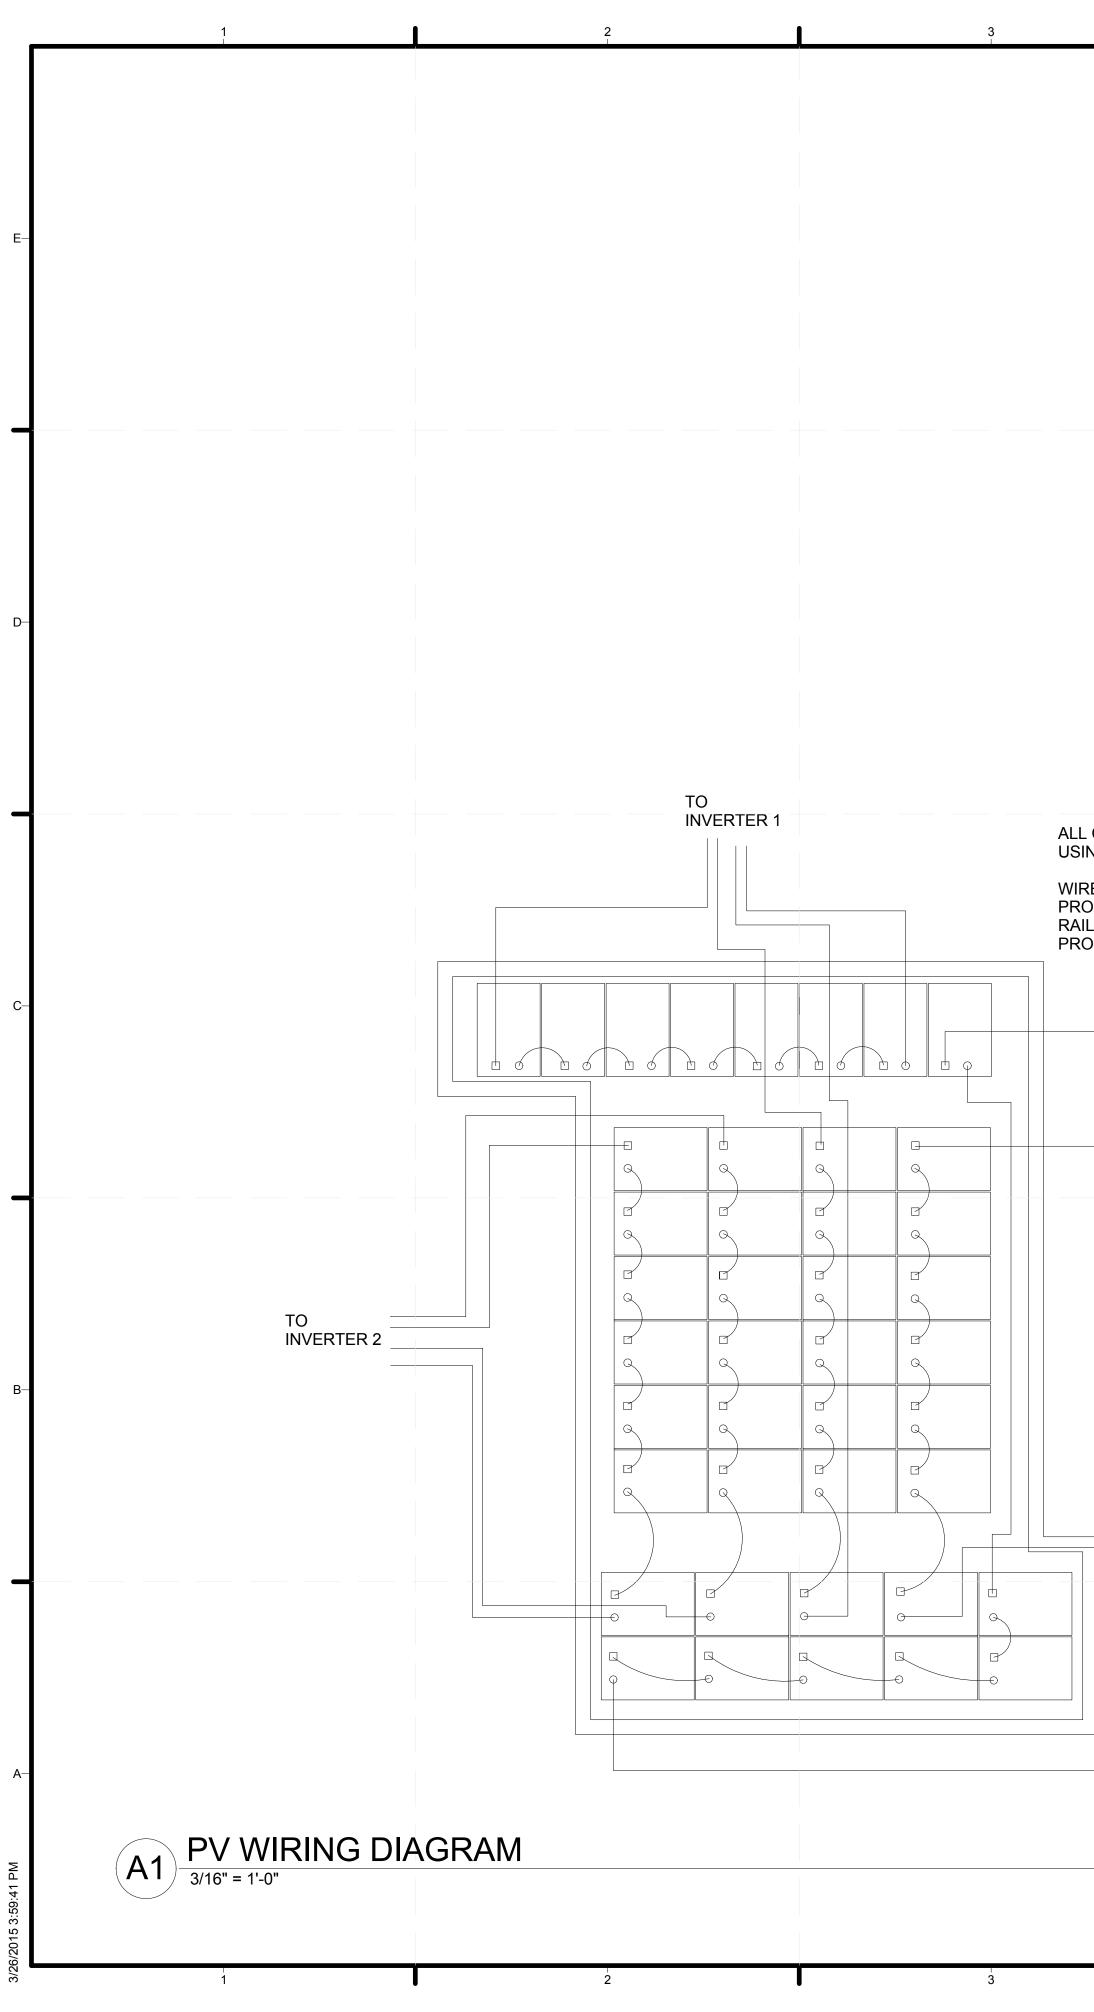

		S	olar Array Sp	ecs	
	Module	String	Sub Array A	Sub Array B	Sub Array
Pnom	335 W	2345 W	4690 W	4690 W	4690 W
Vmp	57.3	401.1	401.1	401.1	40
Imp	5.85	5.85	11.7	11.7	1
Voc	67.9	475.3	475.3	475.3	47
lsc	6.23	6.23	12.46	12.46	12
Max Voltage	600VDC				
Power Temp Coef	30%/C	30%/C	30%/C	30%/C	30%/C
Voltage Temp Coef	-167.4 mV/C	-167. <mark>4 mV/C</mark>	-167.4 mV/C	-167.4 mV/C	-167.4 mV/C
Current Temp Coef	3.5 mA/C	3.5 mA/C	3.5 mA/C	3.5 mA/C	3.5 mA/C

ALL CONNECTIONS MADE USING MC4 CONNECTORS,


WIRES TO BE CLEANLY AND PROPERLY ZIP TIED TO THE RAILS TO SUPPORT AND PROTECT THEM.

TO INVERTER 3


4

5

		7				
1.1	kW DC		E	S		niversity etters and a second state of the sec
1.7 5.3 30% C -167.4	/C mV/C		—D	TEAM NAM ADDRESS	:	DRURY UNIVERSITY 900 N BENTON AVENUE SPRINGFIELD, MO 65802 CROWDER COLLEGE 601 LACLEDE AVENUE NEOSHO, MO 64850 SHELTER.DRURY.EDU RDRURYSOLAR@GMAIL.COM
3.5 m	A/C		-C	CLIENT		AUGUST 17TH, 2015
					WWW.SOLAF	ECATHLON 2013 RDECATHLON.GOV TMENT OF ENERGY DECATHLON CONSTRUCTION DRAWINGS REVISED
			—В	MARK LOT NUME DRAWN B CHECKED COPYRIGI	Y: BY: HT:	DETAILS  Project Number Author Checker NONE: PROJECT IS PUBLIC DOMAIN  G DIAGRAM
		7			E-	102

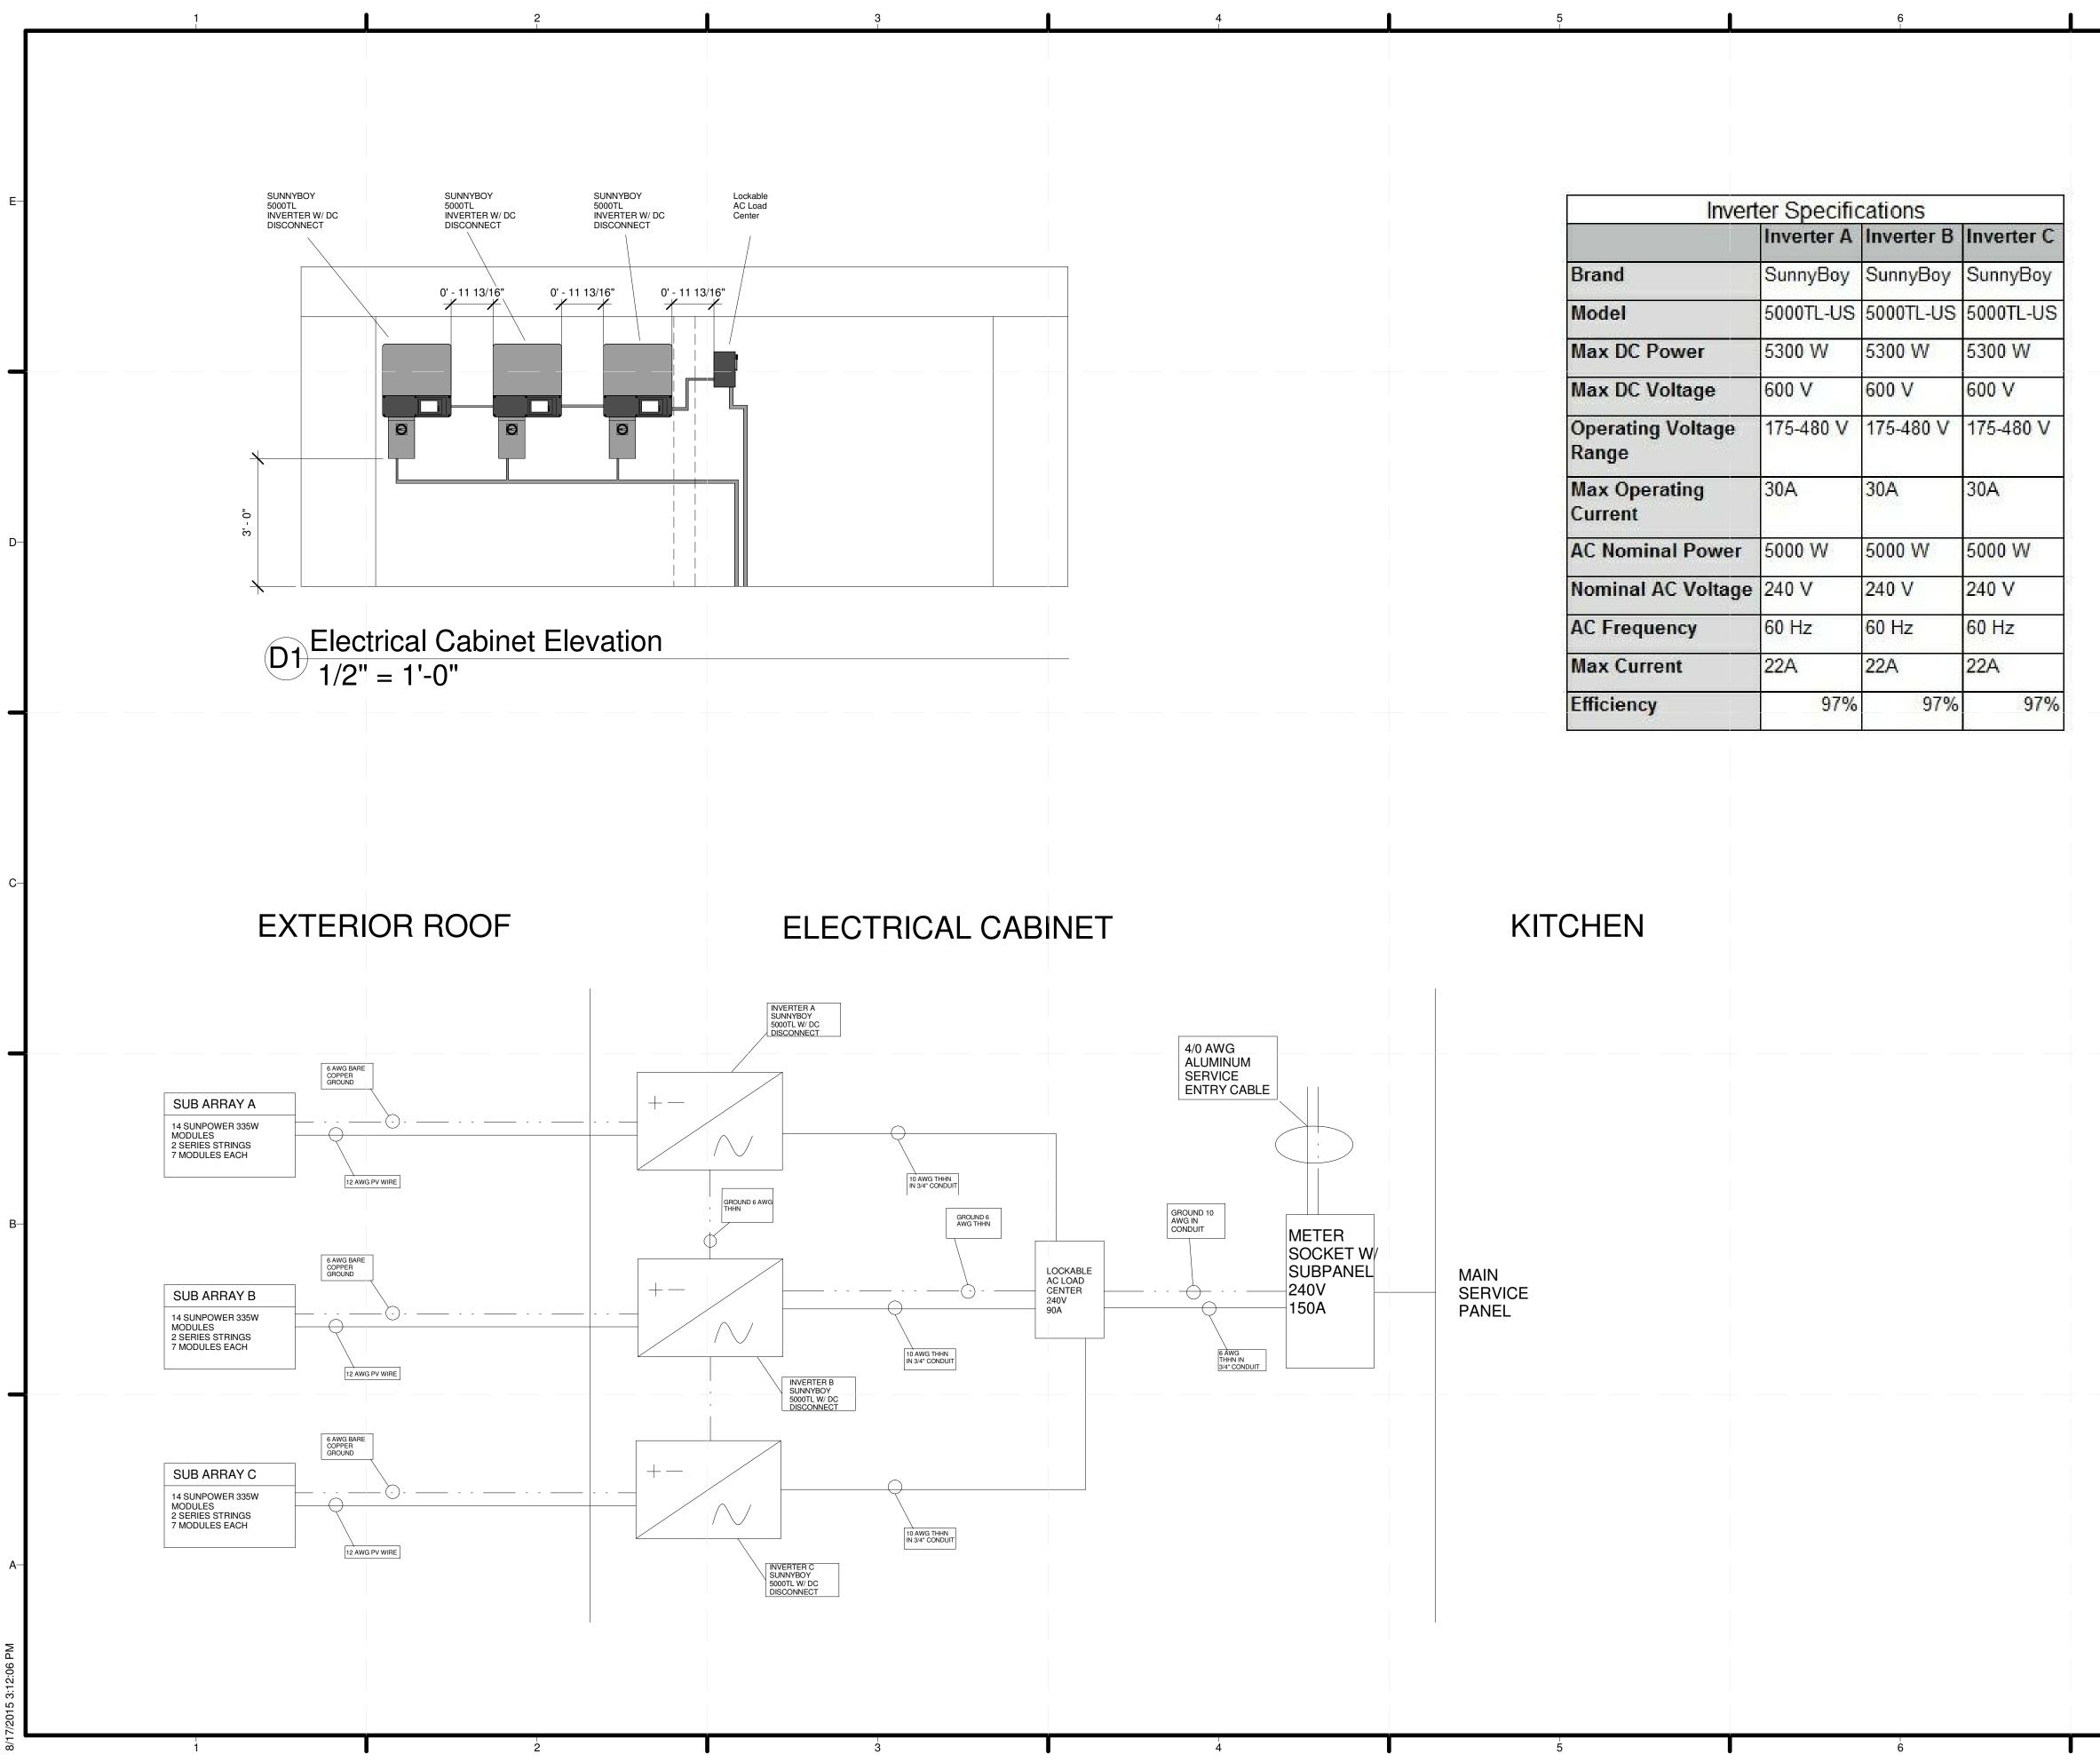

5		6	
		·-	
Inven	ter Specific Inverter A		Inverter C
Brand	SunnyBoy	SunnyBoy	SunnyBoy
Model	5000TL-US	5000TL-US	5000TL-US
Max DC Power	5300 W	5300 W	5300 W
Max DC Voltage	600 V	600 V	600 V
Operating Voltage Range	175-480 V	175-480 V	175-480 V
Max Operating	30A	30A	30A
Current	5000 W	5000 W	5000 W
AC Nominal Power Nominal AC Voltage		240 V	240 V
AC Frequency	60 Hz	240 V 60 Hz	240 V 60 Hz
Max Current	22A	22A	22A
Efficiency	97%		
		I <u></u>	
CHEN			
UTEN			
5		6	

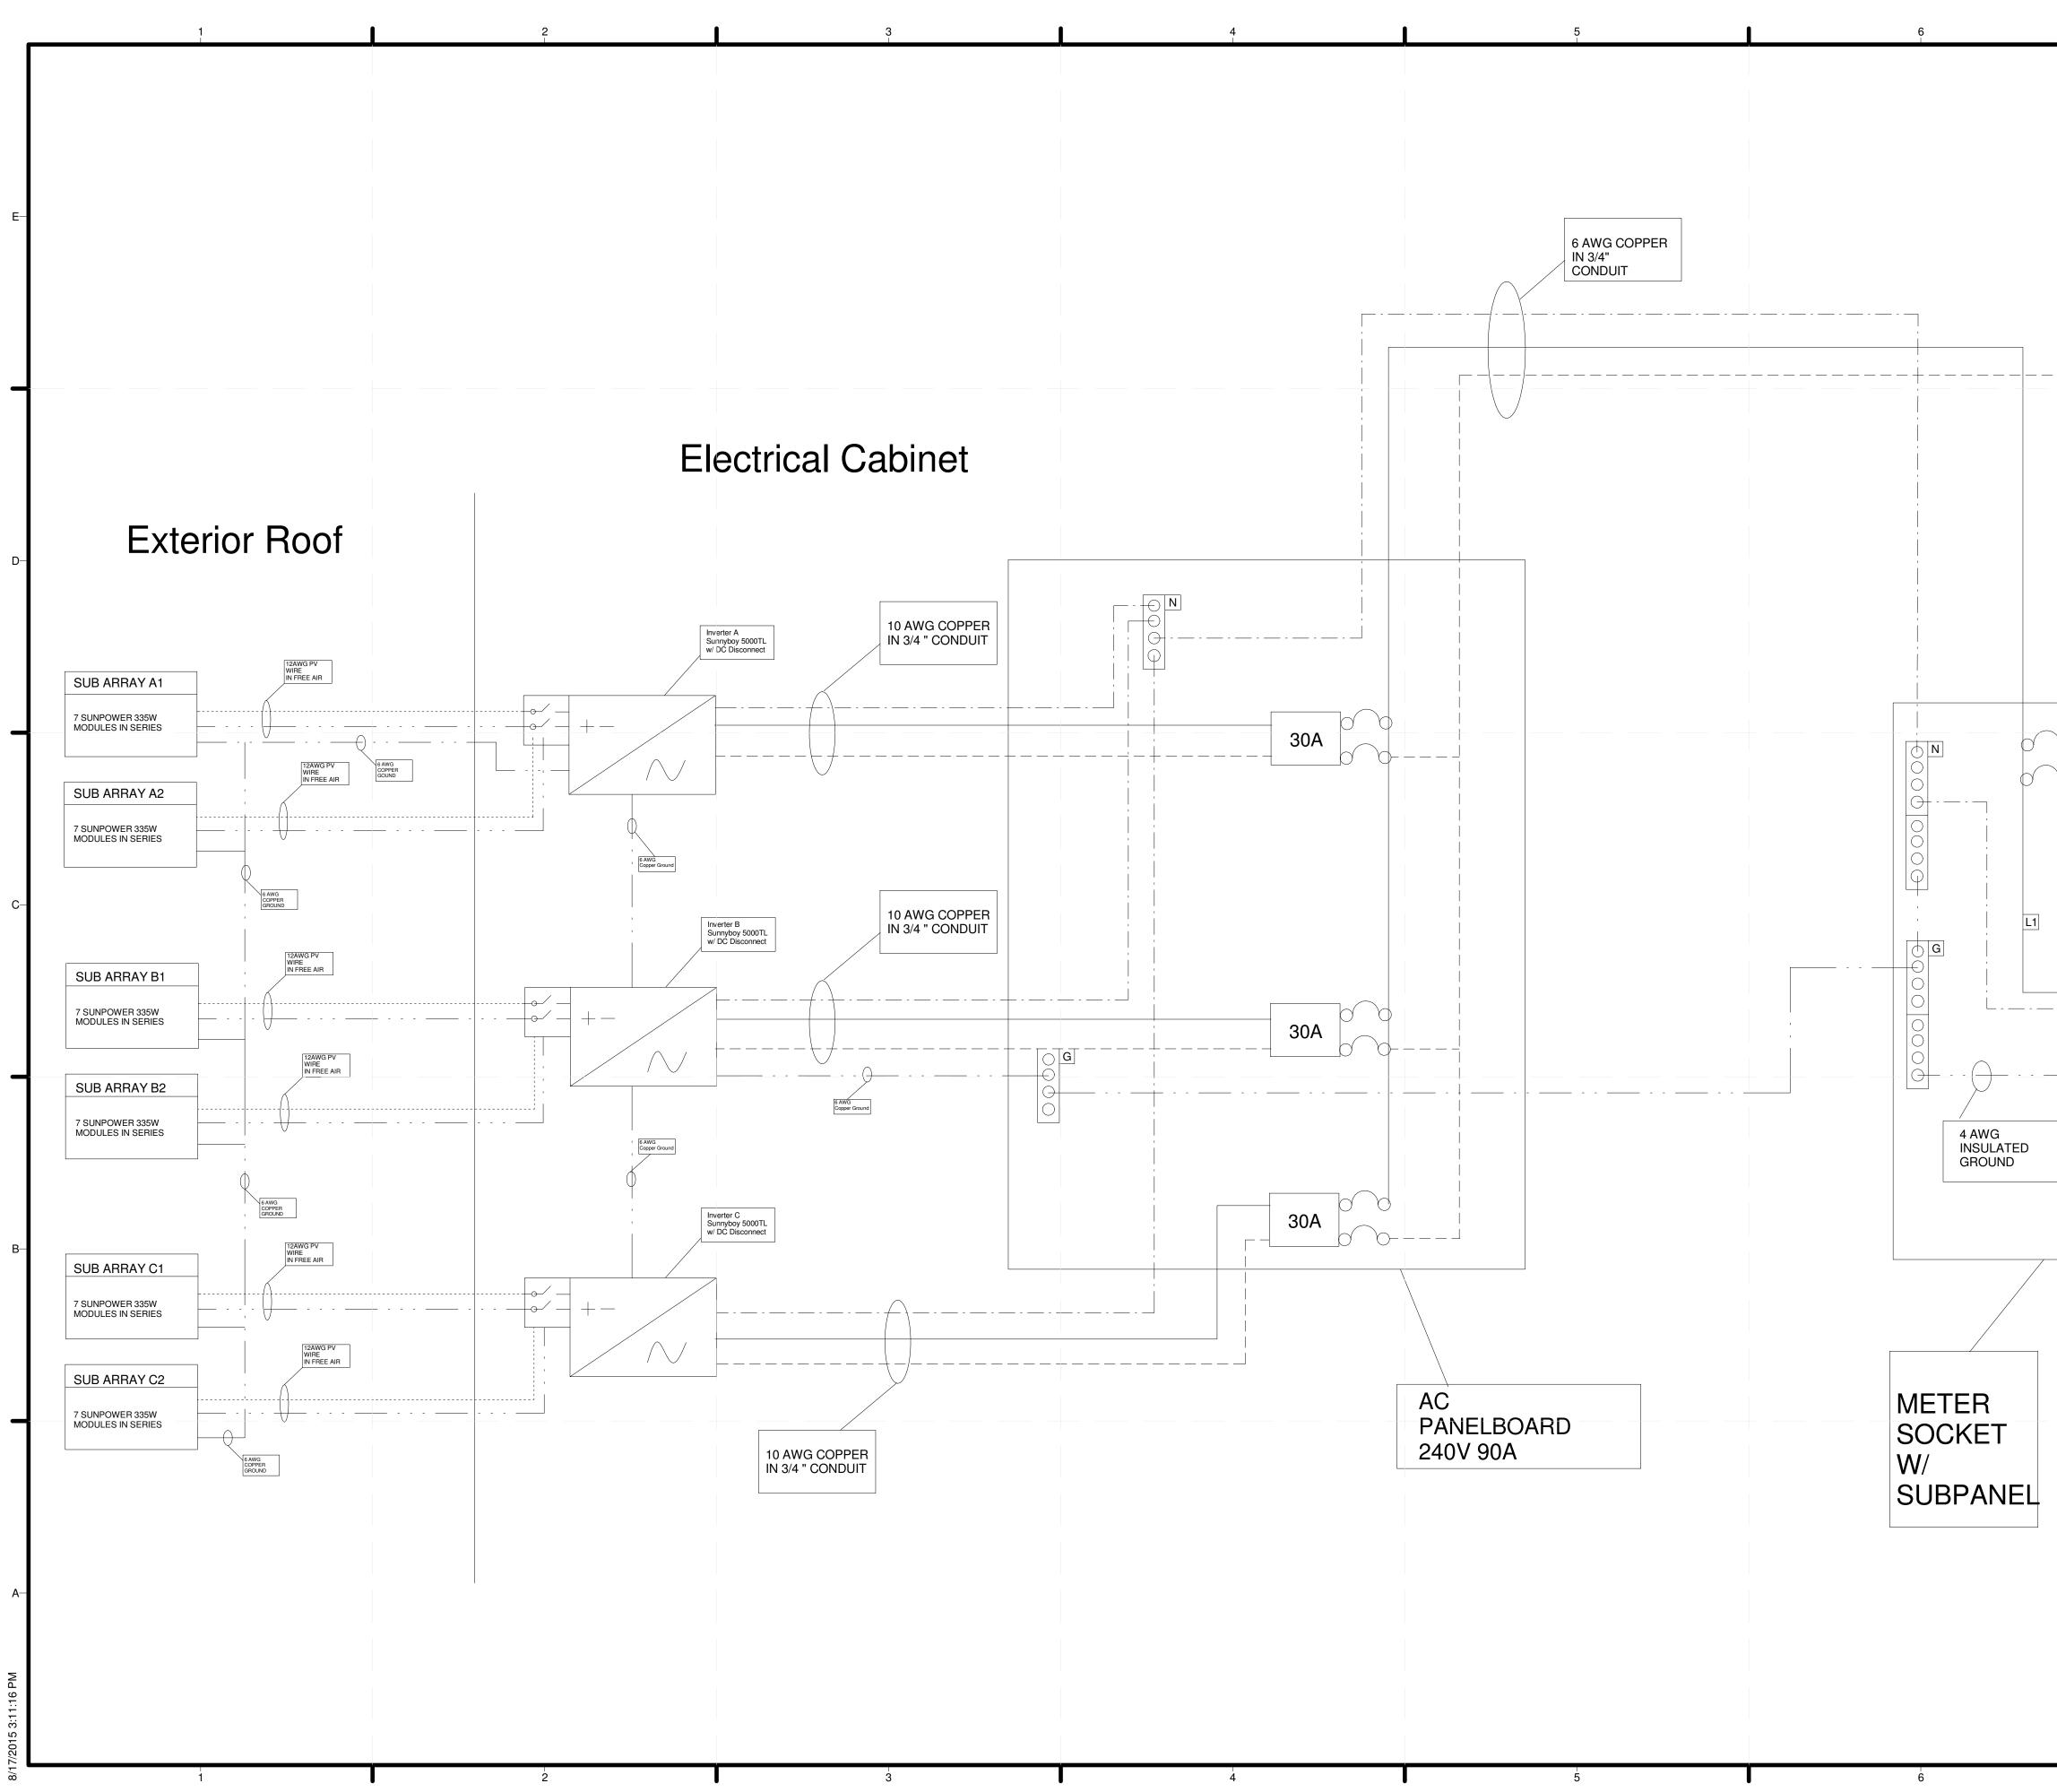


	E	Crowder College - Drury University Sheeteer and a strain of the strain
90A 4/0 AWG ALUMINUM SERVICE ENTRY CABLE	C	CLIENT U.S. DEPARTMENT OF ENERGY SOLAR DECATHLON 2013 WWW.SOLARDECATHLON.GOV
	—В	FEB. 12th       CONSTRUCTION DRAWINGS         FEB. 12th       CONSTRUCTION DRAWINGS         Harrison       Harrison         Sheet Title       HARE LINE DIAGRAM
7		E-602


		Main Service F	anel Schedule		
Space	Name	CB Size	Space	Name	CB
1	Small Appliance 1	20	2	Small Appliance 2	2
3	Living Space	20	4	Bathroom	2
5	Kitchen Lights	20	6	Laundry Circuit	20
7	Cratter	40	8	Taulda a Mista Ilasta	a i
9	Cooktop	40	10	Tankless Water Heater	-40
11			12		
13	Oven	30	14	Tankless Water Heater	.40
15			16	Dishwasher	12
17	HVAC 1	15	18	Exterior 1	2(
19		Contraction of the second s	20		
21	Dry Module Panel	60	22	EV Charger	30
23	Refrigerator	20	24	Smoke Alarm	20
25	Empty		26	Empty	20
27	Empty		28	Empty	
29	Empty		30	Empty	~
	Name	Dry Module Pa			CB S
Space 1	Name	Dry Module Pa CB Size	anel Schedule Space 2	Name Empty	CB S
Space 1 3	Name		Space           2           4	Name Empty Empty	CB S
Space 1 3 5	Name Dry Module HVAC		Space         2           2         4           4         6	Name Empty Empty Empty Empty	
Space 1 3		CB Size	Space           2           4	Name Empty Empty	CB Si 20 20


	I			7			
						Crowder College	- Drury University
							2
							nelteR <sup>3</sup> recover resist
Service Fe	eder	Calcula	ations			respond	
ling	1000	х З	3000			<b>P-I</b>	
uits	2	x 1500	3000			TEAM NAME:	
	1	x 1500				ADDRESS:	DRURY UNIVERSITY 900 N BENTON AVENUE
tal of gen. lighting load	and the second second second	CONTRACTOR CONTRACTOR CONTRACTOR CONTRACTOR	Characterian (Characterian)				SPRINGFIELD, MO 65802 CROWDER COLLEGE
and the second		er NEC 220.42		X 100%	3000		601 LACLEDE AVENUE NEOSHO, MO 64850
Remaining		er NEC 220.42	CARA INTERVIEW INTERVIEW	x 35%	1575	CONTACT:	SHELTER.DRURY.EDU ROWDERDRURYSOLAR@GMAIL.COM
eplate per NEC Sectior	77350984545555	Total demand	for general lighting lo	ads =	4575	_D C	
ce	Voltage	Amperage	VA				
	120	12	1440				
	120	6	720				
	240	75	18000				
	120	9.8	1176				
Sul	ototal of Fix	ed Appliances	21336				
	3 or less Fix	ed Appliances	x 100%				
4	or more Fix	ed Appliances	x 75%	16002			
		25				-C CLIENT	
	240	35	8400				DEPARTMENT OF ENERGY
	240	30 Cooking Loads	7200				V.SOLARDECATHLON.GOV
	Subtotal of G	Cooking Loads NEC 220.55	5	10140			
		NLC 220.55	X 0576	10140		U.S. SC	DEPARTMENT OF ENERGY
			2120			FEI	3. 12th CONSTRUCTION DRAWINGS
	240	30	7200				
(	240	50	373				
			575				
	Tabala	A Demand	40410				
الم المنظمة الم		A Demand	40410				
VA divided b Service	Panel Size	Amps Amps	168.4 200				
	- difer bize		200			MARK D	ATE DETAILS
20.61(a)		x 100%	4575				
220.61(a)		x 100%	16002				Project Number
))		x 70%	7098			DRAWN BY: CHECKED BY:	Author Checker
		x 100%	7573			COPYRIGHT:	NONE: PROJECT IS PUBLIC DOMAIN
	Total V	A Demand	35248				
VA divided b	y 240 volts	Amps	147			SHEET TITLE	
VA divided b	y 240 voits	Amps	147				RVICE PANEL SCHEDULE
							- 000
							E-603

	Soni	ico Fo	odor	Calcula	ations					recover resis
<b>.</b>		LE FE	euei	Calcula						
General Lightin						1				
Square Footage of			1000	x 3	3000					
Kitchen small appl Laundry branch cii			1	x 1500 x 1500	5 (c)				EAM NAME:	DRURY UNIVERSI
Laundry branch ch	Subtotal of gen. I	ighting loads	ner NFC S						DDRESS:	900 N BENTON AVEN SPRINGFIELD, MO 658
	Subtotal of gen. 1	Stall and a second state of the second		er NEC 220.42	1	X 100%	3000			
		(80 X001470 X00	nan Artinesana ar	er NEC 220.42	NO STREET	x 35%	1575			601 LACLEDE AVEN NEOSHO, MO 648
				and the second se	for general lighting lo		4575	-D	ONTACT: CROWD	SHELTER.DRURY.E DERDRURYSOLAR@GMAIL.Co
Fixed Appliance I c	oads (nameplate per	NEC Section	220 14)							
	Appliance	ALC SECTOR	Voltage	Amperage	VA					
Dishwasher	Applance		120	Amperage 12	1440					
Range Hood		1	120	6	720					
Water Heater			240	75	18000					
Disposal 1/2 HP			120	9.8	1176					
010p0001 1/ 2 11				510						
		Sub	total of Fix	ed Appliances	21336					
NEC 220 52		ALE CONSTRUCT		ed Appliances	Contarto Contracto					
NEC 220.53				ed Appliances		16002				
Cooking								-c		
Electric Range			240	35	8400			C	LIENT U.S. DEPAR	TMENT OF ENERGY
Stove			240	30	7200				SOLAR [	DECATHLON 2013
		Su		Cooking Loads					WWW.SOL/	ARDECATHLON.GOV
				NEC 220.55		10140				RTMENT OF ENERCY
Heating & Coo	ling								U.S. DEPA	RTMENT OF ENERGY
HVAC	ang -				2120					
Serverse and a server					2120				FEB. 12th	CONSTRUCTION DRAWI
Other Loads			2.40	22	7200					
EVSE	1.0		240	30						
1/2 HP Water Sup	ply Pump				373					
			Tatala		10110			—B		
		بالحاجات الم		A Demand	40410					
	V	A divided by		Amps						
		Service	Panel Size	Amps	200				IARK DATE	DETAILS
Neutral Condu										
								L(	OT NUMBER:	Project Number
	Contraction of the second s			The second sector second second					RAWN BY:	Author
	No rep at a contra contra			Haddhura Maaraalaa						
other Loads NEC 2	20.01(8)		Total	623/11/40 251	construction of a star					PUBLIC DOMAIN
		A divided by								
	220.61(a)	A divided by		x 100% x 100% x 70% x 100% A Demand Amps	4575 16002 7098 7573 35248 147			D C	RAWN BY: HECKED BY: OPYRIGHT: HEET TITLE SERVI SCH	Author Checker NONE: PROJECT IS

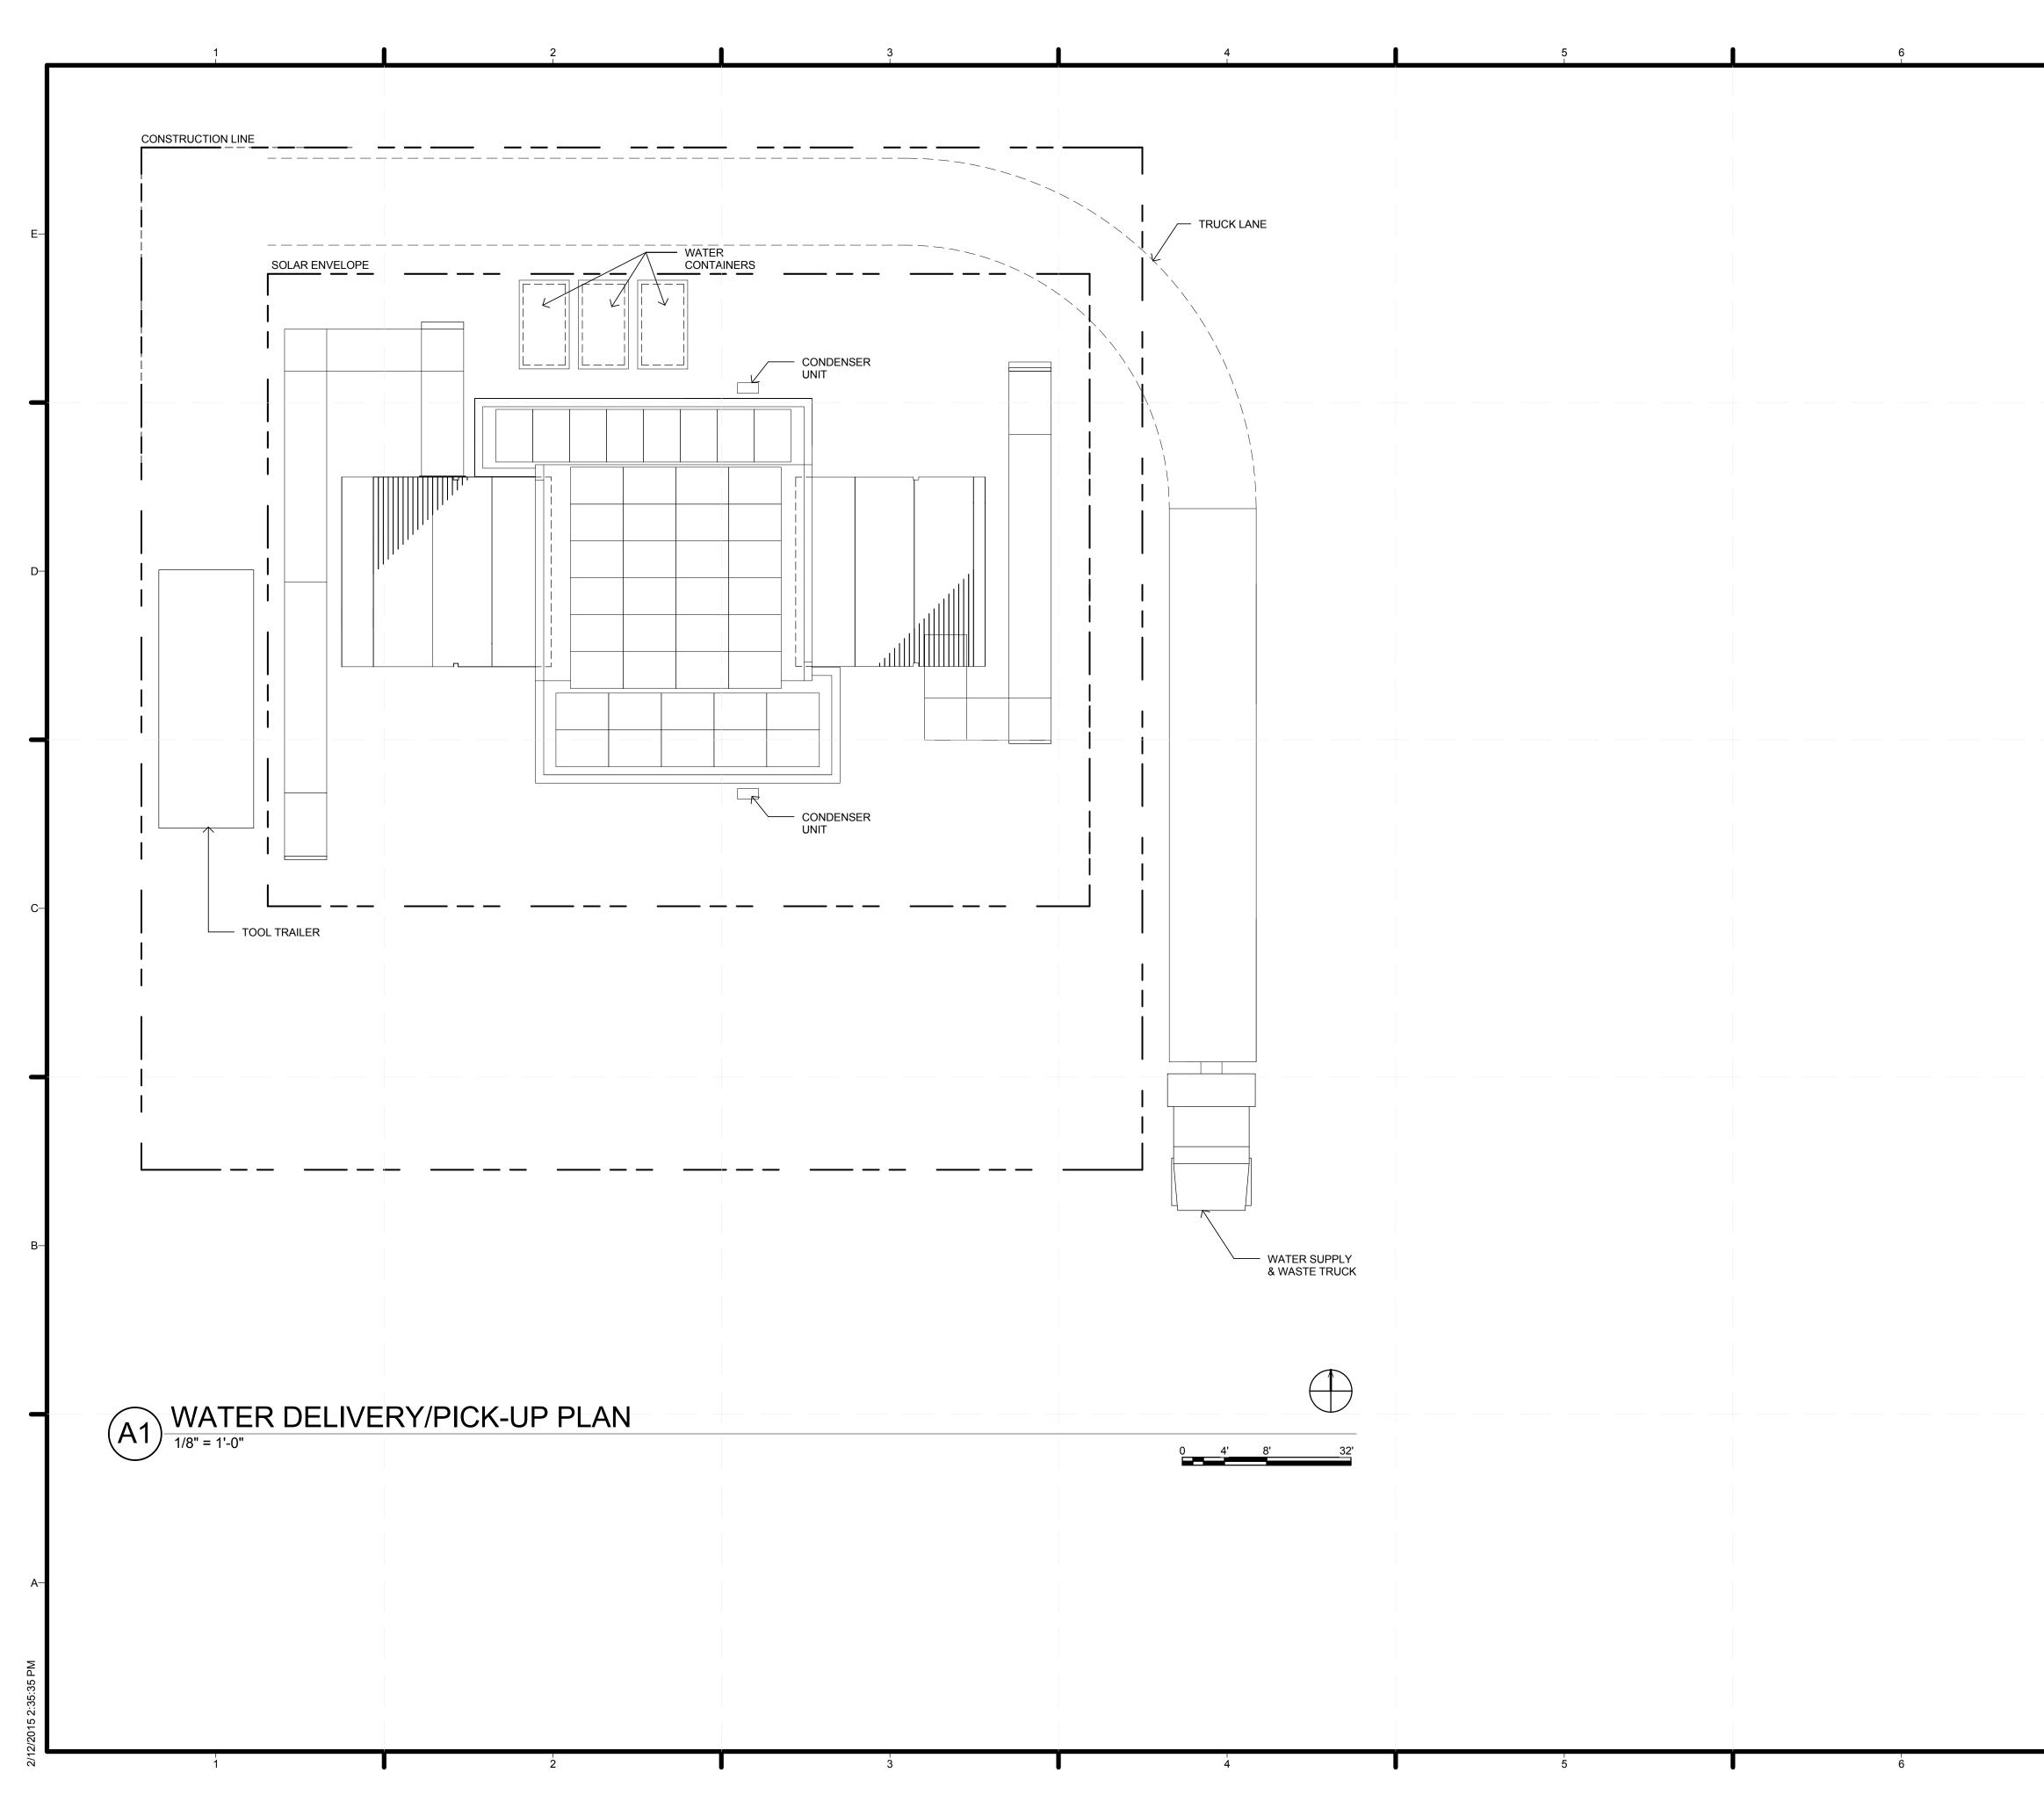

7				
		Crownlar	College - Drury U	enisonum idu e
	F			elteR <sup>3</sup>
	E			recover resist
		TEAM NAI	ME:	CROWDER/DRURY
		ADDRESS	3:	DRURY UNIVERSITY 900 N BENTON AVENUE SPRINGFIELD, MO 65802
		CONTACT	-	CROWDER COLLEGE 601 LACLEDE AVENUE NEOSHO, MO 64850 SHELTER.DRURY.EDU
	-D	CONTACT	CROWDE	RDRURYSOLAR@GMAIL.COM
				AUGUST 17TH, 2015
	—		/	
	–C	CLIENT	U.S. DEPART	MENT OF ENERGY
				CATHLON 2015 DECATHLON.GOV
			U.S. DEPART	MENT OF ENERGY
			FEB. 12th	CONSTRUCTION DRAWINGS
	-В			
		MARK	DATE	DETAILS
				101 Author
		DRAWN B CHECKEE COPYRIG	) BY:	Author Checker NONE: PROJECT IS
		0=-		PUBLIC DOMAIN
		SHEET TI		ATER
	-A	D	ELIVEF	RY/PICK-UP LAN
			0-	101
7				

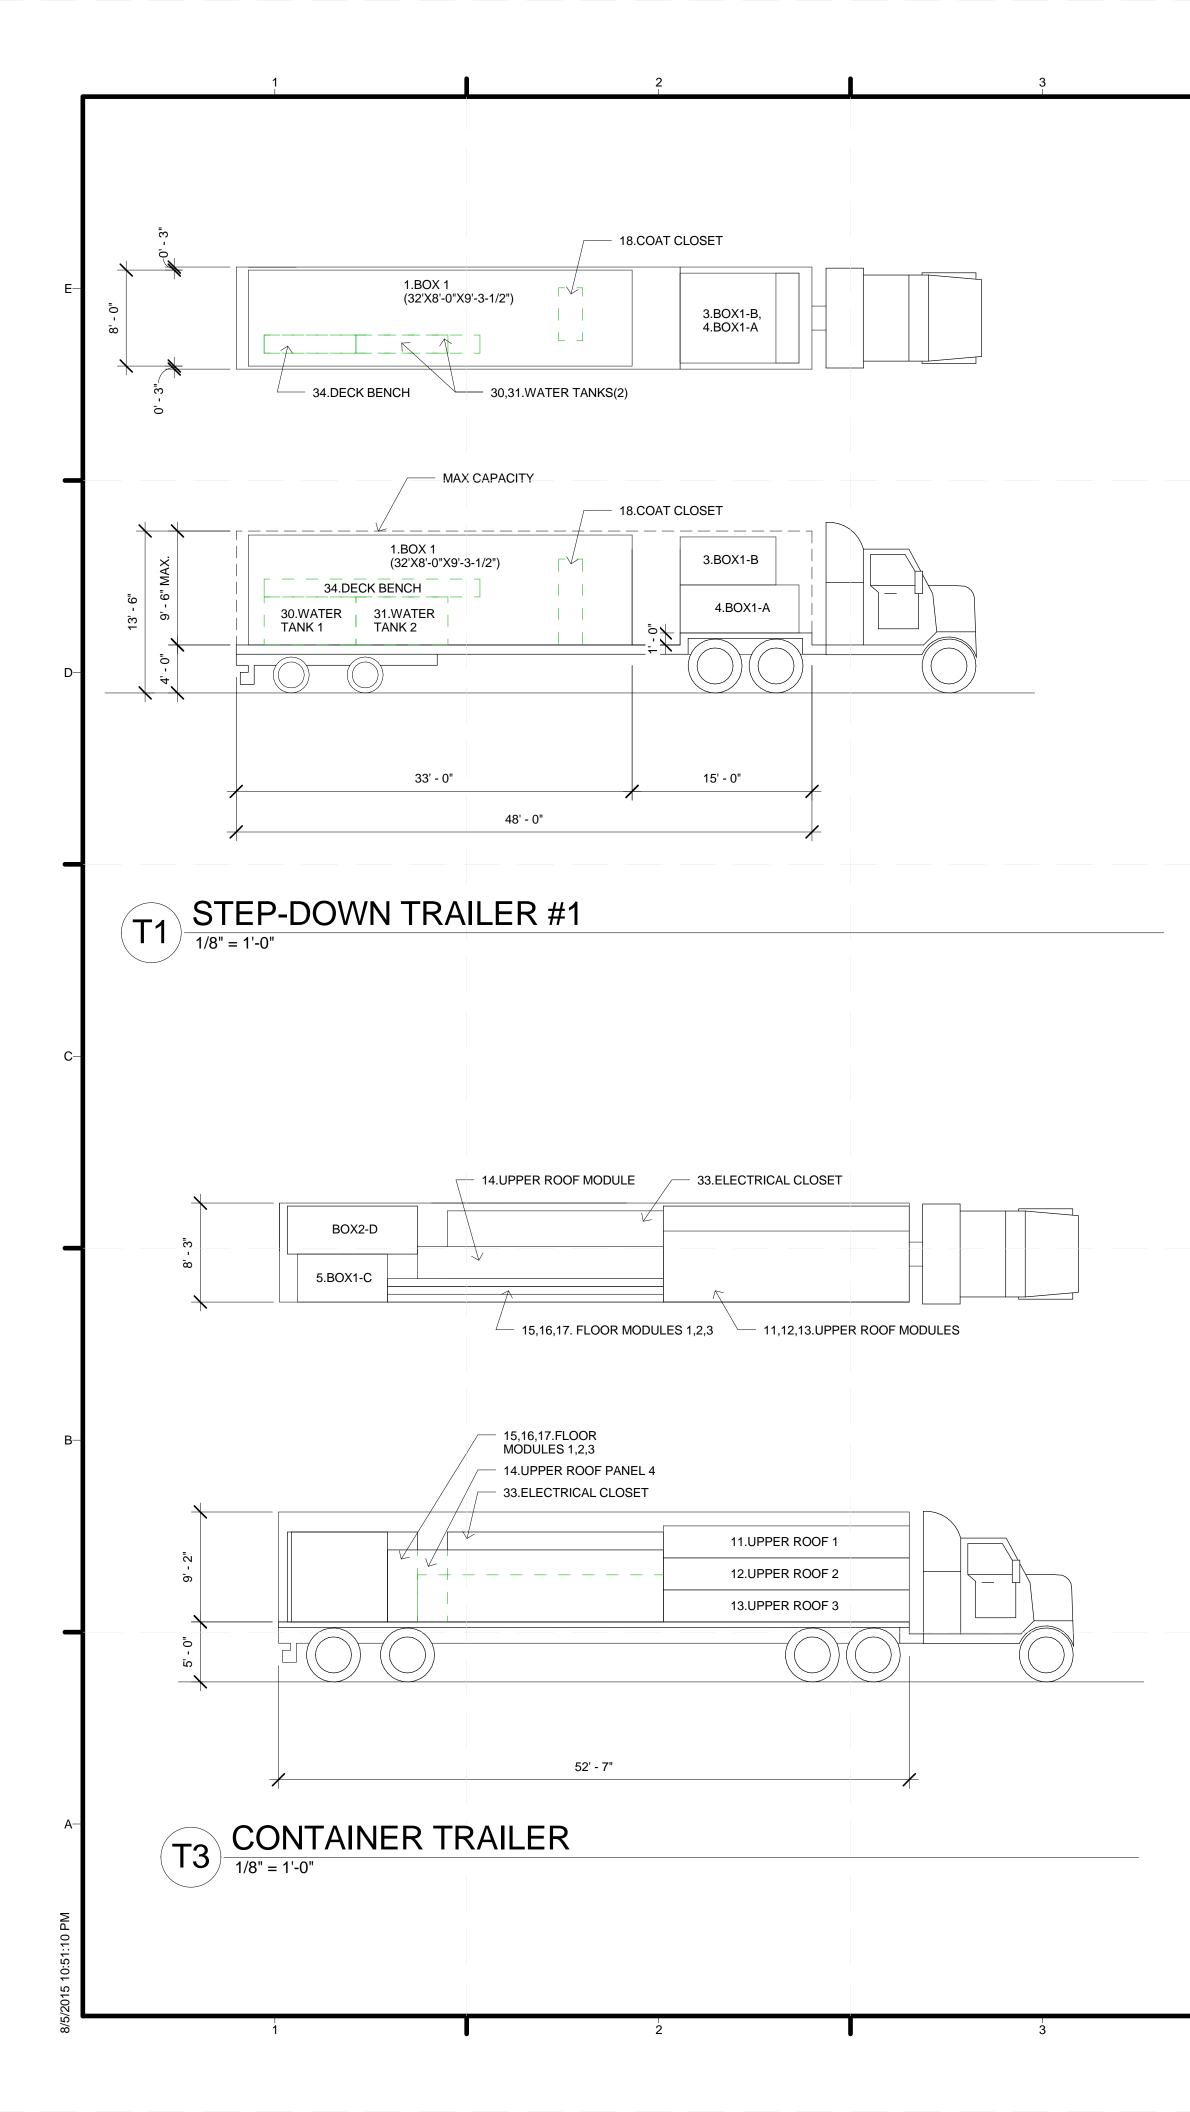

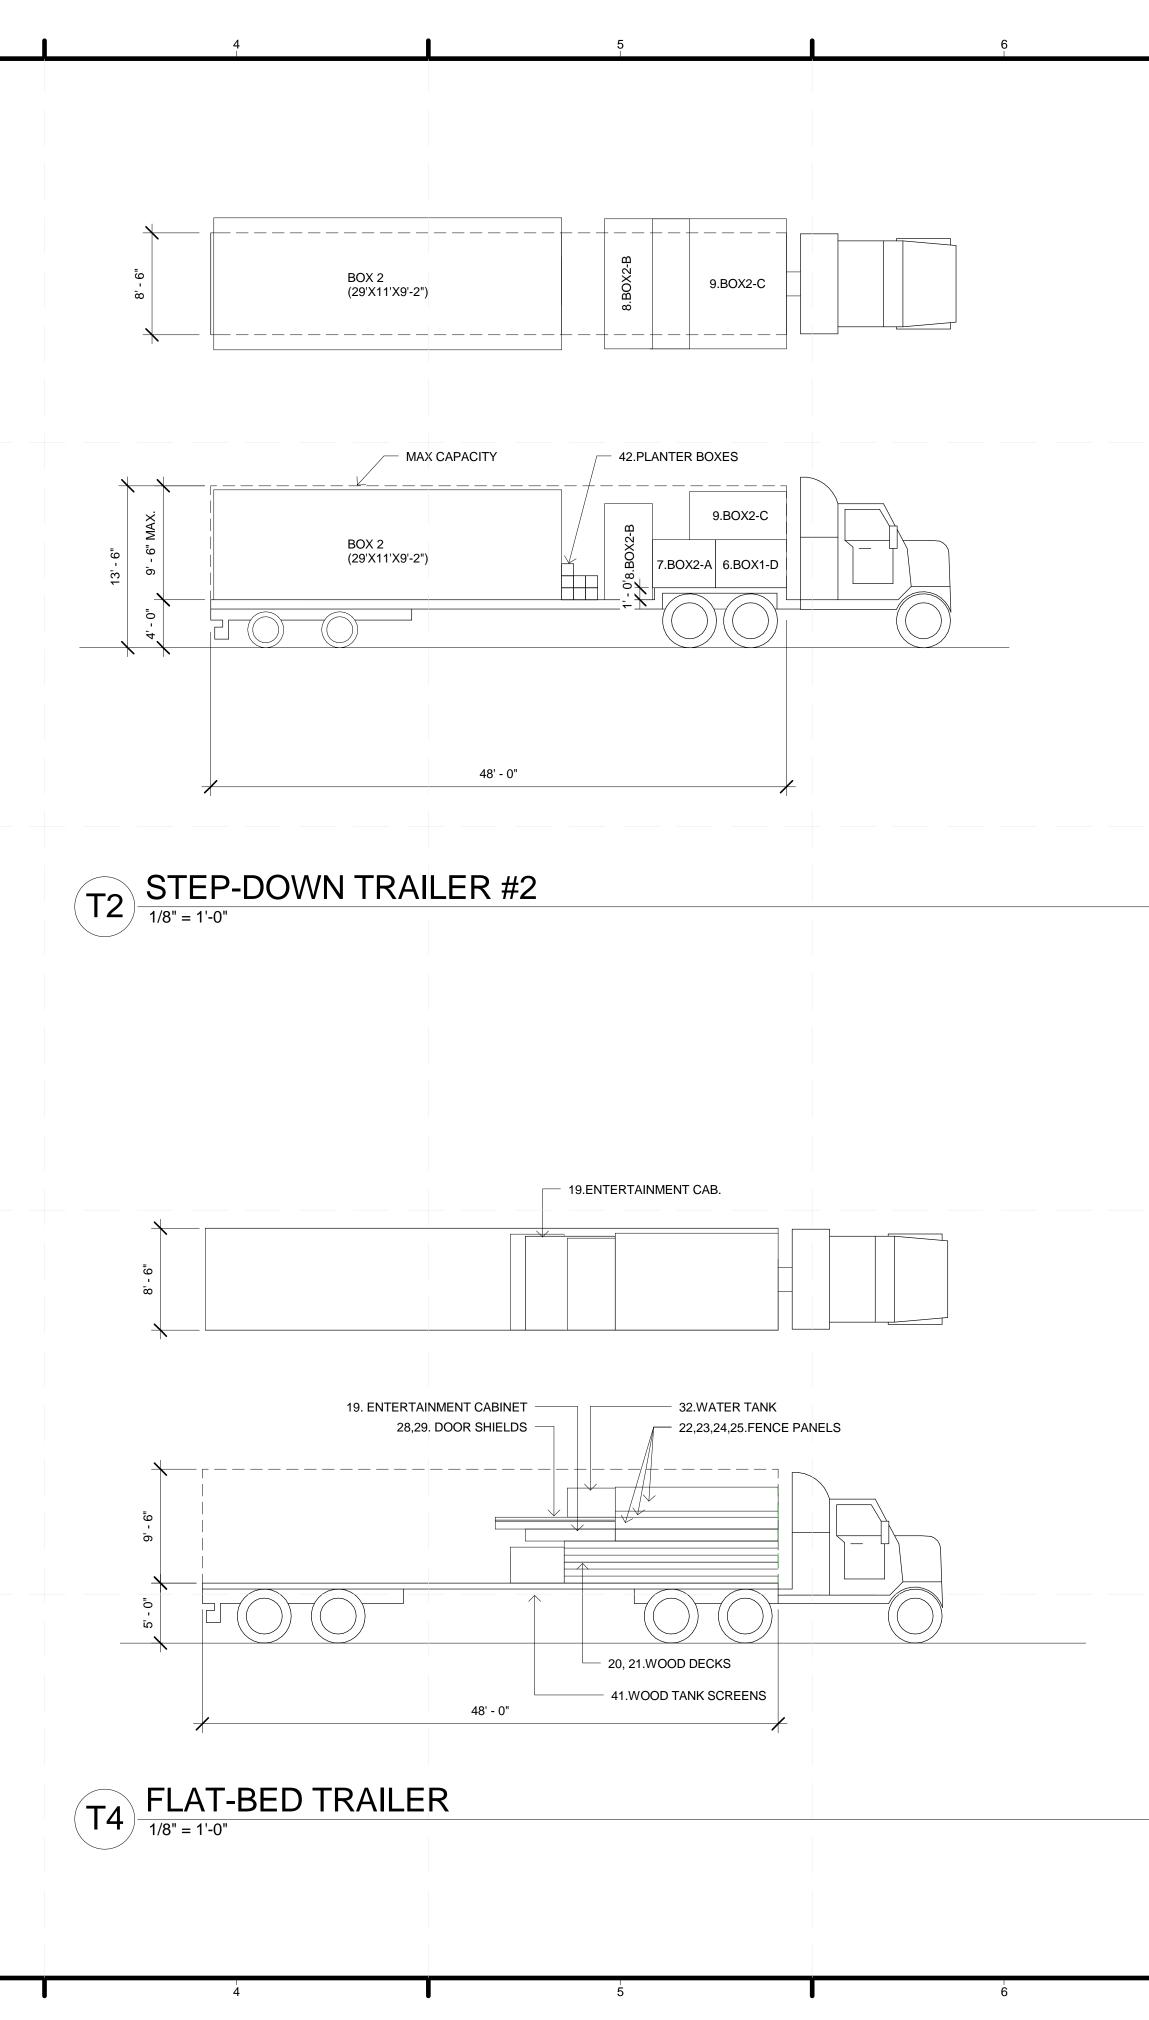

7	
1BOX 1 WET MODULE $32' X 8' X 8' - 3 - 1/2"$ T12BOX 2 DRY MODULE $29' X 11' X 9' - 3 - 1/2"$ T23BOX 1 - A LOWER ROOF $9' - 11" X 7' - 4" X 4' - 0"$ T14BOX 1 - B LOWER ROOF $8' - 0" \times 7' - 4" \times 4' - 0"$ T15BOX 1 - C LOWER ROOF $8' - 0" \times 7' - 4" \times 4' - 0"$ T36BOX 1 - D LOWER ROOF $8' - 0" \times 7' - 4" \times 4' - 0"$ T27BOX 2-A LOWER ROOF $5' - 3" \times 10' - 10" \times 4' - 0"$ T28BOX 2-B LOWER ROOF $8' - 0" \times 10' - 10" \times 4' - 0"$ T29BOX 2-C LOWER ROOF $8' - 0" \times 10' - 10" \times 4' - 0"$ T210BOX 2-D LOWER ROOF $8' - 0" \times 10' - 10" \times 4' - 0"$ T311UPPER ROOF 1 $6' - 3" \times 20' - 6" \times 2' - 8"$ T312UPPER ROOF 2 $8' - 0" \times 20' - 6" \times 2' - 8"$ T313UPPER ROOF 3 $8' - 0" \times 20' - 6" \times 2' - 8"$ T314UPPER ROOF 4 $3' - 11" \times 20' - 6" \times 2' - 8"$ T315FLOOR MODULE 1 $6' - 0" \times 23' - 0" \times 8"$ T316FLOOR MODULE 3 $6' - 0" \times 23' - 0" \times 8"$ T317FLOOR MODULE 3 $6' - 0" \times 23' - 0" \times 8"$ T318COAT CABINET $4' - 5" \times 1' - 0" \times 7' - 10"$ T320(5) WOOD DECK $5' - 8" \times 17' - 10" \times 7"$ T521(1) WOOD DECK $6' - 9" \times 17' - 10" \times 7"$ T522(8) FENCE N2, 3, 4, 5, S2, 3, 4, 5, $8' \times 13' - 7" \times 3"$ T324(4) FENCE E1, E2, W2, W3 $5' - 10" \times 13' - 7" \times 3"$	Ferror College - Drury University Sheeteen Sheeteen Shee
26 $(42)$ SOLAR PANELS3'-6" x 5'-2" x 2"T227 $(8)$ SLIDING DOORS (GLASS)4'-6" x 10' x 1"T328DOOR SHIELDS (SINGLE)4'-6" x 10' x 1"T329DOOR SHIELD (TRIPLE)4'-6" x 10' x 3"T330WATER TANK4' x 7'-8" x 2'-5"T131WATER TANK4' x 7'-8" x 2'-5"T132WATER TANK4' x 7'-8" x 2'-5"T233ELECTRICAL CLOSET18'-0" x 3'-0" x 7'-6"T334DECK BENCH17'-10" x 1'-2" x 1'-6"T135PIERS (56)UNKNOWNT236PLYWOOD FOR PIERS(56)-2' x 2' x 3/4"T237(8) CRIBBING2' x 2' x 4'T438SIGNAGE4' X 1" x 6'T240FANT2T241WATER TANK SCREENS4'-6" x 8' x 3'T442(24) PLANTER BOXES2' x 1' x 1'T243REFRIGERATORT244FRONT RAMP(3) 9' SECTIONST245REAR FRONT(6) 10' SECTIONST246LANDINGS(4) 4' x 4'T2	TEAM NAME: CROWDER/DRURY ADDRESS: DRURY UNIVERSITY 900 N BENTON AVENUE SPRINGFIELD, MO 65802 CROWDER COLLEGE 601 LACLEDE AVENUE NEOSHO, MO 64850 CONTACT: SHELTER.DRURY.EDU CROWDERDRURYSOLAR@GMAIL.COM FEBRUARY 12TH, 2015
	-C CLIENT U.S. DEPARTMENT OF ENERGY SOLAR DECATHLON 2015 WWW.SOLARDECATHLON.GOV
	V.S. DEPARTMENT OF ENERGY SOLAR DECATHLON FEB. 12th CONSTRUCTION DRAWINGS
	B
	MARK DATE DETAILS          MARK       DATE       DETAILS         LOT NUMBER:       101         DRAWN BY:       Author         CHECKED BY:       Checker
	COPYRIGHT: NONE: PROJECT IS PUBLIC DOMAIN SHEET TITLE TRUCK LOADING
7	O-901

